

CONSTRUCTION DOCUMENTS FOR

BEAUFORT COUNTY COMMUNITY COLLEGE


INDUSTRIAL TRADES TRAINING CENTER

AURORA, NC

SCO ID #23-27044-01A

JKF PROJECT NO. 2024-10

JANUARY 6, 2025

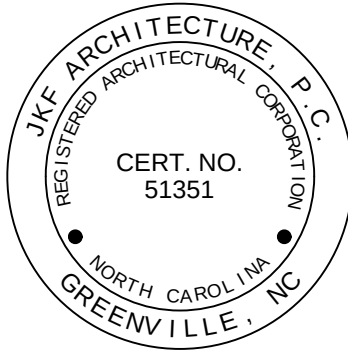

THE EAST GROUP
CIVIL ENGINEERS
324 S. EVANS ST.
GREENVILLE, NC 27834
252-758-3746

NESER & ROOMSBURG, PA
STRUCTURAL ENGINEERS
748 LORD DUNMORE DRIVE, STE. 101
VIRGINIA BEACH, VA 23464
757-474-0612

ATLANTEC ENGINEERS, PA
PLUMBING, MECHANICAL & ELECTRICAL ENGINEERS
3221 BLUE RIDGE ROAD, SUITE 113
RALEIGH, NC 27612
919-571-1111

ROOM FINISH SCHEDULE
(SEE FLOOR PLANS)

ROOM NAME

IOI

A

B

C

WALL FINISH

BASE MATERIAL/FINISH

FLOOR MATERIAL/FINISH

FLOOR MATERIALS/FINISH

CT CERAMIC TILE

EC EXPOSED CONCRETE, SEALED

LV LUXURY VINYL TILE

BASE MATERIALS

CT CERAMIC TILE

R RUBBER

WALL MATERIALS/FINISH

CT CERAMIC TILE

P PAINTED GYPSUM BOARD

REFLECTED CEILING PLAN LEGEND

ROOM NAME

IOI

CLS

Height

ELEC

CEILING MATERIAL

INDIRECT LAY-IN LIGHT FIXTURE
(SEE ELECTRICAL DRAWINGS
FOR SIZE AND TYPE)

DIRECT/INDIRECT PENDENT
MOUNTED LIGHT FIXTURE
(SEE ELECTRICAL DRAWINGS
FOR SIZE AND TYPE)

SUPPLY AIR DIFFUSER

EXHAUST AIR GRILLE

DOWNLIGHT FIXTURE

EXIT SIGN

SIGN FACE

DIRECTION ARROW IF NEEDED

SMOKE DETECTOR

STROBE

HORN STROBE

OCCUPANCY SENSOR

DATUM ABOVE FIN. FLOOR
CEILING MATERIAL (SEE LEGEND)

CEILING MATERIALS LEGEND

APC ACOUSTICAL PANEL CEILING

(IF FOLLOWED BY A NUMERAL DENOTES
SPECIAL TYPE AS SPECIFIED)

EXPD EXPOSED STRUCTURE PAINTED

GENERAL PROJECT LEGEND

REFERENCE NO.

DRAWING NO.

DENOTES CHANGE IN FINISHED
FLOOR MATERIAL

ELEVATION REFERENCE

DOOR NO.

DOOR ASSEMBLY DESIGNATION

HARDWARE SET NO.

DOOR GROUP NO.

PARTITION TYPE
(SEE DRAWING A7.1)

DOT DENOTES SIDE
W/SPECIAL FINISH

GENERAL NOTE REFERENCE
NUMBERS DESIGNATE DEMOLITION
LETTERS DESIGNATE
CONSTRUCTION.

FIRE PULL

ARCHITECTURAL ABBREVIATIONS

APC ACOUSTICAL PANEL CEILING

ADJ ADJACENT

AFF ABOVE FINISHED FLOOR

AL ALUMINUM

ALT ALTERNATE

AN ANODIZED

ATIN ATTENUATION

BD BOARD

BIT BITUMINOUS

BLKG BLOCKING

BLKT BLANKET

BM BEAM

BOP BOTTOM OF PLATE

BOS BOTTOM OF STEEL

BRS BEARING

CAB CABINET

CAP CAPACITY

CB CATCH BASIN

C CENTERLINE

CJ CONTROL JOINT

CLGT HT CEILING HEIGHT

CLR CLEAR

CLG CEILING

CMU CONCRETE MASONRY UNIT

COL COLUMN

CONC CONCRETE

CONSTR CONSTRUCTION

CONT CONTINUOUS

CONTR CONTRACTOR

CT CERAMIC TILE

DWG DRAWING

EA EACH

EC ELECTRICAL CONTRACTOR

EF EXHAUST FAN

ELEC ELECTRICAL

ENCL ENCLOSURE

EOS EDGE OF SLAB

EWCELECTRIC WATER COOLER

EXIST EXISTING

EXPD EXPOSED

EXP EXPANSION JOINT

EXT EXTERIOR

FDN FOUNDATION

FE FIRE EXTINGUISHER

FFE FINISHED FLOOR ELEVATION

FL FLOOR

FRP FIBERGLASS REINFORCED POLYESTER

FT FIRE RETARDANT TREATED

FTG FOOTING

FUR FURRING

GA GAUGE

GAL GALLON

GALV GALVANIZED

GB GRAB BAR

GC GENERAL CONTRACTOR

GL GLASS

GN GENERAL NOTE

GYP BD GYPSUM BOARD

HDW HARDWARE

HM HOLLOW METAL

HT HEIGHT

HVAC HEATING, VENTILATION, AIR CONDITIONING

INT INTERIOR

INSUL INSULATION

INV INVERT

JOINT JOINT

LAV LAVATORY

MANUF MANUFACTURER

MC MECHANICAL CONTRACTOR

MH MANHOLE

MECH MECHANICAL

MIN MINIMUM

MO MASONRY OPENING

MTO MOUNTED

MTL METAL

NTS NOT TO SCALE

NIC NOT IN CONTRACT

O/C ON CENTER

OH OVERHANG

OHID OVERHEAD

OPNG OPENING

PART PARTITION

PC PLUMBING CONTRACTOR

PGB PAINTED GYPSUM BOARD

PGBR PAINTED GYPSUM BOARD WITH REVEAL

PL PLATE

P PAINTED

REF REFRIGERATOR

REINF REINFORCE / REINFORCING

REQD REQUIRED

RM ROOM

RO ROUGH OPENING

RSW RAIL & STILE WOOD

SF SQUARE FEET

SIM SIMILAR

SPECS SPECIFICATIONS

SS STAINLESS STEEL

STD STANDARD

STL STEEL

STRUCT STRUCTURE / STRUCTURAL

SUSP SUSPENDED

TC TOP CURB

TF TRANSPARENT FINISH

TG TOP GRATE

TEMP TEMPERED

THK THICK

TJ TOP OF JOIST

TOB TOP OF BRICK

TOM TOP OF MASONRY

TOP TOP OF PLATE

TOS TOP OF SLAB

TOW TOP OF WALL

TYP TYPICAL

T/S TOP OF STEEL

TS TUBE STEEL

UNO UNLESS OTHERWISE NOTED

VAR VARIES

VERT VERTICAL

VIF VERIFY IN FIELD

WD WOOD

WDW WINDOW

WSC WOOD SOLID CORE

WWF WELDED WIRE FABRIC

W WITH

2018 APPENDIX B
BUILDING CODE SUMMARY FOR ALL COMMERCIAL PROJECTS
(EXCEPT 1 AND 2-FAMILY DWELLINGS AND TOWNHOUSES)
(Reproduce the following data on the building plans sheet 1 or 2)

Name of Project: BEAUFORT COUNTY COMMUNITY COLLEGE INDUSTRIAL TRAINING CENTER

Address: S. HETH ST. LOT 19 TOWN OF AURORA INDUSTRIAL PARK, AURORA, NC Zip Code: 27806

Owner/Authorized Agent: SAMMY DEANS Phone #: (252) 940-6423 E-Mail: Sammy.deans@beaufort.edu

Owned By: County

Code Enforcement Jurisdiction: County

CONTACT:

DESIGNER

FIRM

NAME

LICENSE #

TELEPHONE #

E-MAIL

Architectural

JKF

John K.

NC 5922

(252) 355-1068

jkf@jk-farch.com

Electrical

Atlantic

Alex R.

NC 058287

(919) 571-1111

Alex@atlantecengineers.com

Fire Alarm

Atlantic

Alex R.

NC 058287

(919) 571-1111

Alex@atlantecengineers.com

Plumbing

Atlantic

James B.

NC 22035

(919) 571-1111

jim@atlantecengineers.com

Mechanical

Atlantic

Harrison Holt,

NC 049754

(919) 571-1111

Harrison@atlantecengineers.com

Structural

Niser &

Kevin

NC 022830

(757) 474-0612

knn@nrvengineering.com

Civil

The East

Michelle

NC 029422

(252) 758-3746

michelle.clements@eastgroup.com

2018 NC BUILDING CODE: New Building

2018 NC EXISTING BUILDING CODE: N/A

CONSTRUCTED: (date) N/A CURRENT OCCUPANCY(S) (Ch. 3): N/A

RENOVATED: (date) N/A PROPOSED OCCUPANCY(S) (Ch. 3): Business

RISK CATEGORY (Table 1604.5): Current: N/A Proposed: II

BASIC BUILDING DATA

Construction Type: II-B

Sprinklers: No N/A

Standpipes: No

Primary Fire District: No

Flood Hazard Area: No

Special Inspections Required: No

Gross Building Area Table

FLOOR

EXISTING (SQ. FT.)

NEW (SQ. FT.)

SUB-TOTAL

1st Floor

N/A

5,006

5,006

TOTAL

5,006

5,006

ALLOWABLE AREA

Primary Occupancy Classification(s): Business

Accessory Occupancy Classification(s): NONE

Incidental Uses (Table 509): NONE

Special Uses (Chapter 4 – List Code Sections): NONE

Special Provisions: (Chapter 5 – List Code Sections): NONE

Mixed Occupancy: No Separation: N/A Exception: N/A

Select one:
 $\frac{Actual\ Area\ of\ Occupancy\ A}{Allowable\ Area\ of\ Occupancy\ A} + \frac{Actual\ Area\ of\ Occupancy\ B}{Allowable\ Area\ of\ Occupancy\ B} \leq 1$

STORY NO.

DESCRIPTION AND USE

(A) BLDG AREA PER STORY (CAPITAL)

(B) TABLE 506.2¹ AREA

(C) AREA FOR FRONTAGE INCREASES²

(D) ALLOWABLE AREA PER STORY OR UNDIMINISHED³

1

B-EDUCATION ABOVE THE 12TH GRADE

4,565

23,000

N/A

23,000

¹ Frontage area increases from Section 506.3 are computed thus:
a. Perimeter which fronts a public way or open space having 20 foot minimum width – 288' (F)
b. Total Building Perimeter – 288' (F)
c. Ratio (F/P) = 1 (F/P)
d. W = Minimum width of public way = ≥30' (W)
e. Percent of frontage increase 1/2 = 100(F/P – 0.25) x W/30 = 75 (%)

² Unlimited area applicable under conditions of Section 507.
³ Maximum Building Area = total number of stories in the building x D (maximum 3 stories) (506.2).
⁴ The maximum area of open parking garages must comply with Table 406.5.4.
⁵ Frontage increase is based on the unsprinklered area value in Table 506.2.

ALLOWABLE HEIGHT

Building Height in Feet (Table 504.3)¹

55'

25'

CODE REFERENCE¹

Building Height in Stories (Table 504.4)¹

3

1

¹ Provide code reference if the "Shown on Plans" quantity is not based on Table 504.3 or 504.4.
² The maximum height of air traffic control towers must comply with Table 412.3.1.
³ The maximum height of open parking garages must comply with Table 406.5.4.

FIRE PROTECTION REQUIREMENTS

BUILDING ELEMENT

FIRE SEPARATION DISTANCE (FPT)

REQ'D

RATING PROVIDED OR REDUCTION

DETAIL # AND SNEY #

DESIGN # FOR RATED ASSEMBLY

SHEET # FOR RATED PENETRATION


SHEET # FOR RATED JOINTS

Structural Frame, including column, girders, joists

Bearing Walls

N/A

<

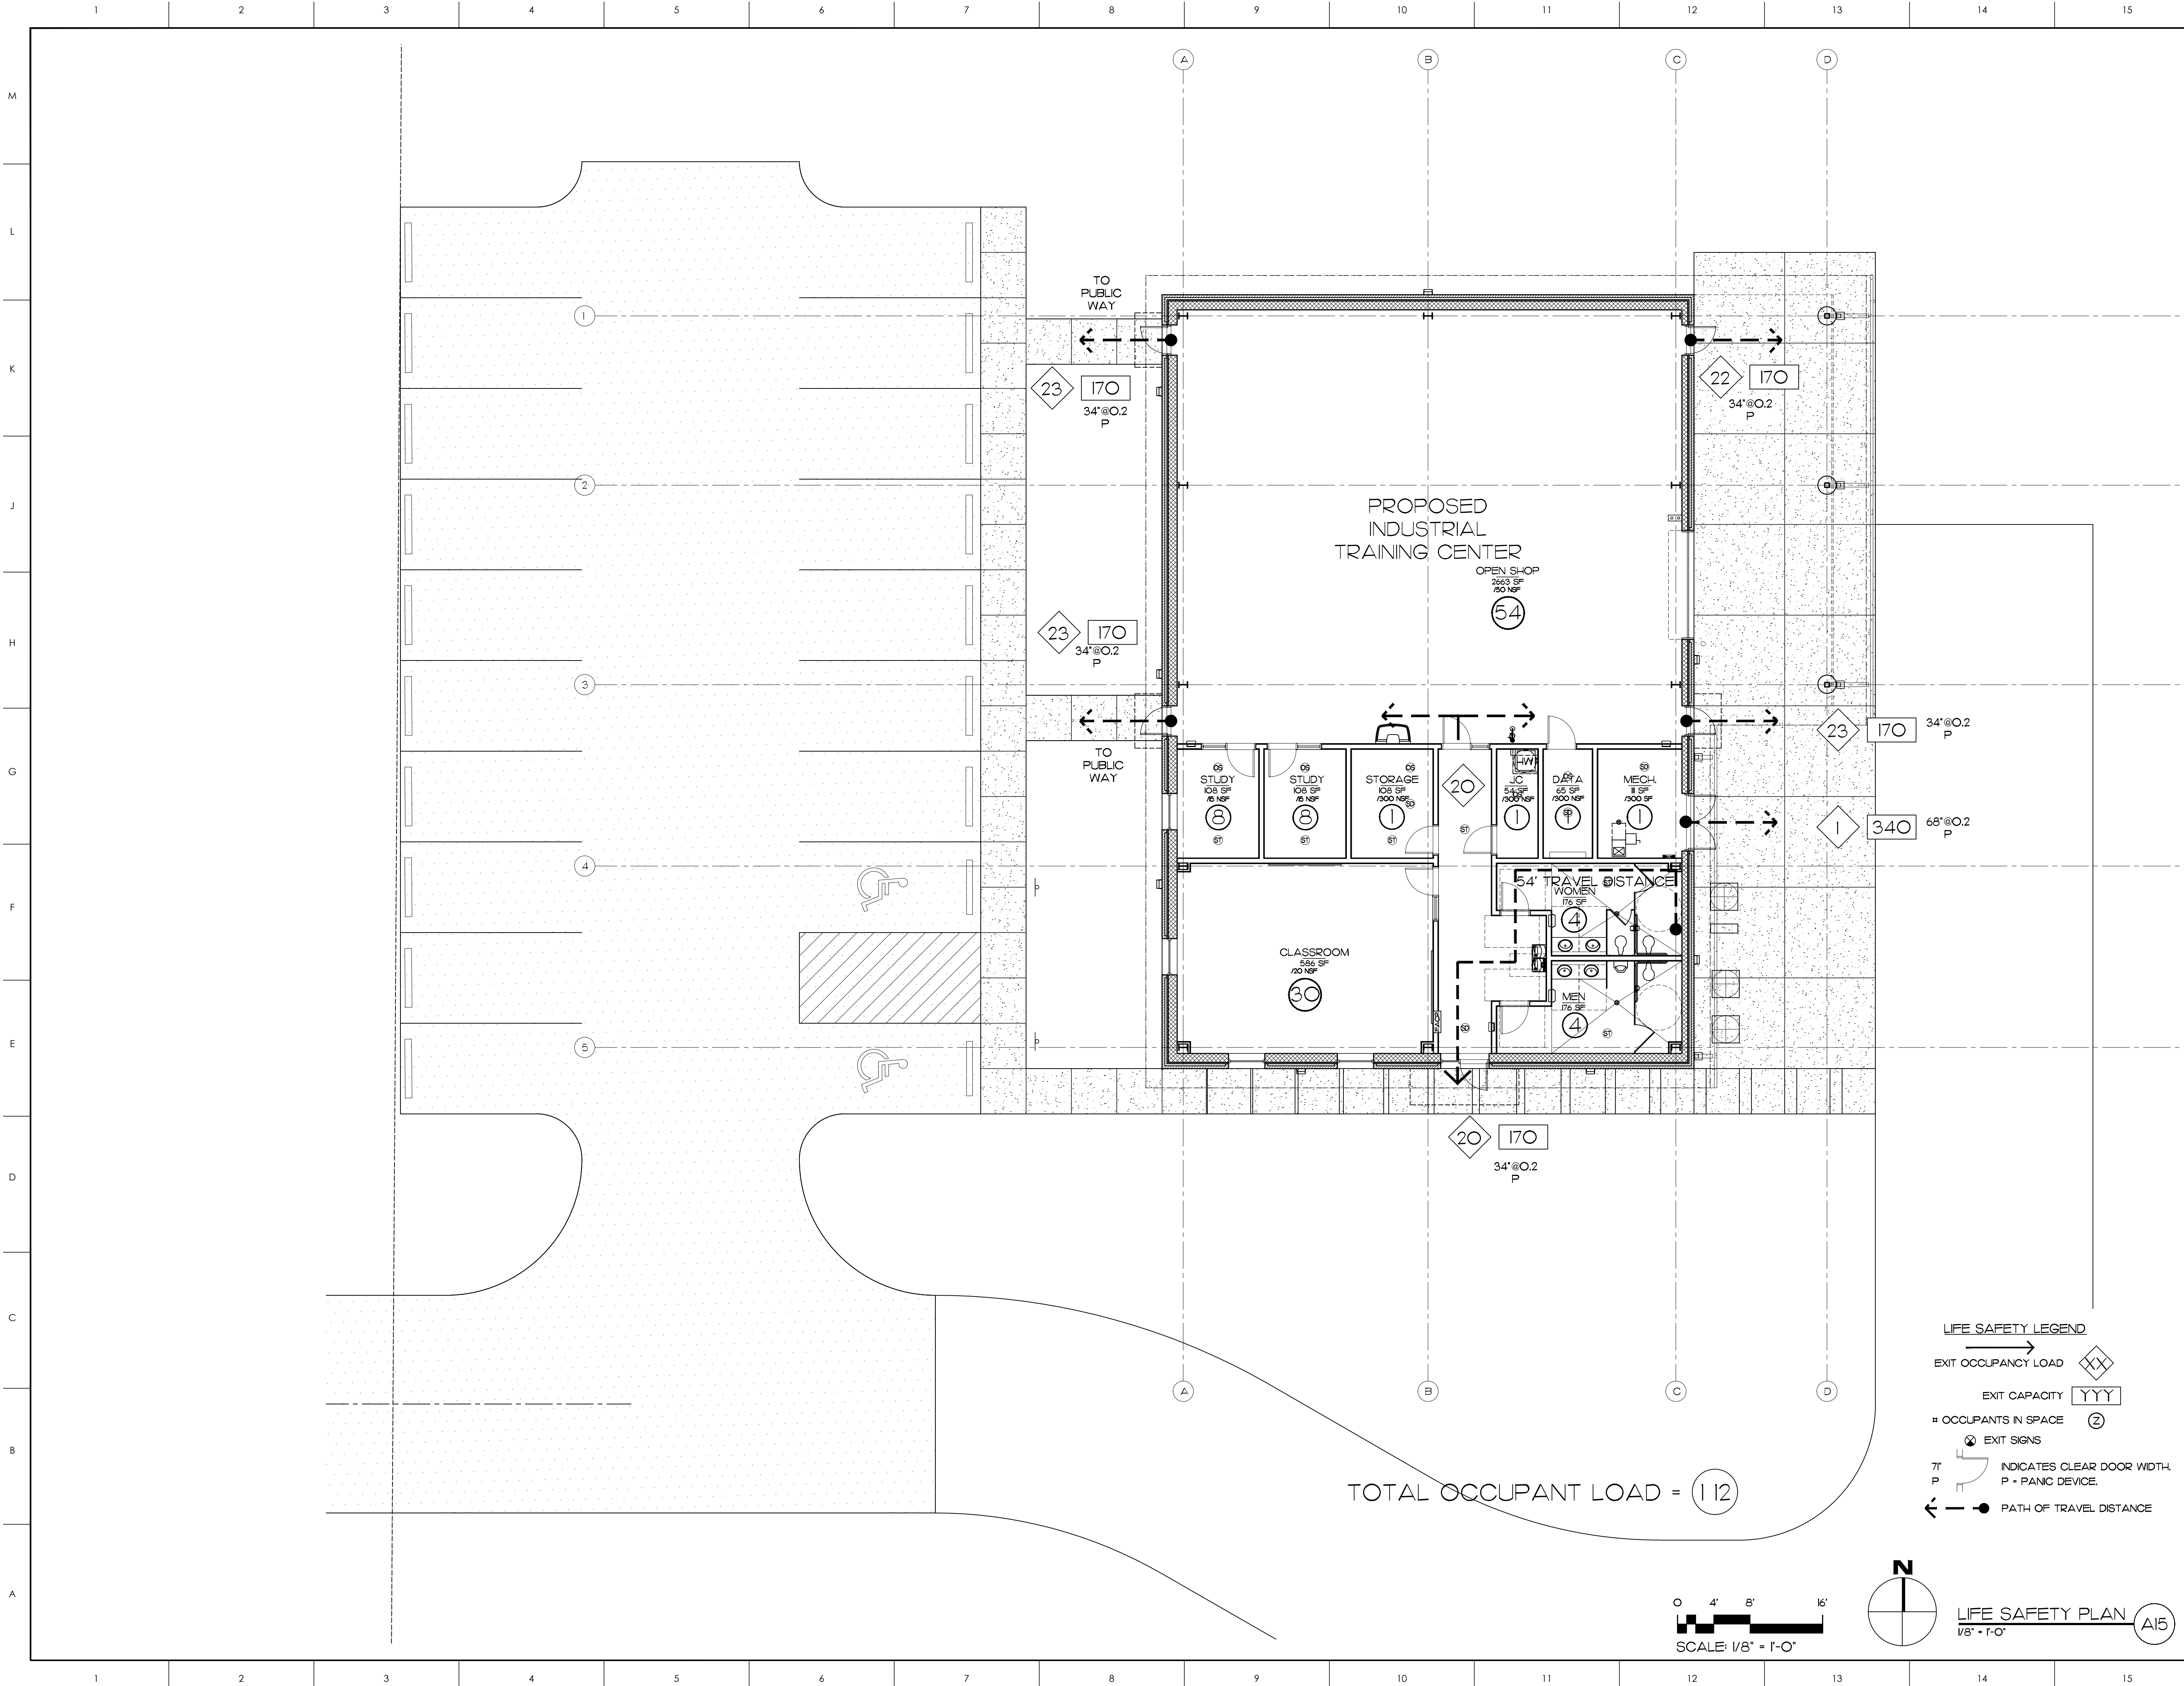

MATERIALS KEYING LEGEND

GENERAL NOTES

KEY PLAN

SCO ID #23-27044-01A

NO	REVISION	DATE
----	----------	------



JKF
ARCHITECTURE

625 LYNNDALE CT., SUITE F, GREENVILLE, NC 27838 252-355-1068

BEAUFORT COUNTY
COMMUNITY COLLEGE
INDUSTRIAL TRAINING CENTER
AURORA, NC


DRAWING TITLE
LIFE SAFETY PLAN

SCALE	AS NOTED
DRAWN	JRH
CHECKED	JKF
DATE	1-6-2025
PROJECT NO.	2024-10

DRAWING NO.
BCI.1

LIFE SAFETY LEGEND

- EXIT OCCUPANCY LOAD (X)
- EXIT CAPACITY (YYY)
- OCCUPANTS IN SPACE (Z)
- EXIT SIGNS
- INDICATES CLEAR DOOR WIDTH. P - PANIC DEVICE.
- PATH OF TRAVEL DISTANCE

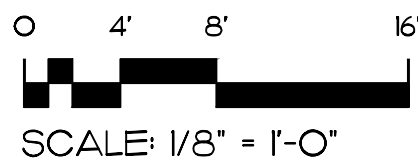

LIFE SAFETY PLAN A15
1/8" = 1'-0"



VICINITY MAP - NOT TO SCALE

SITE DATA

TOTAL AREA	48.218 AC. ±
AREA IN LOTS	38.033 AC. ±
AREA IN STREETS	2.727 AC. ±
AREA IN OPEN SPACE	7.458 AC. ±
AVERAGE LOT SIZE	1.902 AC. ±
LINEAR FEET IN STREETS	1,862 L.F. ±

NOTE :
COMBINED SCALE FACTOR = 0.99987838

ALL DISTANCES ARE HORIZONTAL
GROUND MEASUREMENTS IN FEET
AND DECIMALS THEREOF UNLESS
NOTED OTHERWISE.

N.C.G.S.M. "ROWE"

N = 571,612.36 FT. (GRID)
E = 2,659,723.19 FT. (GRID)
NAVD 1988 ELEV = 8.71

N.C.G.S.M. "RULANE"

N = 571,608.87 FT. (GRID)
E = 2,657,439.46 FT. (GRID)
NAVD 1988 ELEV = 11.13

N 89°53'09" E
2283.17 (HORIZONTAL)
2282.89 (GRID)

605.38 (GRID)
605.45 (HORIZONTAL)
S 72°05' E

AURORA HOUSING LIMITED
PARTNERSHIP
DB 969 PG 133

JOHN DRIVE
50' PUBLIC
RIGHT-OF-WAY

NCSR 1925 S 5TH STREET
60' PUBLIC RIGHT-OF-WAY

PRELIMINARY
NOT FOR RECORDATION
CONVEYANCE OR SALES

NOTES

- 1) THIS PROPERTY IS LOCATED IN ZONE X AND AE AND IS PARTIALLY LOCATED WITHIN THE 1% FEMA FLOOD HAZARD AREA AS SHOWN HEREON AS TAKEN FROM N.F.I.P. RATE MAP DATED 6/19/2020 COMMUNITY PANEL NUMBER 3720656600K. B.F.E. = 6±
- 2) THIS PROPERTY IS SUBJECT TO THE TAR/PAMLICO RIVER RIPARIAN BUFFER RULES.
- 3) THE SURVEYOR MAKES NO GUARANTEE THAT THERE ARE NO OTHER EASEMENTS THAT MAY BENEFIT OR BURDEN THE SUBJECT PROPERTY.
- 4) INTERIOR FIELD DITCHES ARE NOT SHOWN.
- 5) SEE SHEET 2 FOR APPROVALS AND CERTIFICATIONS.
- 6) MINIMUM BUILDING SETBACK: FRONT = 50'

TOWN OF AURORA'S
THIRD STREET
60' RIGHT-OF-WAY
(UNDEVELOPED)
DB 757 PG 14
DB 2139 PG 189

AURORA PLAZA, LLC
DB 2061 PG 959
PC F SLIDE 52-9

FISCHER VILLAGE APARTMENTS
DB 798 PG 806

AURORA HOUSING LIMITED
PARTNERSHIP
DB 969 PG 133

JOHN C. HOOKER
and wife LILLIAN V. HOOKER
DB 657 PG 402

TOWN OF AURORA
DB 756 PG 128

STATE OF NORTH CAROLINA

PITT COUNTY

I, WILLIAM B. HILLIARD, CERTIFY THAT THIS
PLAT WAS DRAWN UNDER MY SUPERVISION FROM AN ACTUAL
SURVEY MADE UNDER MY SUPERVISION; (DEED DESCRIPTION
RECORDED IN BOOK PAGE); THAT THE
BOUNDARIES NOT SURVEYED ARE CLEARLY INDICATED AS DRAWN
FROM INFORMATION FOUND IN BOOK PAGE ;
THAT THE RATIO OF PRECISION AS CALCULATED IS 1:10,000+;
THAT THIS PLAT WAS PREPARED IN ACCORDANCE WITH G.S. 47-30
AS AMENDED. WITNESS MY ORIGINAL SIGNATURE, LICENSE
NUMBER AND SEAL THIS DATE DAY OF MONTH, YEAR.

I, , REVIEW OFFICER OF
BEAUFORT COUNTY, CERTIFY THAT THE MAP OR PLAT TO
WHICH THIS CERTIFICATION IS AFFIXED MEETS ALL STATUTORY
REQUIREMENTS FOR RECORDING.

REVIEW OFFICER

DATE

PRELIMINARY
NOT FOR RECORDATION
CONVEYANCE OR SALES

NC HIGHWAY 33
PUBLIC RIGHT-OF-WAY VARIES

JEAN J. HENRIES
DB 757 PG 14

TOWN OF AURORA
DB 2139 PG 389

N 87°32'40" E
2492.96 (TOTAL)

1
1.322 AC.
N 88°10'43" E
243.82

2
1.105 AC.
N 2°27'20" W
291.94
3
1.106 AC.
N 2°27'20" W
291.94
4
1.106 AC.
N 2°27'20" W
291.94
5
1.005 AC.
N 2°27'20" W
291.94
6
1.005 AC.
N 2°27'20" W
291.94
7
1.005 AC.
N 2°27'20" W
291.94
8
1.005 AC.
N 2°27'20" W
291.94

20
1.141 AC.
N 88°10'43" E
243.51

18
1.182 AC.
NIP WITNESS SET
15' FROM PROPERTY
CORNER (TYP.)

17
1.161 AC.
N 2°27'20" W
284.52
16
1.135 AC.
N 2°27'20" W
284.56
15
1.135 AC.
N 2°27'20" W
284.60
14
1.121 AC.
N 2°27'20" W
284.63
13
1.121 AC.
N 2°27'20" W
284.67
12
1.121 AC.
N 2°27'20" W
284.70

1117.59 (TOT)
S 87°32'40" W
1116.92 (TOT)

LEGEND

- ECM = EXISTING CONCRETE MONUMENT
- EIP = EXISTING IRON PIPE
- EIS = EXISTING IRON STAKE
- NIP = NEW IRON PIPE
- NPK = NEW PK NAIL
- = NOT TO SCALE
- o = NO POINT SET

APPROXIMATE LOCATION OF THE 1% FLOOD
PLAIN LIMIT AS TAKEN FROM N.F.I.P. RATE
MAPS DATED MAY 15, 2003 COMMUNITY PANEL
3720656600J. BASE FLOOD ELEVATION = 7

GRAPHIC SCALE: 1" = 100'
0 50 100 200

REVISION	DATE	INIT.

DRAWN BY: WBH


PROJECT NO.: 20190222

SURVEYED BY: GDF/JAS

DATE: DATE

SCALE: 1" = 100'

DRAWING NAME: subd-mfr

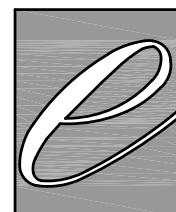


THE EAST GROUP

324 S. EVANS ST.
GREENVILLE, NC 27834
(252) 758-3746
CORPORATE LICENSE NO. C0206

4325 LAKE BOONE TRAIL SUITE 311
RALEIGH, NC 27607
(919) 784-9330

Engineering Architecture Surveying Technology

THIS DRAWING IS THE PROPERTY OF THE EAST GROUP, P.A. ANY USE, REUSE, REPRODUCTION, DISPLAY OR SALE OF THIS DRAWING WITHOUT WRITTEN CONSENT OF THE EAST GROUP, P.A. IS STRICTLY PROHIBITED.

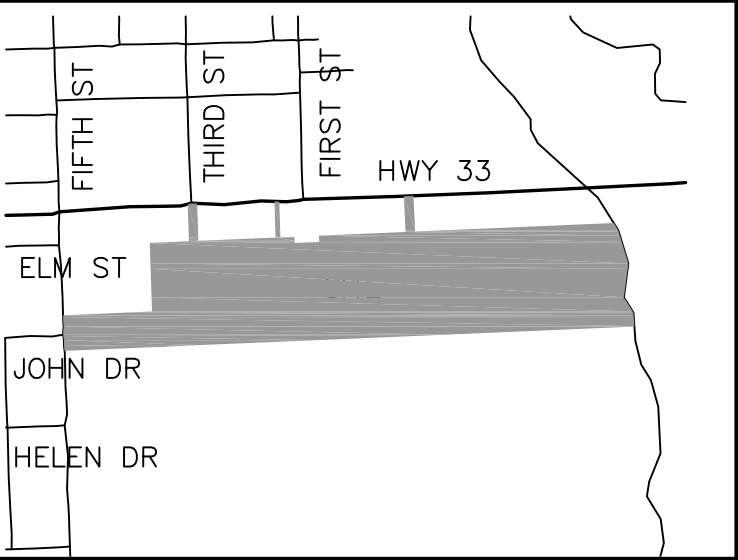

VICINITY MAP - NOT TO SCALE

I, CLIFF WILLIAMS, MAYOR OF THE TOWN OF AURORA, HEREBY CERTIFY THAT THAT THE TOWN OF AURORA IS THE OWNER OF THE PROPERTY SHOWN AND DESCRIBED HEREON, WHICH IS LOCATED IN THE SUBDIVISION JURISDICTION OF THE TOWN AND THAT THE TOWN OF AURORA HEREBY ADOPT THIS PLAN OF SUBDIVISION WITH ITS FREE CONSENT, ESTABLISHED MINIMUM BUILDING SETBACK LINES, AND DEDICATE ALL STREETS, ALLEYS, WALKS, PARKS, AND OTHER SITES AND EASEMENTS TO PUBLIC OR PRIVATE USE AS NOTED FURTHERMORE, THE TOWN OF AURORA HEREBY DEDICATE ALL SANITARY SEWER, STORM SEWER AND WATER LINES TO THE TOWN

CLIFF WILLIAMS, MAYOR
TOWN OF AURORA

I HEREBY CERTIFY THAT THE WATER SUPPLY AND SEWAGE DISPOSAL SYSTEMS INSTALLED OR PROPOSED FOR INSTALLATION IN THE TOWN OF AURORA INDUSTRIAL PARK SUBDIVISION MEET NECESSARY PUBLIC HEALTH REQUIREMENTS, AND ARE HEREBY APPROVED.

COUNTY HEALTH OFFICER OR
HIS AUTHORIZED REPRESENTATIVE

I HEREBY CERTIFY THAT THE SUBDIVISION PLAT SHOWN HEREON HAS BEEN FOUND TO COMPLY WITH THE SUBDIVISION REGULATIONS FOR AURORA, NORTH CAROLINA, AND THAT THIS PLAT HAS BEEN APPROVED BY THE TOWN BOARD OF COMMISSIONERS FOR RECORDING IN THE OFFICE OF THE REGISTER OF DEEDS OF BEAUFORT COUNTY.

TOWN CLERK FOR BOARD OF
COMMISSIONERS TOWN OF AURORA

STATE OF NORTH CAROLINA
PITT COUNTY
I, WILLIAM B. HILLIARD, CERTIFY THAT THIS PLAT WAS DRAWN UNDER MY SUPERVISION; (DEED DESCRIPTION RECORDED IN BOOK PAGE); THAT THE BOUNDARIES NOT SURVEYED ARE CLEARLY INDICATED AS DRAWN FROM INFORMATION FOUND IN BOOK PAGE ; THAT THE RATIO OF PRECISION AS CALCULATED IS 1:10,000+; THAT THIS PLAT WAS PREPARED IN ACCORDANCE WITH G.S. 47-30 AS AMENDED. WITNESS MY ORIGINAL SIGNATURE, LICENSE NUMBER AND SEAL THIS DAY OF MONTH , 2023.

I, BEAUFORT COUNTY, CERTIFY THAT THE MAP OR PLAT TO WHICH THIS CERTIFICATION IS AFFIXED MEETS ALL STATUTORY REQUIREMENTS FOR RECORDING.

REVIEW OFFICER


DATE

NC HIGHWAY 33
PUBLIC RIGHT-OF-WAY VARIES

AURORA VOLUNTEER FIRE DEPARTMENT
DB 913 PG 795

Parcel Line Table		
Line #	Length	Direction
L1	67.70	N 57°30'19" W

Curve Table					
Curve #	Length	Radius	Delta	Chord Direction	Chord Length
C1	14.34	15.00	54.77	N60° 09' 42"E	13.80
C2	120.75	63.00	109.82	S87° 41' 12"W	103.10
C3	76.86	63.00	69.90	N2° 27' 19"W	72.18
C4	71.45	63.00	64.98	N83° 29' 34"E	67.68
C5	28.95	63.00	26.33	S50° 51' 15"E	28.70
C6	14.34	15.00	54.77	N65° 04' 22"W	13.80
C7	20.35	63.00	18.51	N41° 44' 58"E	20.26

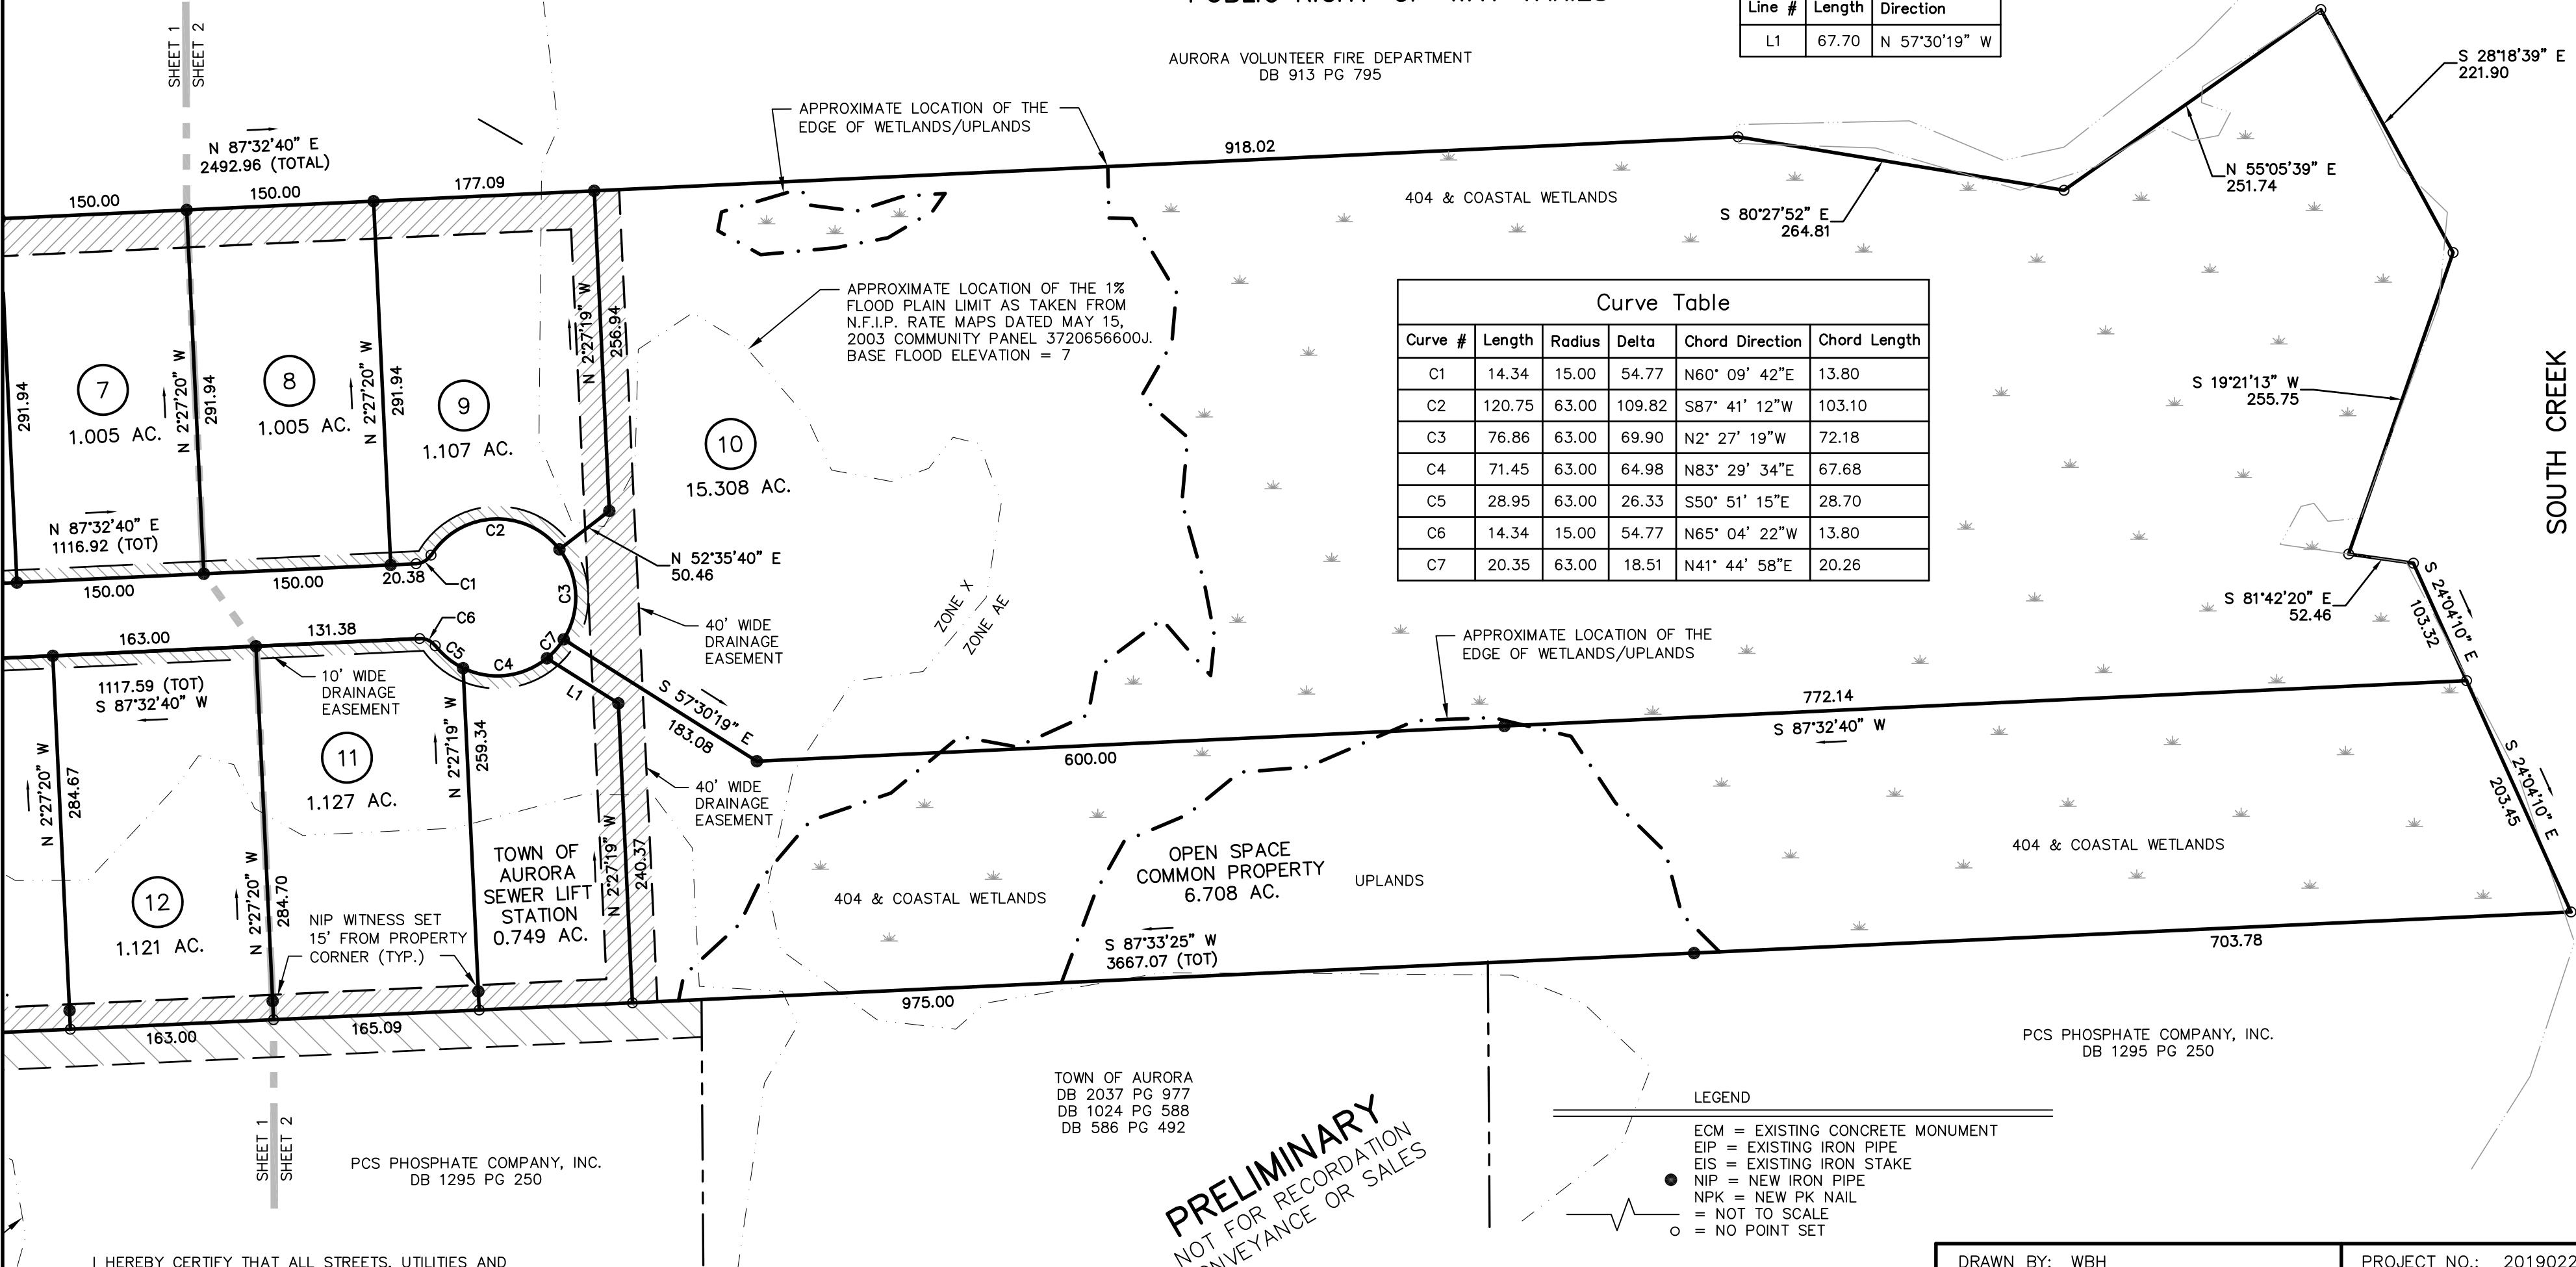

TOWN OF AURORA
DB 2037 PG 977
DB 1024 PG 588
DB 586 PG 492

PCS PHOSPHATE COMPANY, INC.
DB 1295 PG 250

PRELIMINARY
NOT FOR RECORDATION
CONVEYANCE OR SALES

LEGEND

- ECM = EXISTING CONCRETE MONUMENT
- EIP = EXISTING IRON PIPE
- EIS = EXISTING IRON STAKE
- NIP = NEW IRON PIPE
- NPK = NEW PK NAIL
- = NOT TO SCALE
- o = NO POINT SET

I HEREBY CERTIFY THAT ALL STREETS, UTILITIES AND OTHER REQUIRED IMPROVEMENTS HAVE BEEN INSTALLED IN AN ACCEPTABLE MANNER AND ACCORDING TO TOWN SPECIFICATIONS AND STANDARDS IN THE TOWN OF AURORA INDUSTRIAL PARK SUBDIVISION OR THAT GUARANTEES OF THE INSTALLATION OF THE REQUIRED IMPROVEMENTS IN AN AMOUNT AND MANNER SATISFACTORY TO THE TOWN HAS BEEN RECEIVED, AND THAT THE FILING FEE FOR THIS PLAT, IN THE AMOUNT OF \$ HAS BEEN PAID.

TOWN CLERK
DATE

SHEET 2 OF 2
FINAL PLAT
OF THE
TOWN OF AURORA
INDUSTRIAL PARK


RICHLAND TOWNSHIP
BEAUFORT COUNTY

DATE
NORTH CAROLINA

GRAPHIC SCALE: 1" = 100'

REVISION	DATE	INIT.

DRAWN BY: WBH	PROJECT NO.: 20190222
SURVEYED BY: GDF/JAS	DATE: DATE
SCALE: 1" = 100'	DRAWING NAME: subd-mfr

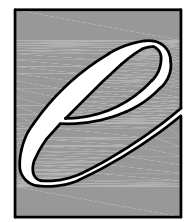


THE EAST GROUP

324 S. EVANS ST.
GREENVILLE, NC 27834
(252) 758-3746
CORPORATE LICENSE NO. C0206

4325 LAKE BOONE TRAIL SUITE 311
RALEIGH, NC 27607
(919) 784-9330

■ Engineering ■ Architecture ■ Surveying ■ Technology

THIS DRAWING IS THE PROPERTY OF THE EAST GROUP, P.A. ANY USE, REUSE, REPRODUCTION, DISPLAY OR SALE OF THIS DRAWING WITHOUT WRITTEN CONSENT OF THE EAST GROUP, P.A. IS STRICTLY PROHIBITED.

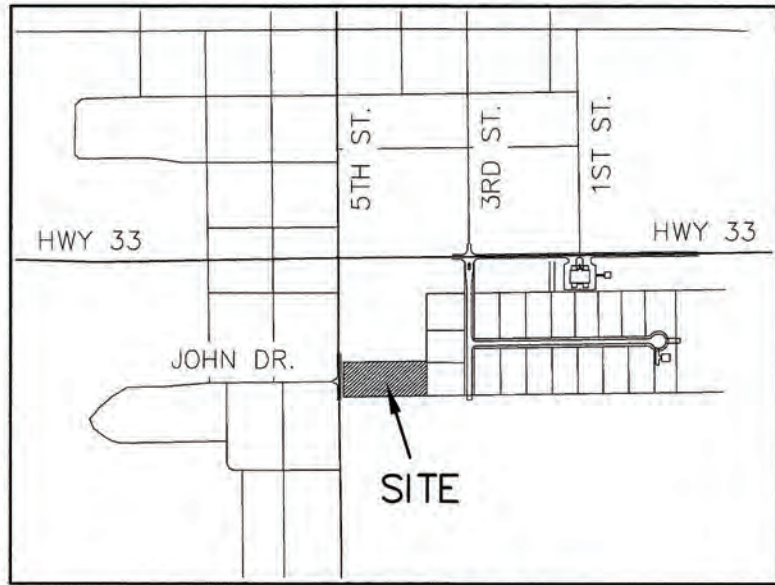

VICINITY MAP
NOT TO SCALE

NCSR 1925 –
S. FIFTH STREET
(60' PUBLIC RIGHT-OF-WAY)

JOHN DRIVE
(50' PUBLIC R/W)

SHEET INDEX

- | | |
|------|----------------|
| C1.0 | COMPOSITE PLAN |
| C1.1 | SITE PLAN |
| C2.1 | GRADING PLAN |
| C3.1 | UTILITY PLAN |
| C4.1 | DETAILS |
| C5.1 | DETAILS |
| C6.1 | NOTES |

NOTE:

1. THIS PROPERTY IS LOCATED IN FLOOD ZONE X AND IS SHOWN HEREON AS TAKEN FROM N.F.I.P. RATE MAP DATED 6/19/2020 COMMUNITY PANEL NUMBER 3720654600K AND N.F.I.P. RATE MAP DATED 6/19/2020 COMMUNITY PANEL NUMBER 3720656600K.

MATERIALS KEYING LEGEND

SITE DATA:


TOTAL ACREAGE.....2.71 AC.
ZONING.....6567000970
PIN NO.....49416
OWNER NAME.....TRUSTEES OF THE BEAUFORT COUNTY COMMUNITY COLLEGE
OWNER ADDRESS.....PO BOX 4808
CITY/ STATE/ ZIP.....WASHINGTON, NC 27889
PROPERTY DESC.....LOT 19 TOWN OF AURORA INDUSTRIAL PARK
PROPERTY ADDRESS.....S. FIFTH STREET
TOWNSHIP.....13
DEED BOOK/ PAGE.....DB 2162 PG 479
PROPOSED BLDG. FOOTPRINT.....5,006 SF
BUILDING HEIGHT.....27 FT
BUILDING LOT COVERAGE.....0.04%
IMPERVIOUS AREA
EXISTING.....0.00 AC.
PROPOSED.....0.56 AC.
% IMPERVIOUS.....20.66%
PARKING SPACES
REGULAR SPACES.....17
HC SPACES.....2
DISTURBED AREA.....1.99 AC.

GENERAL NOTES



•Engineering•Architecture•Surveying•Technology
324 Evans St., Greenville, NC 27838 (252) 758-3148 (252) 830-3554 (Fax)
4325 Lake Boone Trail, Suite 311, Raleigh, NC 27607 (919) 784-8330 (919) 784-8331 (Fax)
•NC Engineering License No. C-0206 • NC Architectural License No. 50213
• NC Landscape Architectural License No. C-027

KEY PLAN

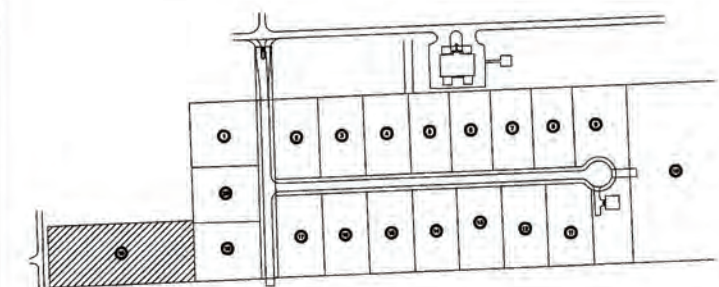

SCO ID #23-27044-01A

NO REVISION

DATE

SEAL



J K F

ARCHITECTURE

425 LYNDALE CT., SUITE F, GREENVILLE, NC 27838 252-355-1068

BEAUFORT COUNTY
COMMUNITY COLLEGE
INDUSTRIAL TRAINING CENTER
AURORA, NC

DRAWING TITLE

COMPOSITE PLAN

SCALE

AS NOTED

DRAWN

SLJ

CHECKED

MSC

DATE

1-6-2025

PROJECT NO.

 
20240128


C1.0

© COPYRIGHT, JKF ARCHITECTURE PC, JOHN K. PARKS, AIA



1"=30'-0"



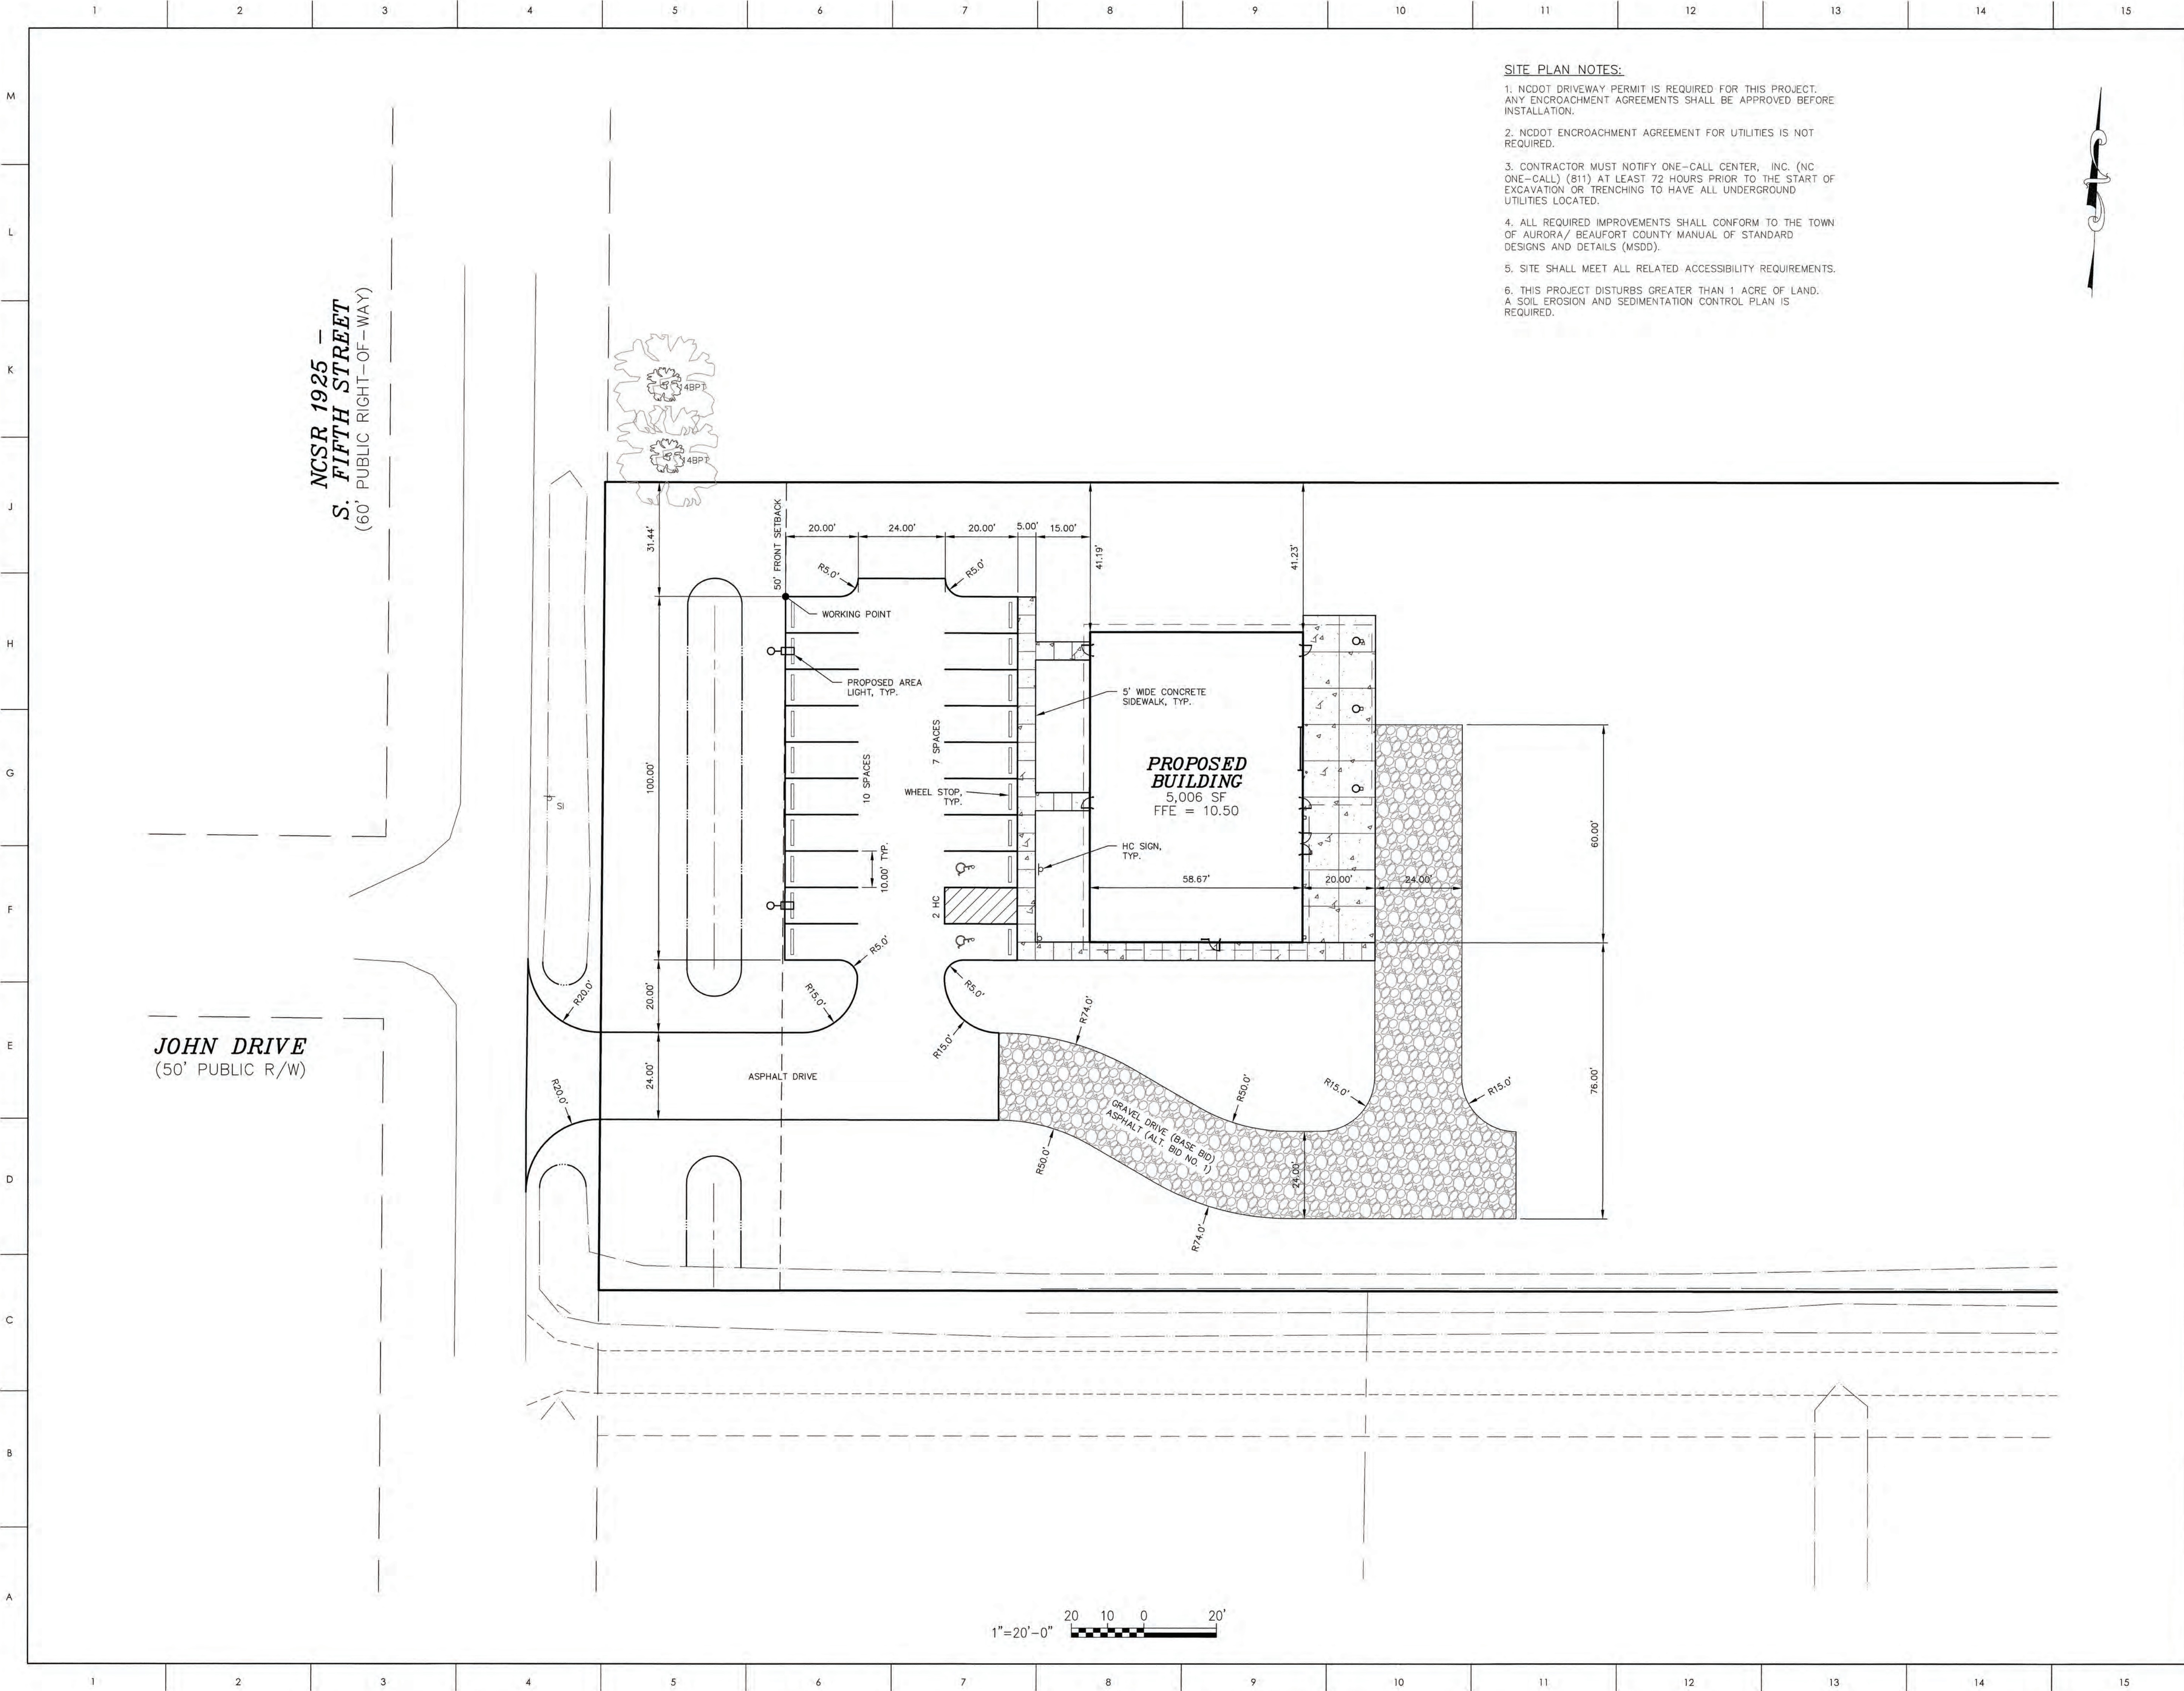

- SITE PLAN NOTES:**
1. NCDOT DRIVEWAY PERMIT IS REQUIRED FOR THIS PROJECT. ANY ENCROACHMENT AGREEMENTS SHALL BE APPROVED BEFORE INSTALLATION.
 2. NCDOT ENCROACHMENT AGREEMENT FOR UTILITIES IS NOT REQUIRED.
 3. CONTRACTOR MUST NOTIFY ONE-CALL CENTER, INC. (NC ONE-CALL) (811) AT LEAST 72 HOURS PRIOR TO THE START OF EXCAVATION OR TRENCHING TO HAVE ALL UNDERGROUND UTILITIES LOCATED.
 4. ALL REQUIRED IMPROVEMENTS SHALL CONFORM TO THE TOWN OF AURORA/ BEAUFORT COUNTY MANUAL OF STANDARD DESIGNS AND DETAILS (MSDD).
 5. SITE SHALL MEET ALL RELATED ACCESSIBILITY REQUIREMENTS.
 6. THIS PROJECT DISTURBS GREATER THAN 1 ACRE OF LAND. A SOIL EROSION AND SEDIMENTATION CONTROL PLAN IS REQUIRED.

MATERIALS KEYING LEGEND

LEGEND

FFE = FINISH FLOOR ELEVATION
HC = HANDICAP
R = RADIUS
SF = SQUARE FOOTAGE
SI = SIGN

GENERAL NOTES

THE EAST GROUP, P.A.

•Engineering•Architecture•Surveying•Technology

324 Evans St., Greenville, NC 27838 (252) 758-3748 (252) 830-3554 (Fax)
4325 Lake Boone Trail, Suite 311, Raleigh, NC 27607 (919) 784-8330 (919) 784-8331 (Fax)
•NC Engineering License No. C-0208 • NC Architectural License No. 50213
• NC Landscape Architectural License No. C-427

KEY PLAN

SCO ID #23-27044-01A

NO.	REVISION	DATE

Michael J. Clements
Professional Engineer
North Carolina
License No. 029422

J K F

ARCHITECTURE

625 LYNDALE CT., SUITE F, GREENVILLE, NC 27658 252-355-1068


BEAUFORT COUNTY COMMUNITY COLLEGE INDUSTRIAL TRAINING CENTER
AURORA, NC

DRAWING TITLE

SITE PLAN

SCALE	DRAWING NO.	
AS NOTED	C1.1	
DRAWN		SLJ
CHECKED		MSC
DATE		1-6-2025
PROJECT NO.	20240128	

© COPYRIGHT, JKF ARCHITECTURE PC, JOHN K. PARKAS, AIA

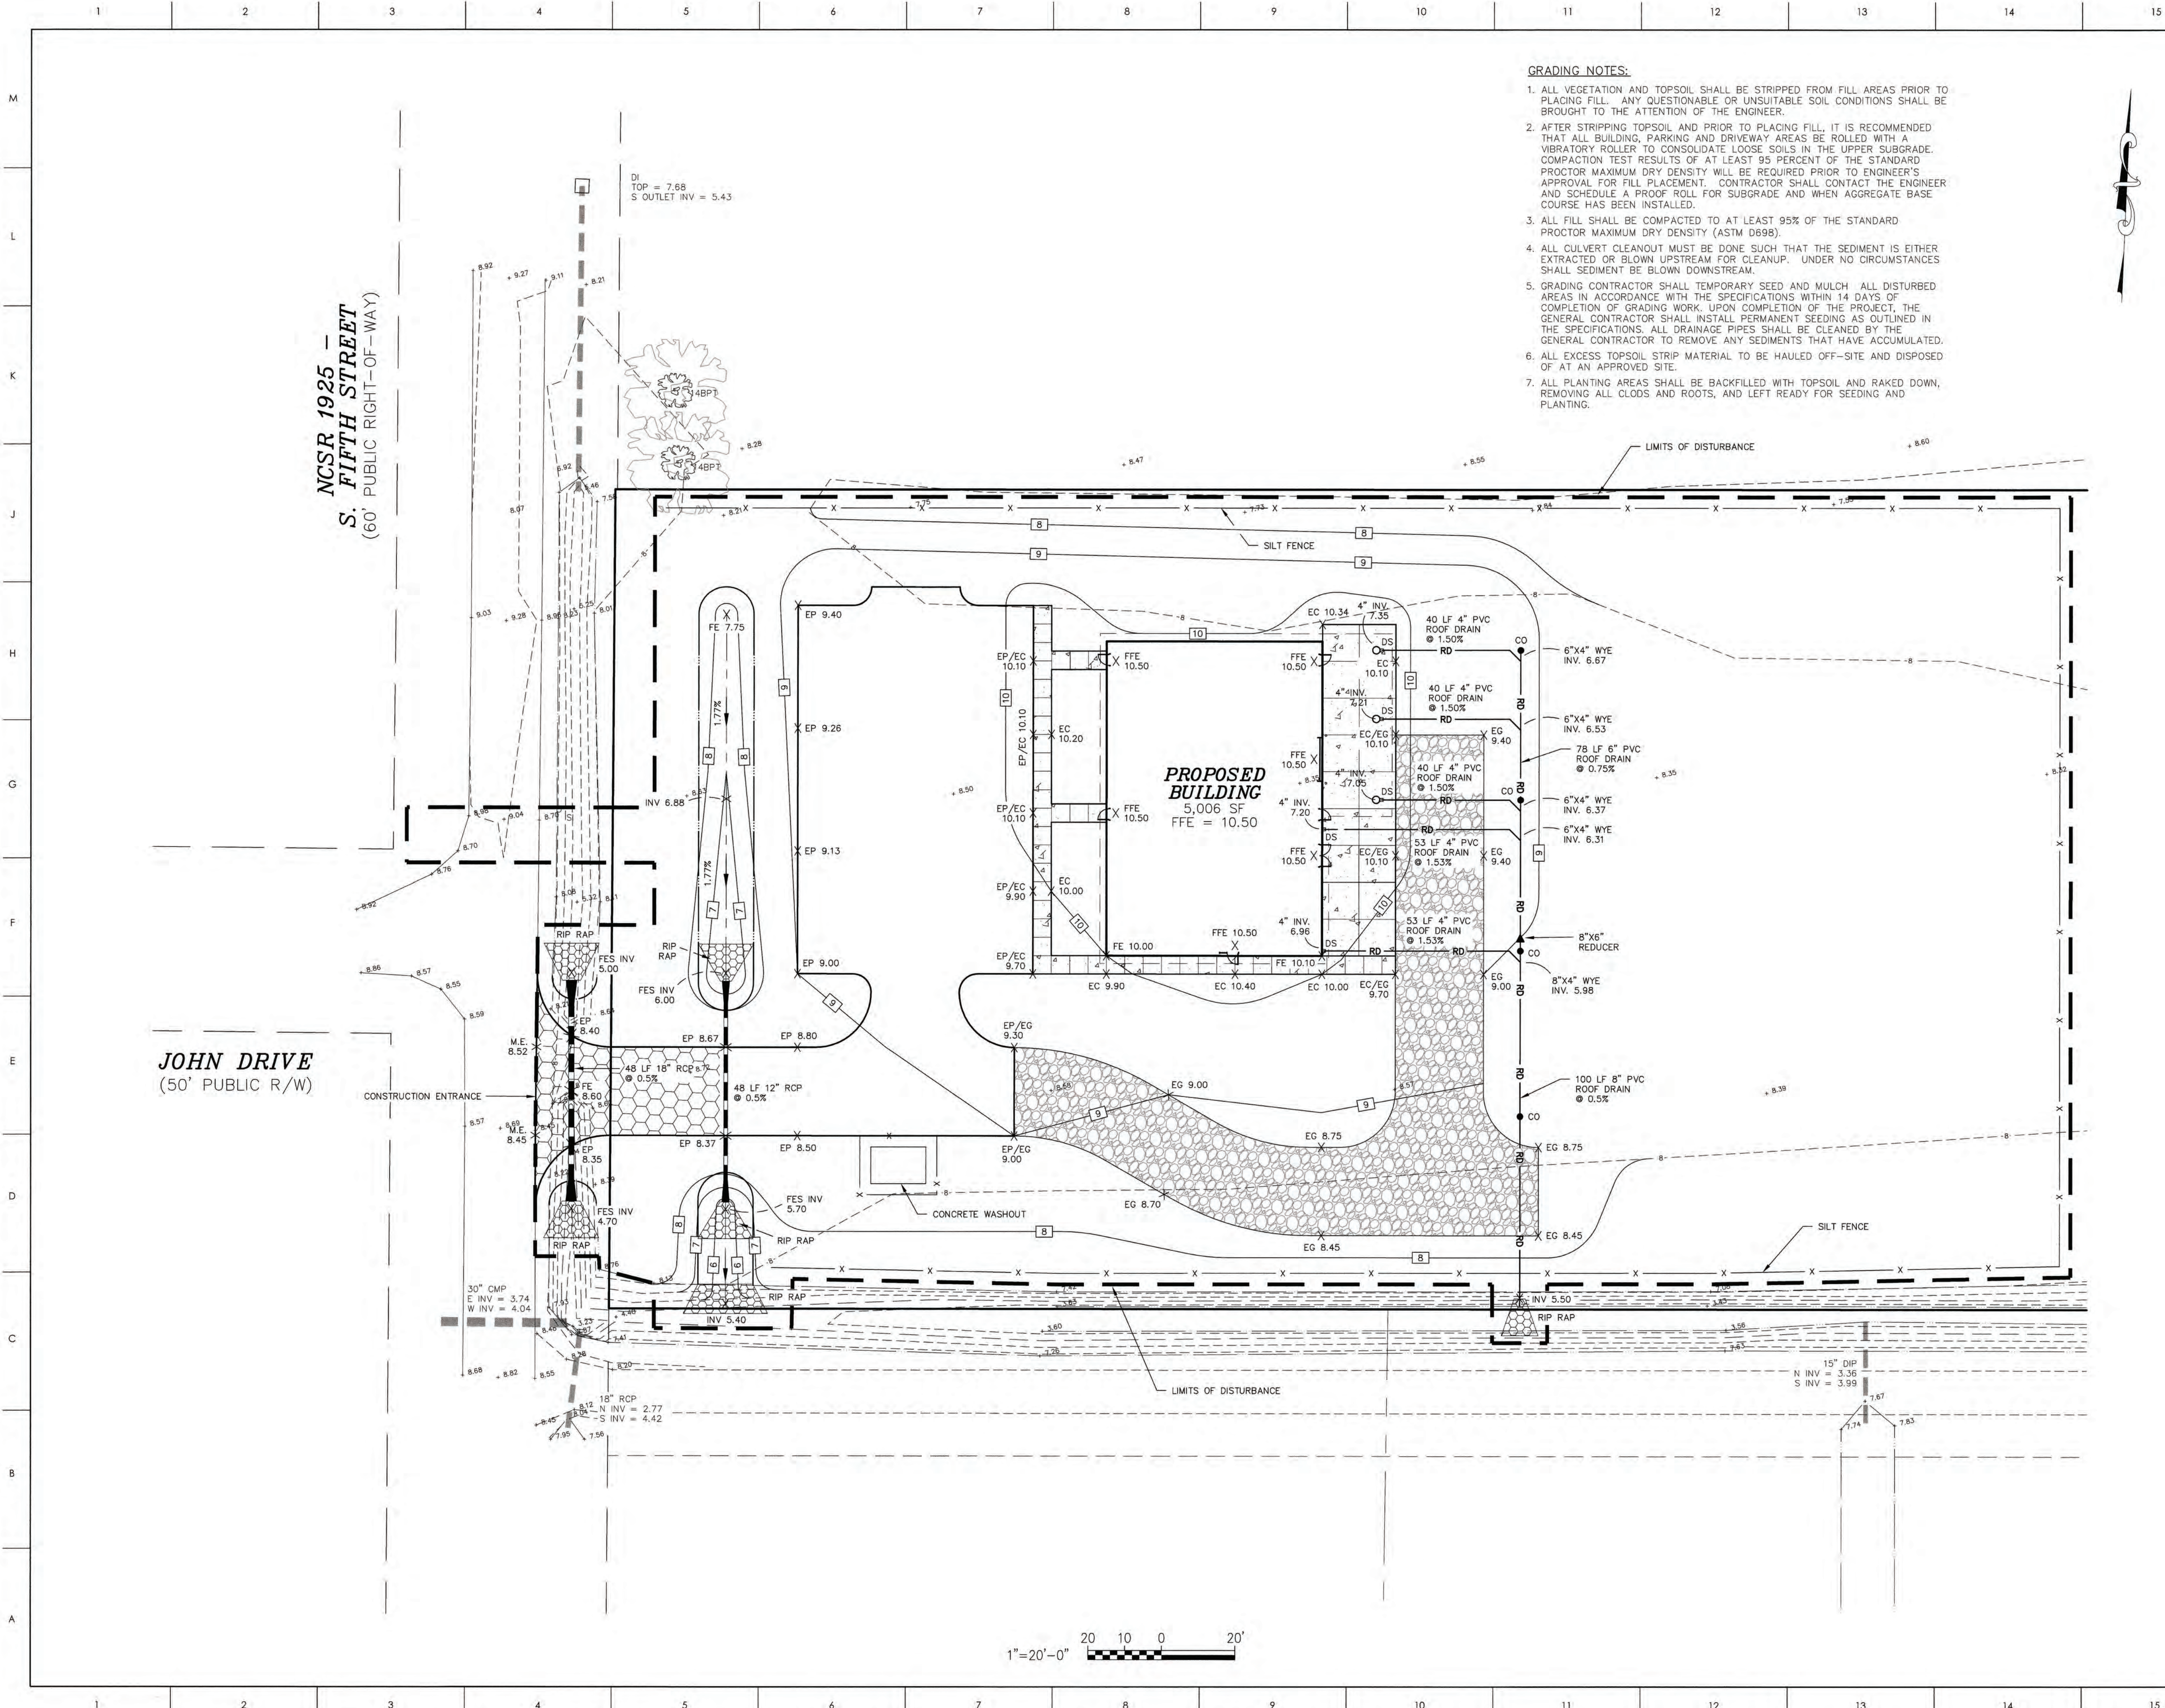

MATERIALS KEYING LEGEND


LEGEND	
CMP	= CORRUGATED METAL PIPE
CO	= CLEAN OUT
EC	= EDGE OF CONCRETE
EG	= EDGE OF GRAVEL
EP	= EDGE OF PAVEMENT
EX	= EXISTING
FE	= FINISHED ELEVATION
FES	= FLARED END SECTION
FFE	= FINISH FLOOR ELEVATION
INV.	= INVERT
LF	= LINEAR FEET
M.E.	= MATCH EXISTING
RCP	= REINFORCED CONCRETE PIPE
EX. SPOT ELEVATION	
EXISTING CONTOUR	
EX. STORM DRAIN	
PROPOSED STORM DRAIN	
9	PROPOSED CONTOUR
RD	PROPOSED ROOF DRAIN
X	SILT FENCE

GENERAL NOTES



Engineering Architecture Surveying Technology
324 Evans St., Greenville, NC 27838 (252) 758-3146 (252) 820-3564 (Fax)
4352 Lake Boone Trail, Suite 311, Raleigh, NC 27607 (919) 784-3330 (919) 784-8331 (Fax)
NC Engineering License No. C-0206 NC Architectural License No. 50213
NC Landscape Architectural License No. C-427

KEY PLAN

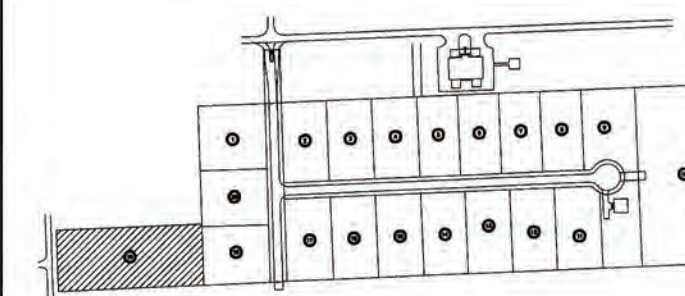

SCO ID #23-27044-01A

NO REVISION

DATE

SEAL



JKF
ARCHITECTURE

Michael J. Clements
Professional Engineer
License No. 029422
08/25/2017-08/25/2027

825 LYNDALE CT., SUITE F, GREENVILLE, NC 27858 252-355-1068

BEAUFORT COUNTY
COMMUNITY COLLEGE
INDUSTRIAL TRAINING CENTER
AURORA, NC

DRAWING TITLE

GRADING PLAN

SCALE

AS NOTED

DRAWN

SLJ

CHECKED

MSC

DATE


1-6-2025

PROJECT NO.

20240128

DRAWING NO.

C2.1

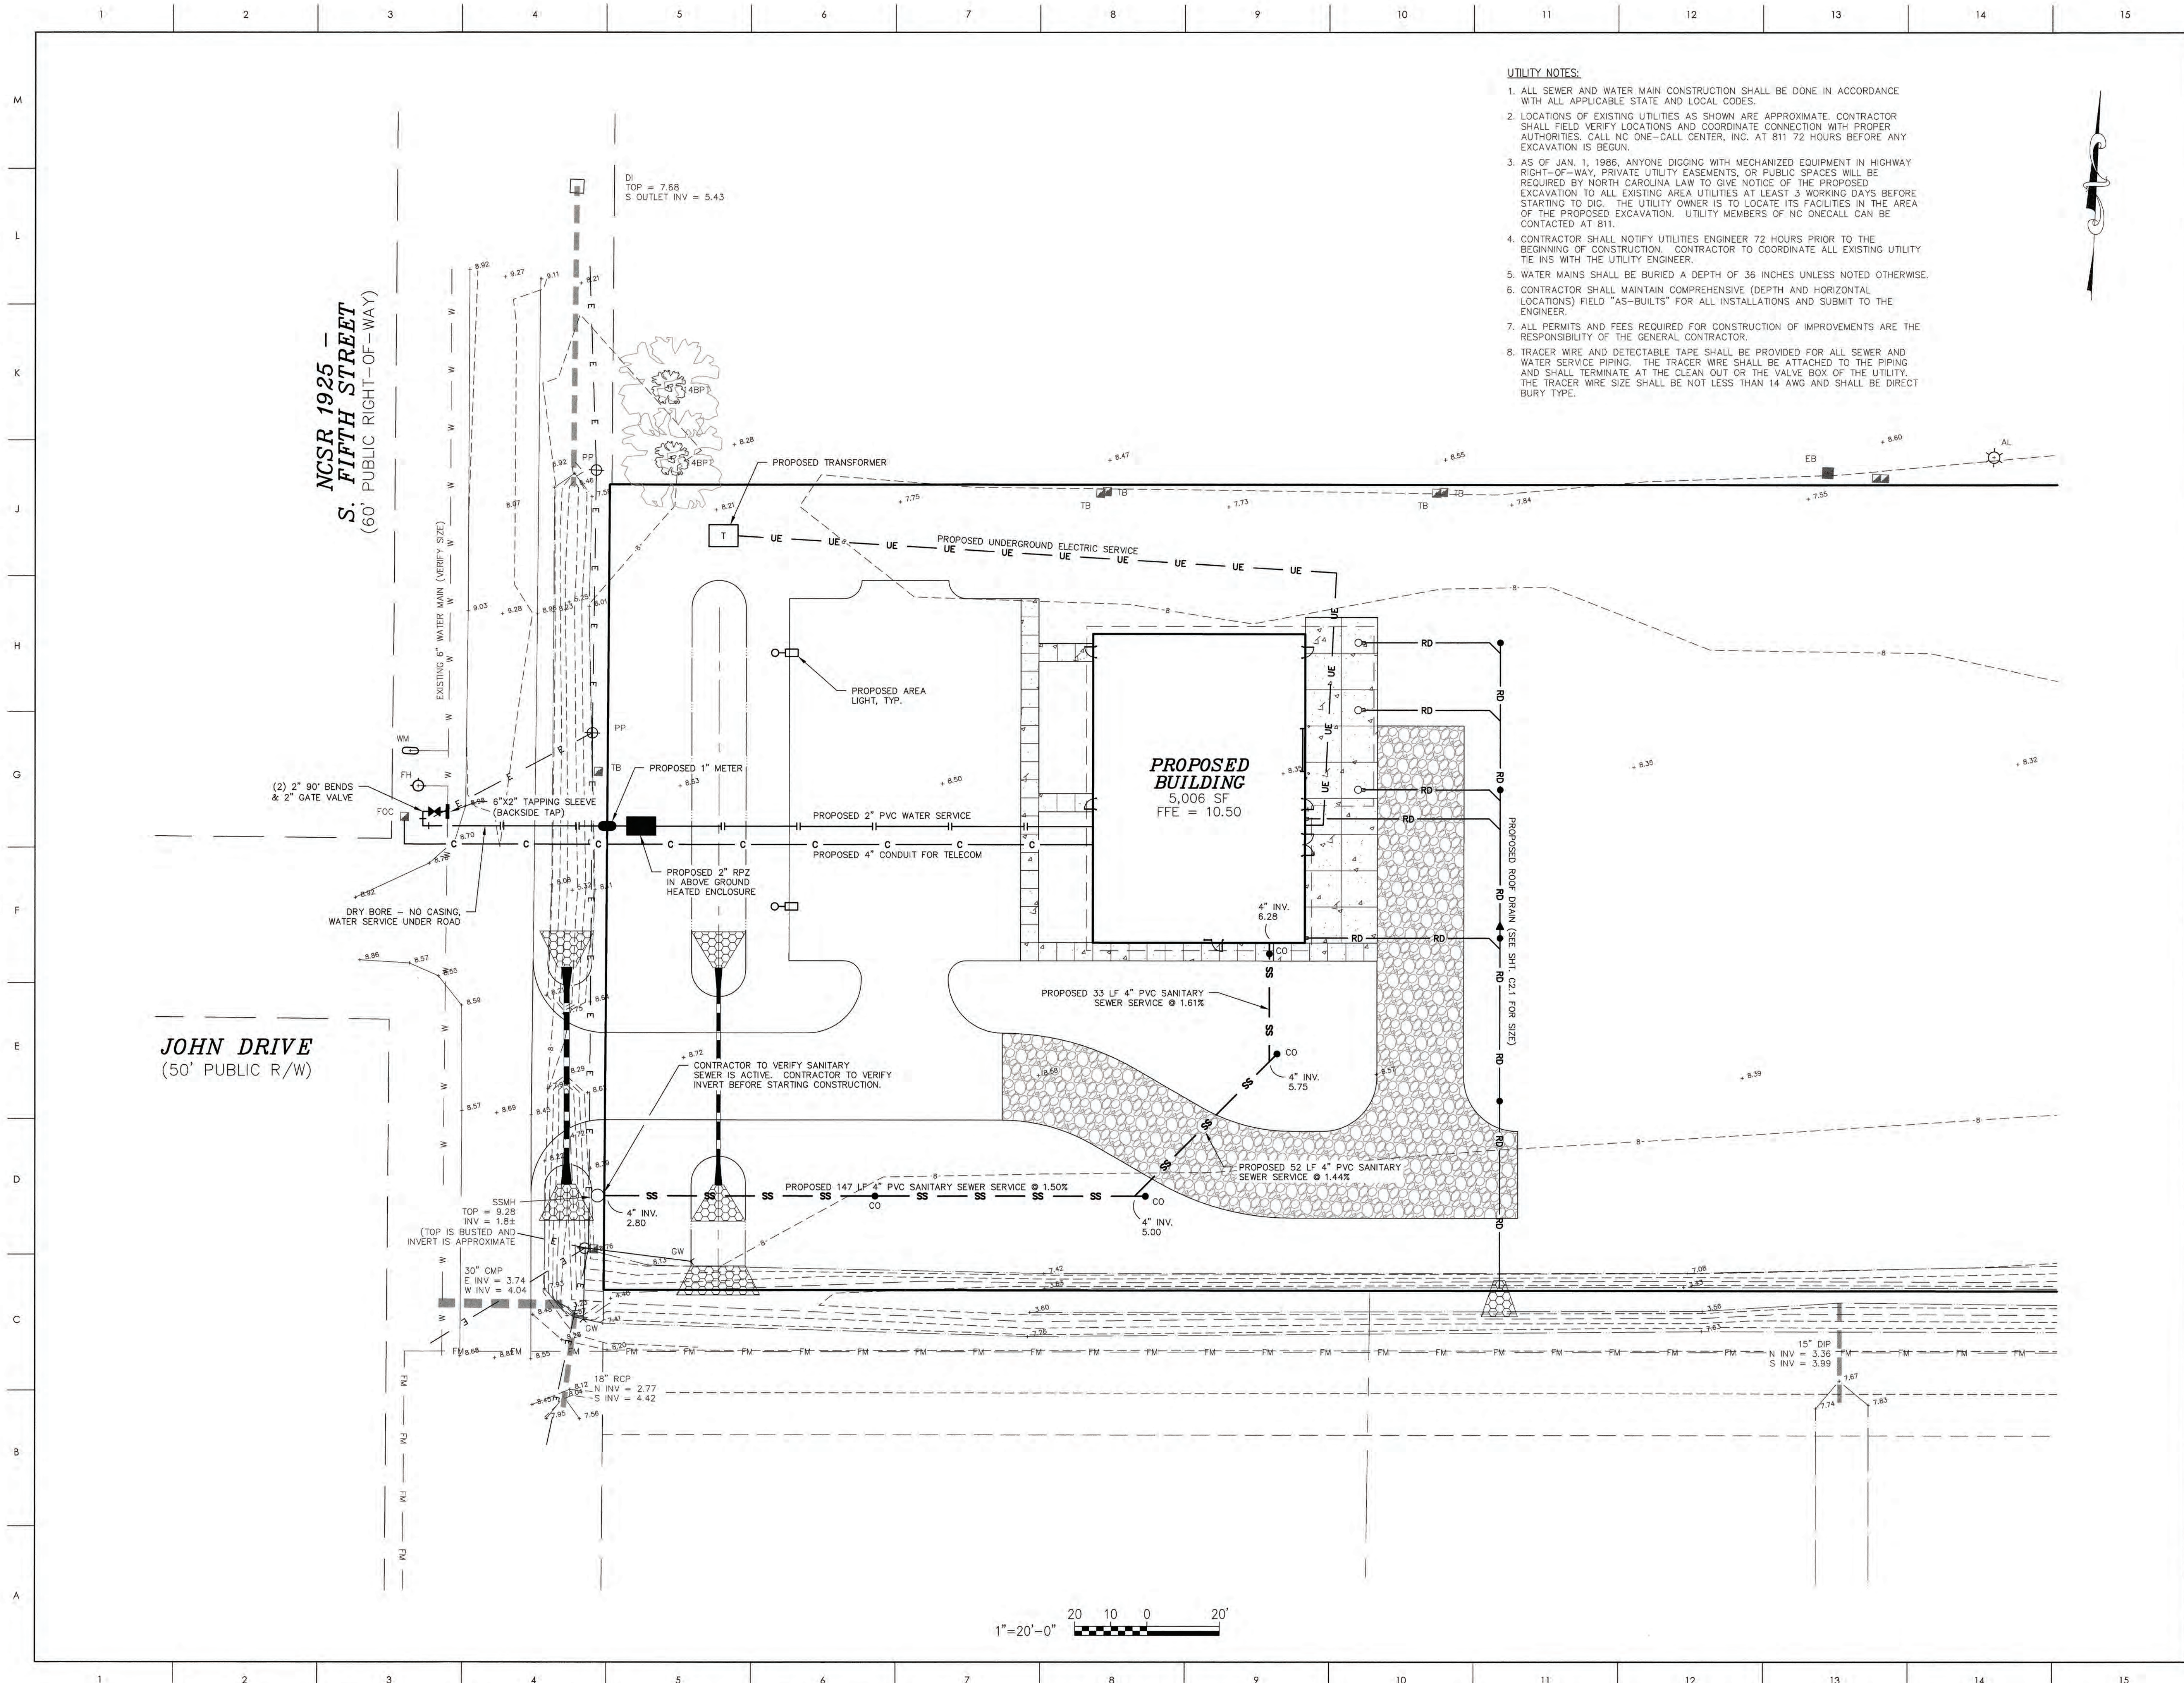

MATERIALS KEYING LEGEND

LEGEND


MP = CORRUGATED METAL PIPE
OC = CLEAN OUT
X = EXISTING
FE = FINISH FLOOR ELEVATION
H = FIRE HYDRANT
OC = FIBER OPTIC CABLE
W = GUY WIRE
I = INVERT
F = LINEAR FEET
P = POWER POLE
CP = REINFORCED CONCRETE PIPE
SMH = SANITARY SEWER MANHOLE
B = TELEPHONE BOX
M = WATER METER
X = SPOT ELEVATION
X = EXISTING CONTOUR
X = STORM DRAIN
ROPOSED STORM DRAIN
ROPOSED ROOF DRAIN
X = STORM MAIN
ROPOSED WATER MAIN
X = FORCE MAIN
ROPOSED SANITARY SEWER SERVICE
X = OVERHEAD ELECTRIC
ROPOSED UNDERGROUND ELECTRIC
ROPOSED CONDUIT

GENERAL NOTES



■Engineering ■Architecture ■Surveying ■Technology
 324 Evans St., Greenville, NC 27858 (252) 758-3746 (252) 830-3954 (Fax)
 4325 Lake Boone Trail, Suite 311, Raleigh, NC 27607 (919) 784-9330 (919) 784-9331 (Fax)
 ■ NC Engineering License No. C-0206 ■ NC Architectural License No. 50213
 ■ NC Landscape Architectural License No. C-427

KEY PLAN

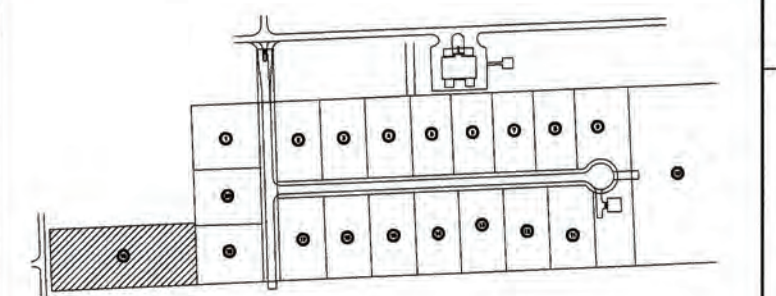

SCO ID #23-27044-01A

NO	REVISION	DATE
----	----------	------




 ENGINEER
 Michelle's Clements
 State of Michigan
 License No. 9025.01.27
 Exp. Date 09-30-23
 Commission No. 09-34:53-05'00'

ARCHITECTURE

625 LYNNDAL CT., SUITE F, GREENVILLE, NC 27858 252-355-1068

BEAUFORT COUNTY
COMMUNITY COLLEGE
INDUSTRIAL TRAINING CENTER
AURORA, NC

DRAWING TITLE:

UTILITY PLAN

© 2006 The Authors
Journal compilation © 2006 Blackwell Publishing Ltd

SCALE	DRAWING NO
AS NOTED	

NO NOTED	
DRAWN	SLI


CHECKED	MSC	C31
---------	-----	-----

DATE	MSC	CS.1
------	-----	------


1-6-2025	
PROJECT NO.	

20240128

COPYRIGHT, JKF ARCHITECTURE PC, JOHN K. FARKAS, AIA

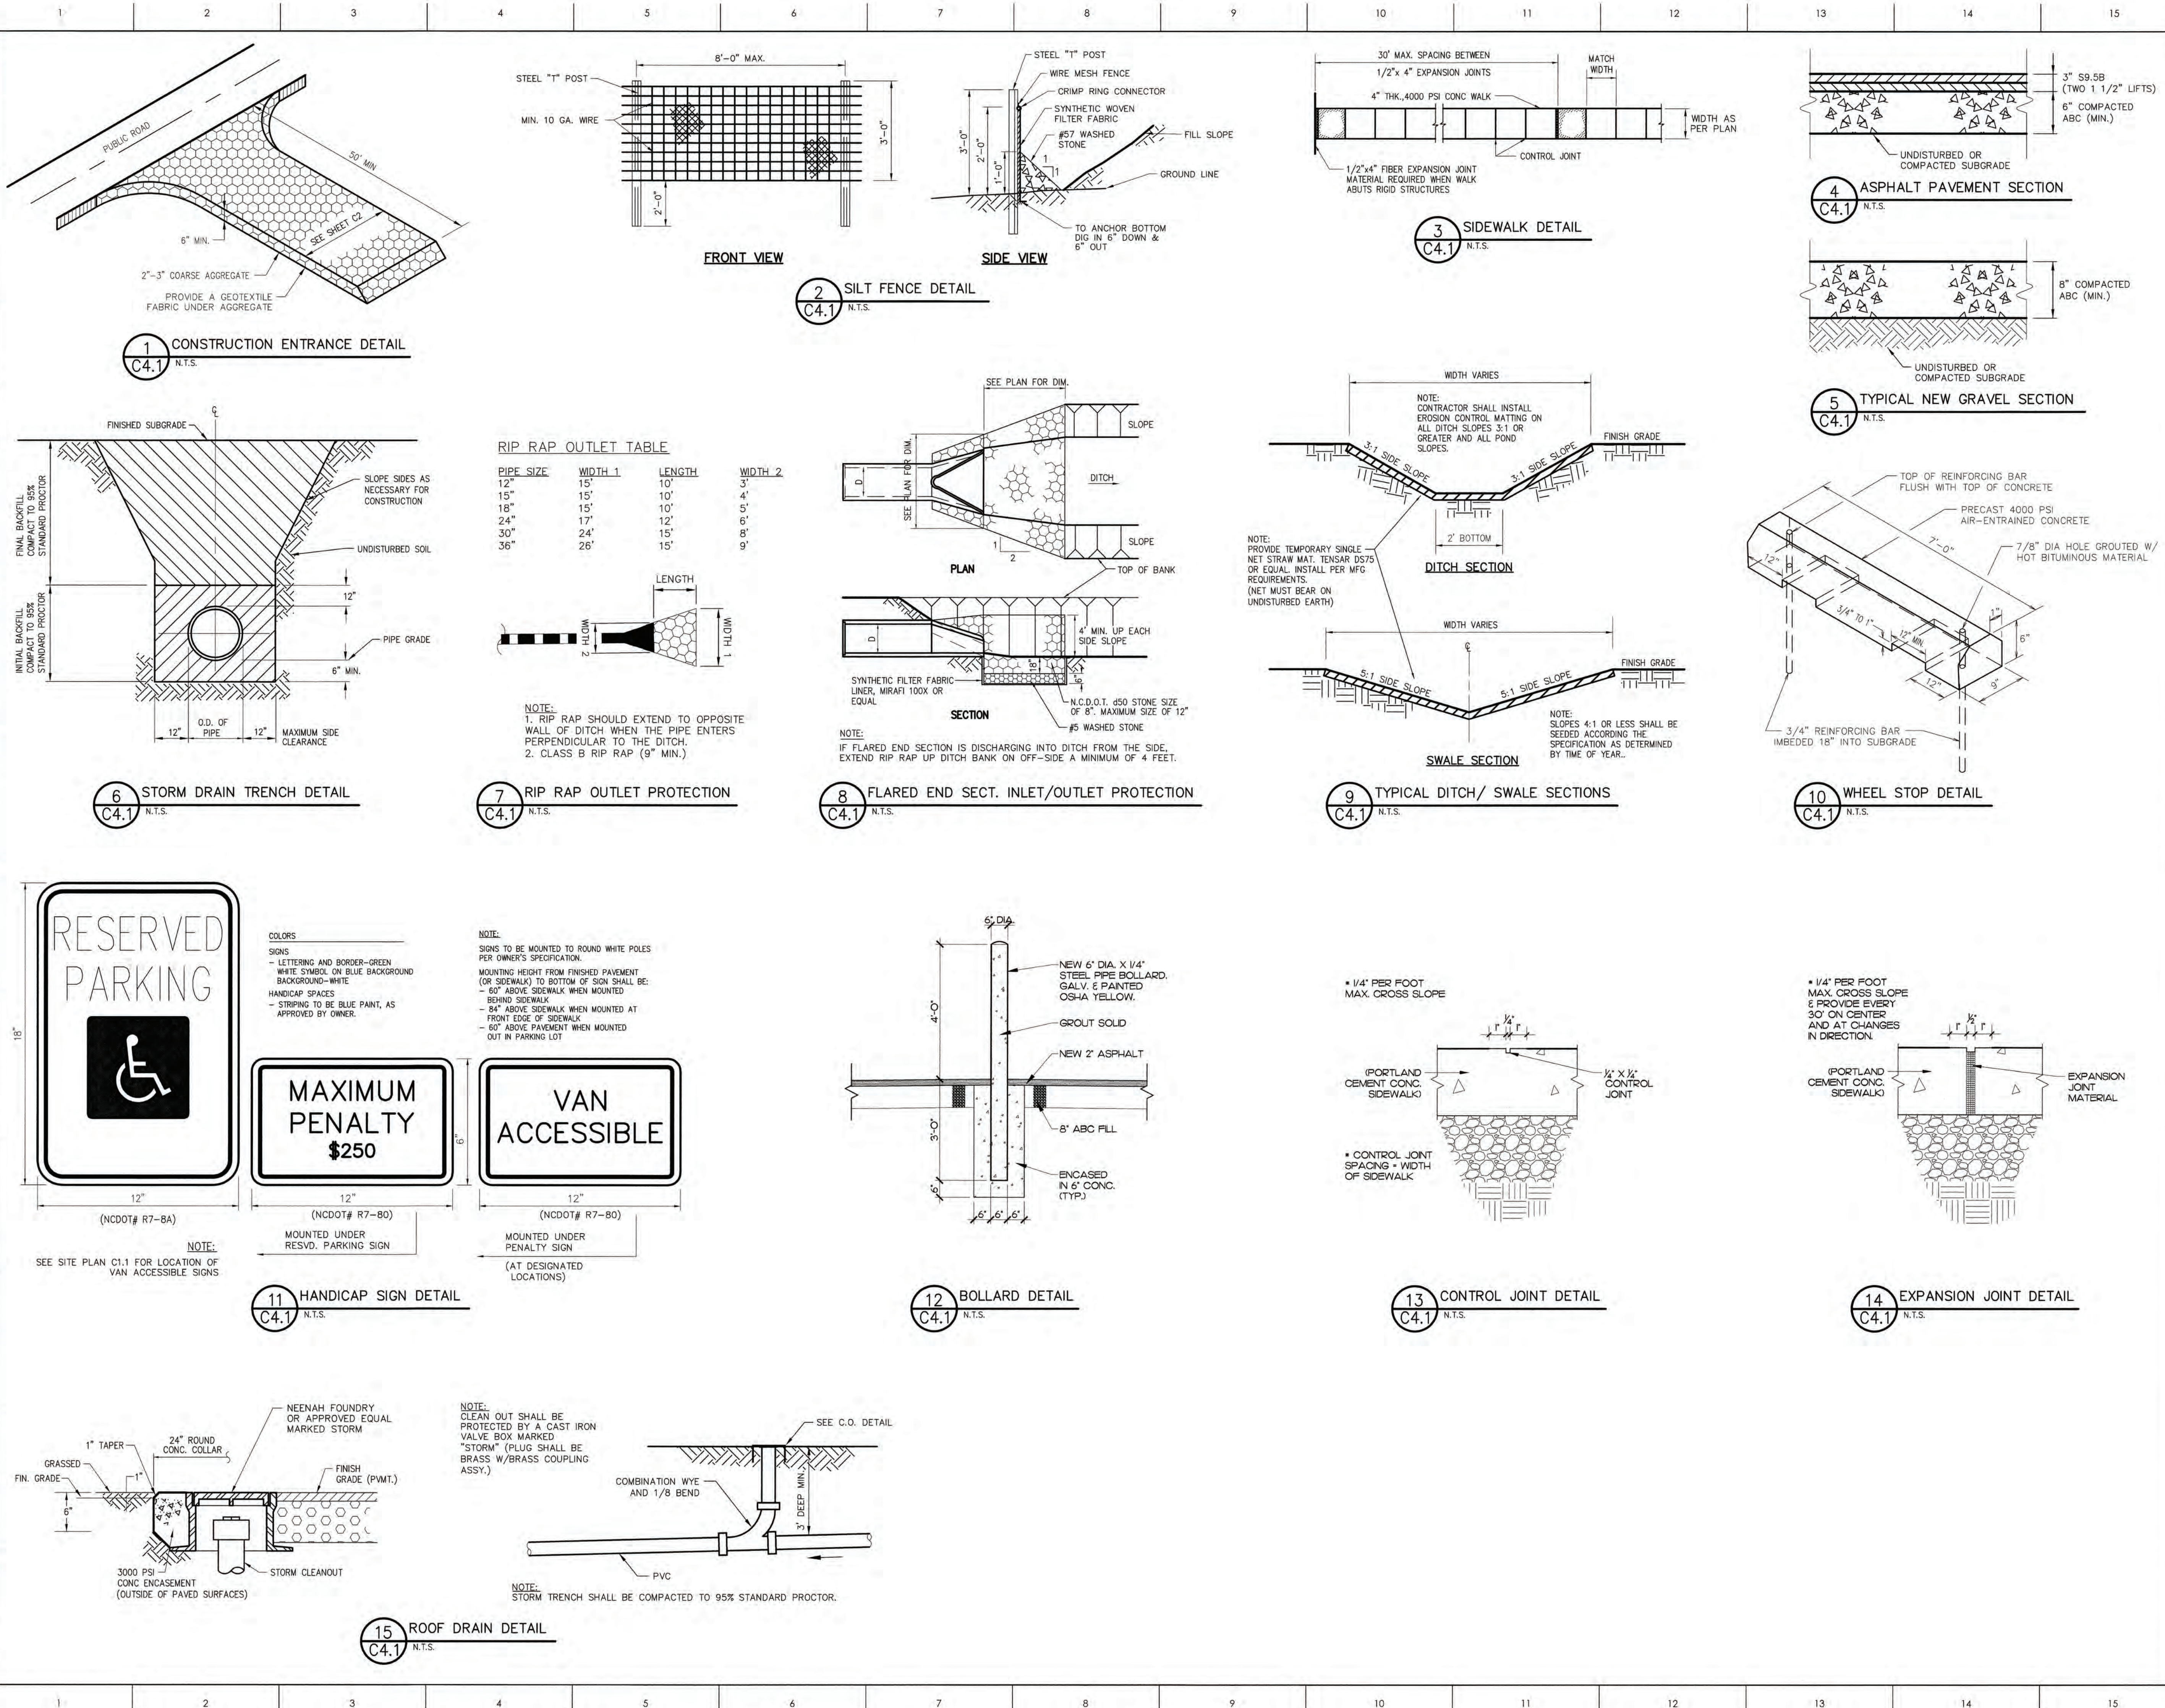

MATERIALS KEYING LEGEND

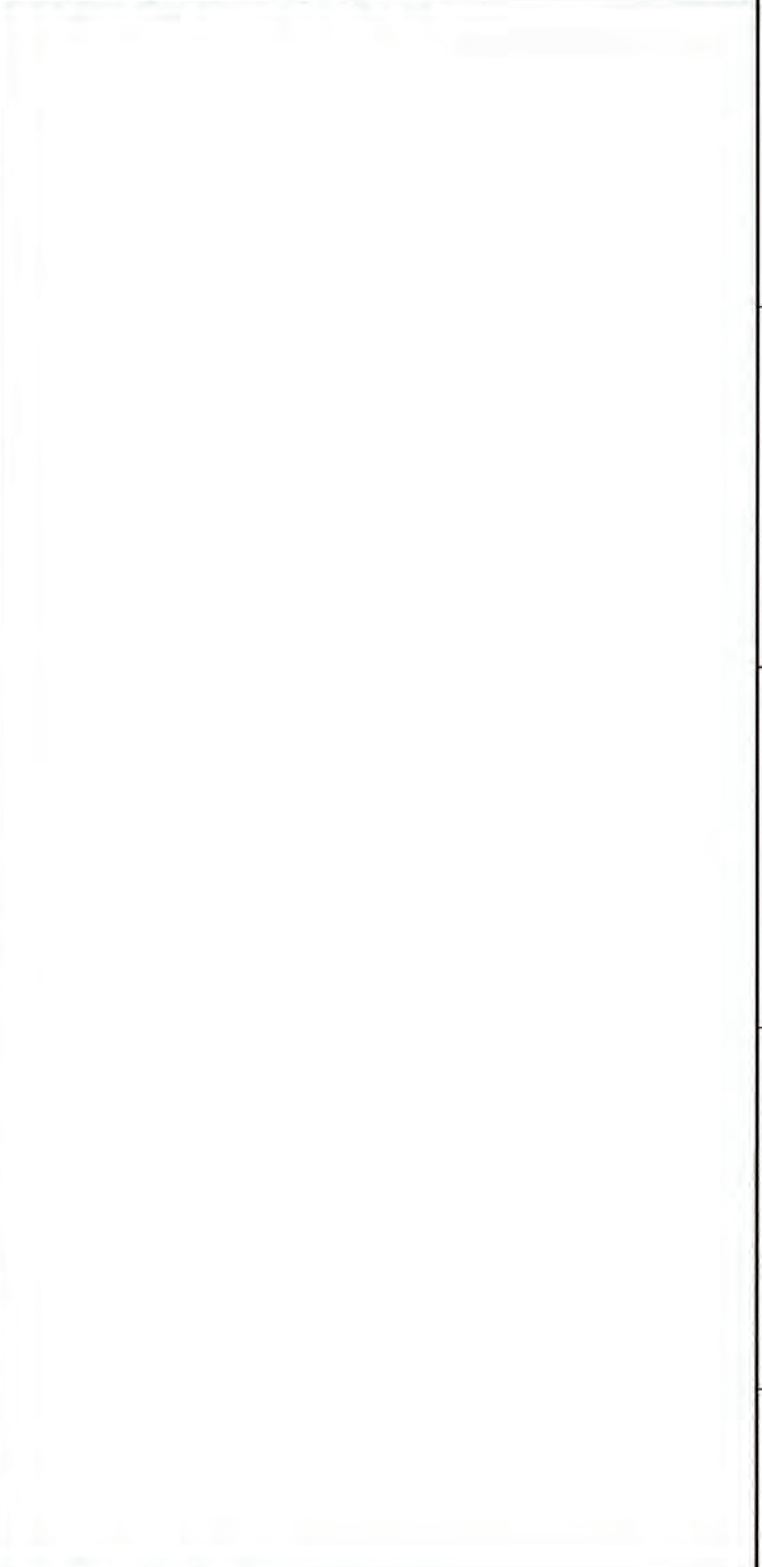

GENERAL NOTES

THE EAST GROUP, P.A.


•Engineering•Architecture•Surveying•Technology

324 Evans St., Greenville, NC 27858 (252) 758-1746 (252) 830-3554 (Fax)

4325 Lake Boone Trail, Suite 301, Raleigh, NC 27607 (919) 784-8330 (919) 784-9331 (Fax)

•NC Engineering License No. C-0208 • NC Architectural License No. 50213

• NC Landscape Architectural License No. C-427

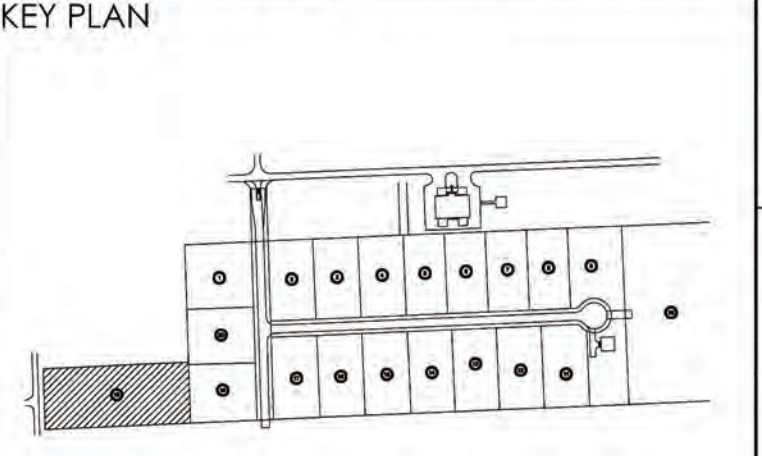

SCO ID #23-27044-01A

NO	REVISION	DATE

JKF

ARCHITECTURE


625 LYNDALE CT., SUITE F, GREENVILLE, NC 27858 252-355-1068

BEAUFORT COUNTY
COMMUNITY COLLEGE
INDUSTRIAL TRAINING CENTER
AURORA, NC

DRAWING TITLE

DETAILS

SCALE	AS NOTED	DRAWING NO.
DRAWN	SLJ	C4.1
CHECKED	MSC	
DATE	1-6-2025	
PROJECT NO.	20240128	

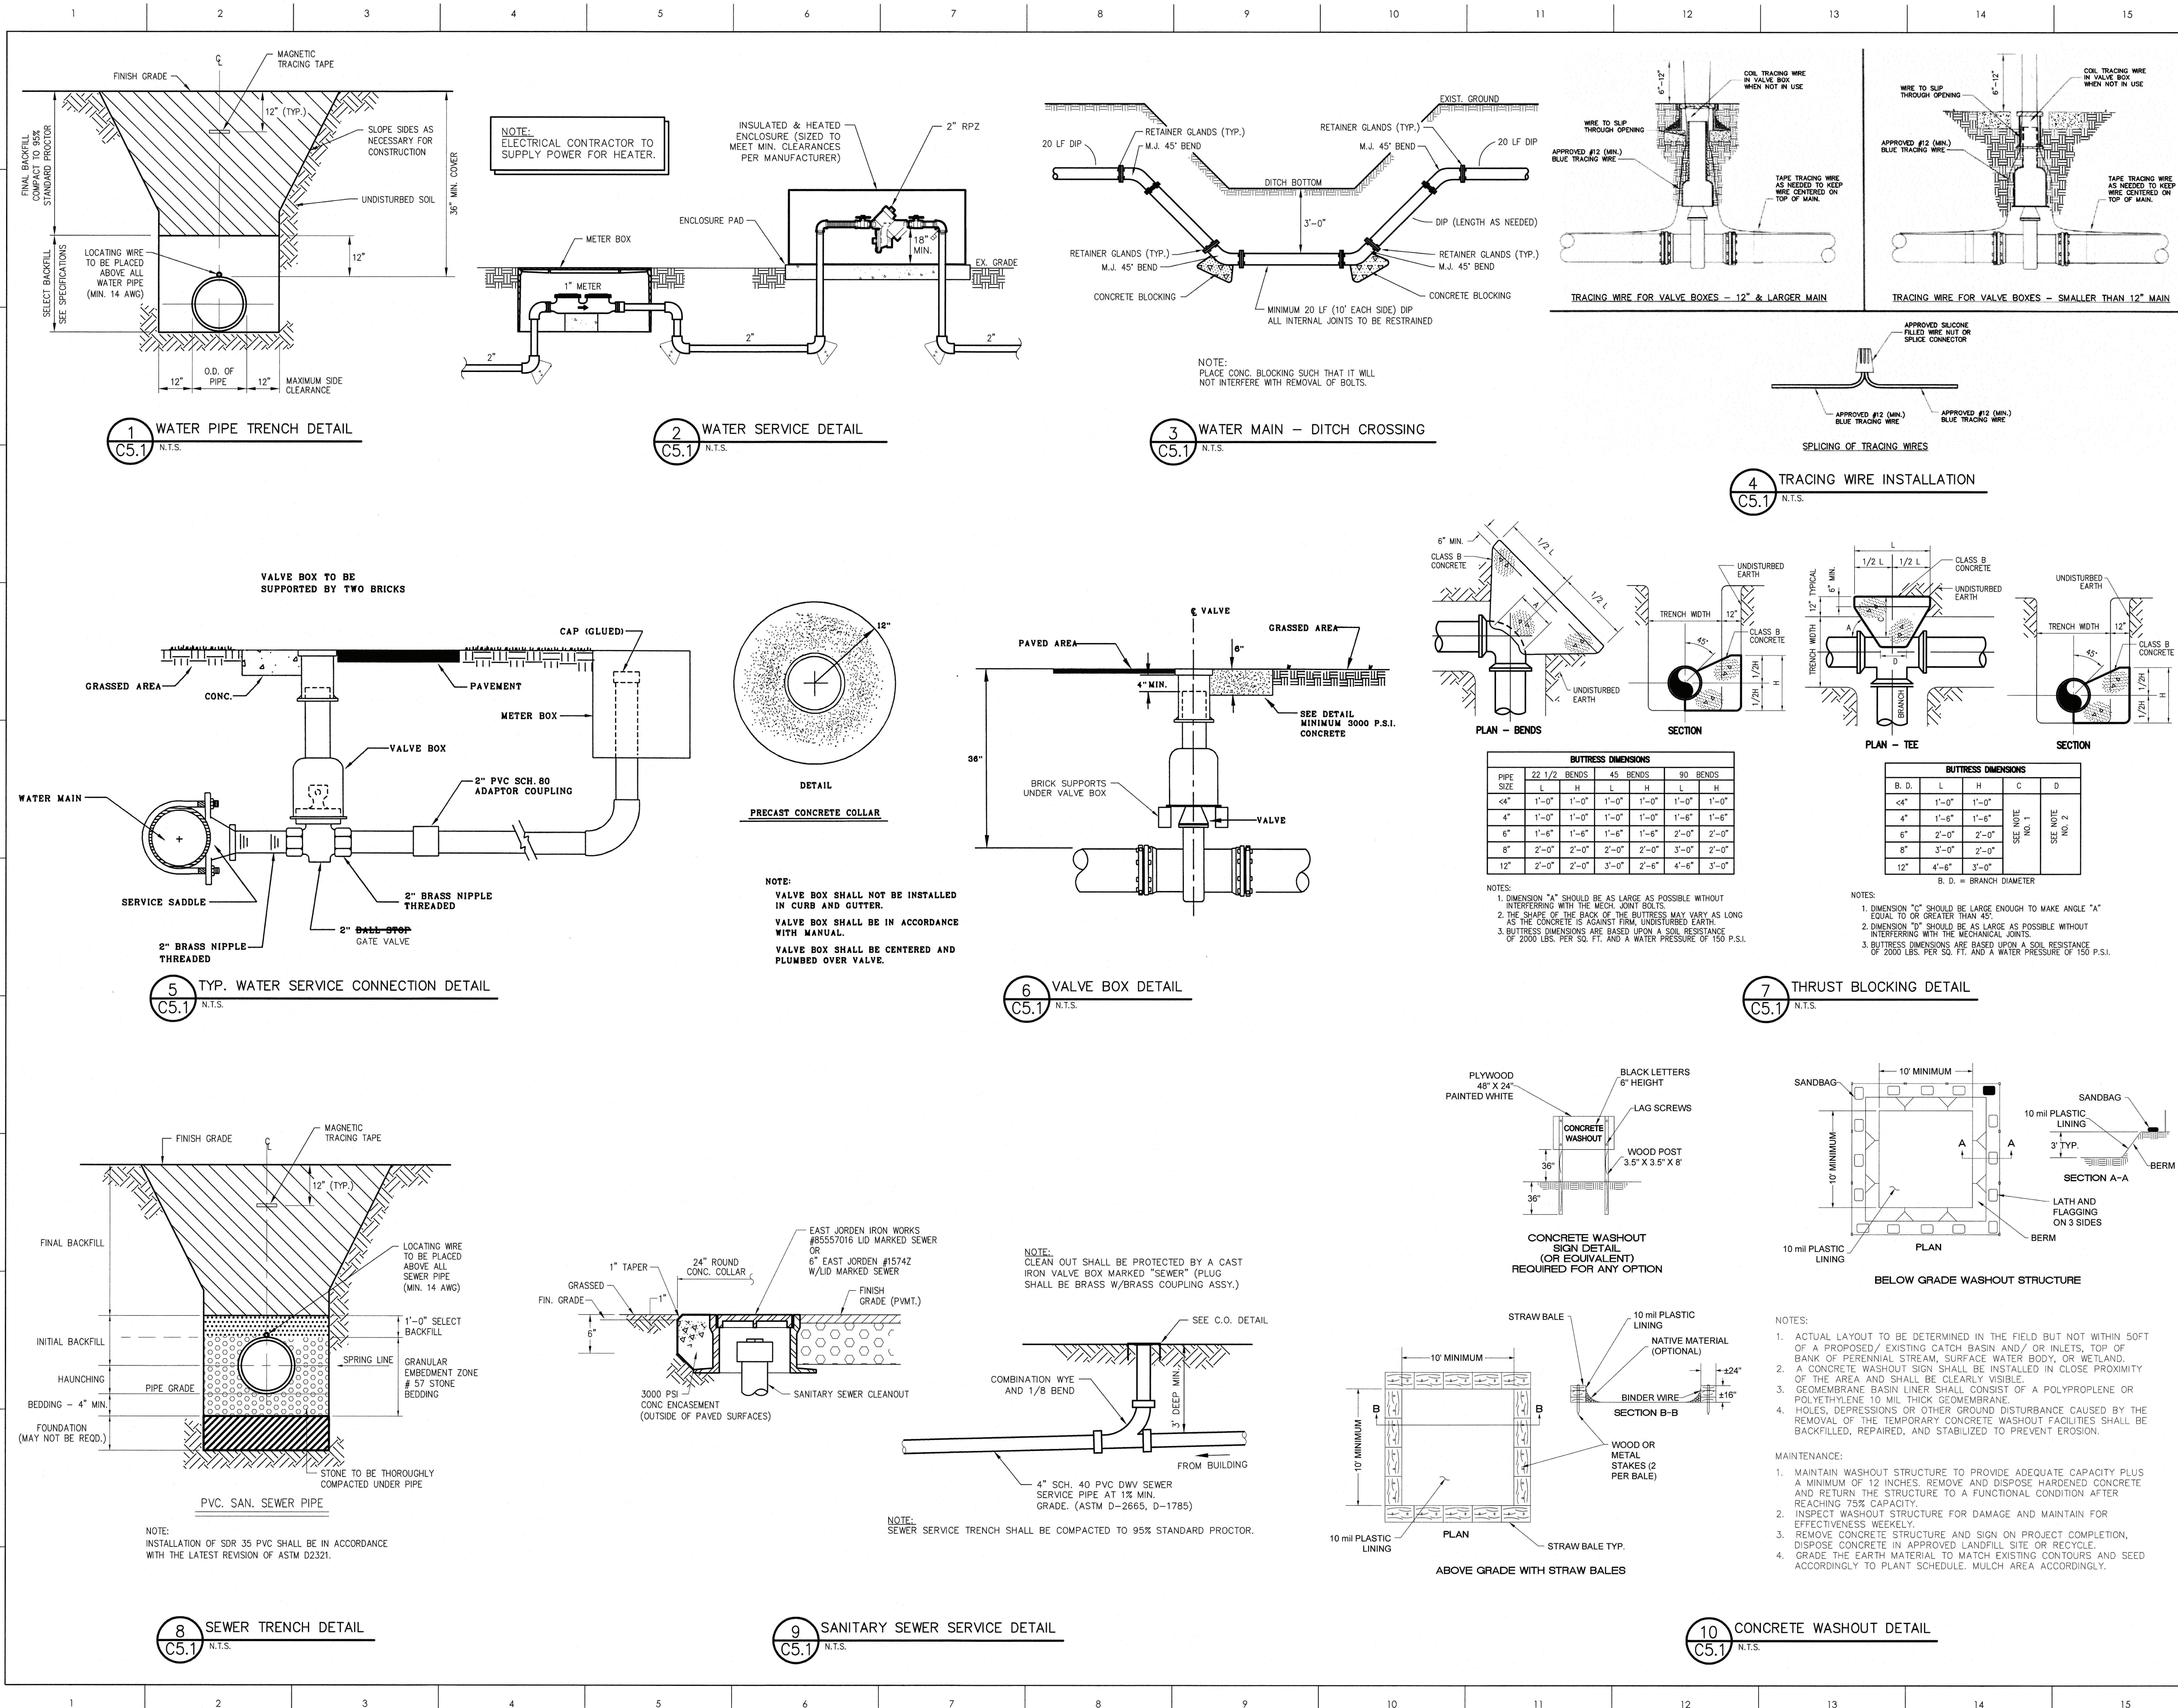


MATERIALS KEYING LEGEND

GENERAL NOTES

THE EAST GROUP, P.A.
•Engineering •Architecture •Surveying •Technology
344 Evans St., Greenville, NC 27838 (252) 758-3748 (252) 830-3954 (Fax)
4322 Lake Stone Trail, Suite 211, Raleigh, NC 27607 (919) 784-9330 (919) 784-9331 (Fax)
• NC Engineering License No. C-0208 • NC Architectural License No. 50213
• NC Landscape Architecture License No. C-427

KEY PLAN

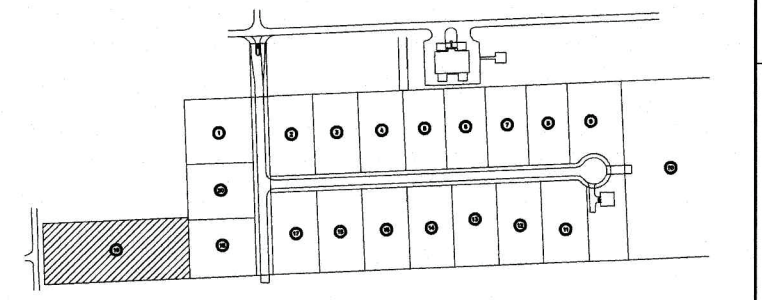

SCO ID #23-27044-01A

NO REVISION DATE

SEAL

JKF
ARCHITECTURE

625 LYNDALE CT., SUITE F, GREENVILLE, NC 27658 252-355-1068

BEAUFORT COUNTY
COMMUNITY COLLEGE
INDUSTRIAL TRAINING CENTER
AURORA, NC

DRAWING TITLE

DETAILS

SCALE AS NOTED

DRAWN SLJ

CHECKED MSC

DATE 1-6-2025

PROJECT NO. 20240128

C5.1

GROUND STABILIZATION AND MATERIALS HANDLING PRACTICES FOR COMPLIANCE WITH THE NCG01 CONSTRUCTION GENERAL PERMIT

Implementing the details and specifications on this plan sheet will result in the construction activity being considered compliant with the Ground Stabilization and Materials Handling sections of the NCG01 Construction General Permit (Sections E and F, respectively). The permittee shall comply with the Erosion and Sediment Control plan approved by the delegated authority having jurisdiction. All details and specifications shown on this sheet may not apply depending on site conditions and the delegated authority having jurisdiction.

Required Ground Stabilization Timeframes		
Site Area Description	Stabilize within this many calendar days after ceasing land disturbance	Timeframe variations
(a) Perimeter dikes, swales, ditches, and perimeter slopes	7	None
(b) High Quality Water (HQW) Zones	7	None
(c) Slopes steeper than 3:1	7	If slopes are 10' or less in length and are not steeper than 2:1, 14 days are allowed
(d) Slopes 3:1 to 4:1	14	- 7 days for slopes greater than 50' in length and with slopes steeper than 4:1 - 7 days for perimeter dikes, swales, ditches, perimeter slopes and HQW Zones - 10 days for Falls Lake Watershed
(e) Areas with slopes flatter than 4:1	14	- 7 days for perimeter dikes, swales, ditches, perimeter slopes and HQW Zones - 10 days for Falls Lake Watershed unless there is zero slope

Note: After the permanent cessation of construction activities, any areas with temporary ground stabilization shall be converted to permanent ground stabilization as soon as practicable but in no case longer than 90 calendar days after the last land disturbing activity. Temporary ground stabilization shall be maintained in a manner to render the surface stable against accelerated erosion until permanent ground stabilization is achieved.

GROUND STABILIZATION SPECIFICATION	
Stabilize the ground sufficiently so that rain will not dislodge the soil. Use one of the techniques in the table below:	
Temporary Stabilization	Permanent Stabilization
• Temporary grass seed covered with straw or other mulches and tackifiers	• Permanent grass seed covered with straw or other mulches and tackifiers
• Hydroseeding	• Geotextile fabrics such as permanent soil reinforcement matting
• Rolled erosion control products with or without temporary grass seed	• Hydroseeding
• Appropriately applied straw or other mulch	• Shrubs or other permanent plantings covered with mulch
• Plastic sheeting	• Uniform and evenly distributed ground cover sufficient to restrain erosion
	• Structural methods such as concrete, asphalt or retaining walls
	• Rolled erosion control products with grass seed

- POLYACRYLAMIDES (PAMS) AND FLOCCULANTS**
- Select flocculants that are appropriate for the soils being exposed during construction, selecting from the *NC DWR List of Approved PAMS/Flocculants*.
 - Apply flocculants at or before the inlets to Erosion and Sediment Control Measures.
 - Apply flocculants at the concentrations specified in the *NC DWR List of Approved PAMS/Flocculants* and in accordance with the manufacturer's instructions.
 - Provide ponding area for containment of treated Stormwater before discharging offsite.
 - Store flocculants in leak-proof containers that are kept under storm-resistant cover or surrounded by secondary containment structures.


- EQUIPMENT AND VEHICLE MAINTENANCE**
- Maintain vehicles and equipment to prevent discharge of fluids.
 - Provide drip pans under any stored equipment.
 - Identify leaks and repair as soon as feasible, or remove leaking equipment from the project.
 - Collect all spent fluids, store in separate containers and properly dispose as hazardous waste (recycle when possible).
 - Remove leaking vehicles and construction equipment from service until the problem has been corrected.
 - Bring used fuels, lubricants, coolants, hydraulic fluids and other petroleum products to a recycling or disposal center that handles these materials.

- LITTER, BUILDING MATERIAL AND LAND CLEARING WASTE**
- Never bury or burn waste. Place litter and debris in approved waste containers.
 - Provide a sufficient number and size of waste containers (e.g. dumpster, trash receptacle) on site to contain construction and domestic wastes.
 - Locate waste containers at least 50 feet away from storm drain inlets and surface waters unless no other alternatives are reasonably available.
 - Locate waste containers on areas that do not receive substantial amounts of runoff from upland areas and does not drain directly to a storm drain, stream or wetland.
 - Cover waste containers at the end of each workday and before storm events or provide secondary containment. Repair or replace damaged waste containers.
 - Anchor all lightweight items in waste containers during times of high winds.
 - Empty waste containers as needed to prevent overflow. Clean up immediately if containers overflow.
 - Dispose waste off-site at an approved disposal facility.
 - On business days, clean up and dispose of waste in designated waste containers.

- PAINT AND OTHER LIQUID WASTE**
- Do not dump paint and other liquid waste into storm drains, streams or wetlands.
 - Locate paint washouts at least 50 feet away from storm drain inlets and surface waters unless no other alternatives are reasonably available.
 - Contain liquid wastes in a controlled area.
 - Containment must be labeled, sized and placed appropriately for the needs of site.
 - Prevent the discharge of soaps, solvents, detergents and other liquid wastes from construction sites.

- PORTABLE TOILETS**
- Install portable toilets on level ground, at least 50 feet away from storm drains, streams or wetlands unless there is no alternative reasonably available. If 50 foot offset is not attainable, provide relocation of portable toilet behind silt fence or place on a gravel pad and surround with sand bags.
 - Provide staking or anchoring of portable toilets during periods of high winds or in high foot traffic areas.
 - Monitor portable toilets for leaking and properly dispose of any leaked material. Utilize a licensed sanitary waste hauler to remove leaking portable toilets and replace with properly operating unit.

- EARTHEN STOCKPILE MANAGEMENT**
- Show stockpile locations on plans. Locate earthen-material stockpile areas at least 50 feet away from storm drain inlets, sediment basins, perimeter sediment controls and surface waters unless it can be shown no other alternatives are reasonably available.
 - Protect stockpile with silt fence installed along toe of slope with a minimum offset of five feet from the toe of stockpile.
 - Provide stable stone catch point when feasible.
 - Stabilize stockpile within the timeframes provided on this sheet and in accordance with the approved plan and any additional requirements. Soil stabilization is defined as vegetative, physical or chemical coverage techniques that will restrain accelerated erosion on disturbed soils for temporary or permanent control needs.

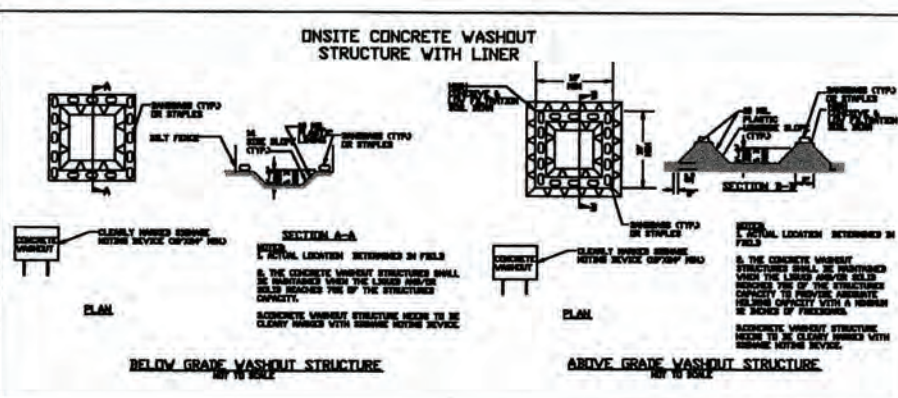

- CONCRETE WASHOUTS**
- Do not discharge concrete or cement slurry from the site.
 - Dispose of, or recycle settled, hardened concrete residue in accordance with local and state solid waste regulations and at an approved facility.
 - Manage washout from mortar mixers in accordance with the above item and in addition place the mixer and associated materials on impervious barrier and within lot perimeter silt fence.
 - Install temporary concrete washouts per local requirements, where applicable. If an alternate method or product is to be used, contact your approval authority for review and approval. If local standard details are not available, use one of the two types of temporary concrete washouts provided on this detail.
 - Do not use concrete washouts for dewatering or storing defective curb or sidewalk sections. Stormwater accumulated within the washout may not be pumped into or discharged to the storm drain system or receiving surface waters. Liquid waste must be pumped out and removed from project.
 - Locate washouts at least 50 feet from storm drain inlets and surface waters unless it can be shown that no other alternatives are reasonably available. At a minimum, install protection of storm drain inlet(s) closest to the washout which could receive spills or overflow.
 - Locate washouts in an easily accessible area, on level ground and install a stone entrance pad in front of the washout. Additional controls may be required by the approving authority.
 - Install at least one sign directing concrete trucks to the washout within the project limits. Post signage on the washout itself to identify this location.
 - Remove leavings from the washout when at approximately 75% capacity to limit overflow events. Replace the tarp, sand bags or other temporary structural components when no longer functional. When utilizing alternative or proprietary products, follow manufacturer's instructions.
 - At the completion of the concrete work, remove remaining leavings and dispose of in an approved disposal facility. Fill pit, if applicable, and stabilize any disturbance caused by removal of washout.

- HERBICIDES, PESTICIDES AND RODENTICIDES**
- Store and apply herbicides, pesticides and rodenticides in accordance with label restrictions.
 - Store herbicides, pesticides and rodenticides in their original containers with the label, which lists directions for use, ingredients and first aid steps in case of accidental poisoning.
 - Do not store herbicides, pesticides and rodenticides in areas where flooding is possible or where they may spill or leak into wells, stormwater drains, ground water or surface water. If a spill occurs, clean area immediately.
 - Do not stockpile these materials onsite.

- HAZARDOUS AND TOXIC WASTE**
- Create designated hazardous waste collection areas on-site.
 - Place hazardous waste containers under cover or in secondary containment.
 - Do not store hazardous chemicals, drums or bagged materials directly on the ground.

SEED BED PREPARATION NOTES

- DISKIFY SOIL TO A DEPTH OF THREE (3) INCHES AND WORK INTO A SATISFACTORY SEED BED BY SCARING, USE OF CULTIPACKERS, HARROWS, DRAGS AND OTHER APPROVED MEANS.
- PREPARATION OUTLINED ABOVE SHALL NOT BE DONE WHEN THE SOIL IS FROZEN, WET OR OTHERWISE IN AN UNFAVORABLE CONDITION.
- BEGIN AND COMPLETE SEEDING OPERATIONS AS OUTLINED AS SOON AS POSSIBLE AFTER FINAL GRADING IS COMPLETED, BUT IN NO EVENT LATER THAN 14 CALENDAR DAYS AFTER COMPLETION OF FINAL GRADING.
- SEEDING AND MULCHING OPERATIONS SHALL NOT BEGIN UNTIL ELECTRICAL SERVICE HAS BEEN INSTALLED WITHIN THE PROJECT, UNLESS DIRECTED BY THE ARCHITECT/ENGINEER.
- DISTRIBUTE LIME AND FERTILIZER, UNIFORMLY OVER SEED BED AND HARROW, RAKE, OR OTHERWISE WORK SAME INTO SEED BEDS.
- DISTRIBUTE SEED UNIFORMLY OVER SEED BED. COVER SEED LIGHTLY AFTER SEEDING.
- NO LIME, FERTILIZER, OR SEED SHALL BE APPLIED DURING A STRONG WIND, WHEN SOIL IS WET OR OTHERWISE UNWORKABLE. SHOULD RAIN FOLLOW SEEDING BEFORE ROLLING IS BEGUN, THE BED SHALL NOT BE ROLLED.

MAINTENANCE PLAN

- ALL EROSION AND SEDIMENT CONTROL PRACTICES WILL BE CHECKED FOR STABILITY AND INTEGRITY FOLLOWING EVERY 0.5" OVER 24-HOUR PERIOD RAINFALL EVENT, BUT IN NO CASE LESS THAN ONCE EVERY WEEK. ANY NEEDED REPAIRS WILL BE MADE IMMEDIATELY TO MAINTAIN ALL PRACTICES AS DESIGNED.
- SEDIMENT WILL BE REMOVED FROM BEHIND THE SEDIMENT FENCE WHEN IT BECOMES 0.5 FT DEEP AT THE FENCE. THE SEDIMENT FENCE WILL BE REPAIRED AS NECESSARY TO MAINTAIN A BARRIER.
- EROSION CONTROL MATTING SHALL BE MAINTAINED UNTIL ALL WORK IS COMPLETE. AREAS SHALL BE RESEEDED AND MATTING SHALL BE REPLACED AS NEEDED.
- TEMPORARY GRAVEL CONSTRUCTION ENTRANCE/ EXIT WILL BE INSPECTED PERIODICALLY. WHEN MUD BEGINS TO BUILD-UP, THE ENTRANCE WILL BE BLADED OFF REMOVING THE MUD. ADD NEW STONE TO ENTRANCE AS NEEDED.
- ALL SEEDED AREAS WILL BE FERTILIZED, RE-SEEDED AS NECESSARY AND MULCHED ACCORDING TO SPECIFICATION IN THE VEGETATIVE PLAN TO MAINTAIN A VIGOROUS, DENSE VEGETATIVE COVER.

EROSION NOTES:

- NO LAND DISTURBING ACTIVITY BEYOND THAT REQUIRED TO INSTALL APPROPRIATE EROSION CONTROL MEASURES MAY PROCEED UNTIL EROSION CONTROL MEASURES ARE INSPECTED.
- SEED AND MULCHING OR OTHERWISE PROVIDE GROUND COVER DEVICES OR STRUCTURES SUFFICIENT TO RESTRAIN EROSION FOR ALL EXPOSED SLOPES WITHIN 14 WORKING DAYS OF COMPLETING ANY PHASE OF GRADING.
- CONTRACTOR SHALL INSPECT AND MAINTAIN AS NEEDED ALL EROSION CONTROL DEVICES ON A WEEKLY BASIS AND AFTER EACH 0.5" OVER 24-HOUR PERIOD RAINFALL EVENT. FAILURE TO KEEP EROSION CONTROL DEVICES IN GOOD WORKING ORDER MAY RESULT IN ISSUANCE OF A STOP WORK ORDER OR CIVIL PENALTIES UP TO \$5,000 PER DAY OF VIOLATION. SITES UTILIZING SEDIMENT TRAPS MUST ALSO SPECIFY A MAXIMUM DEPTH OF SEDIMENT PRIOR TO CLEAN OUT.
- ACCEPTANCE AND APPROVAL OF THIS PLAN IS CONDITIONED UPON YOUR COMPLIANCE WITH FEDERAL AND STATE WATER QUALITY LAWS, REGULATIONS, AND RULES. IN ADDITION, LOCAL CITY AND COUNTY ORDINANCES OR RULES MAY ALSO APPLY TO THIS LAND-DISTURBING ACTIVITY. APPROVAL BY THE CITY DOES NOT SUPERCEDE ANY OTHER PERMIT OR APPROVAL. PLEASE BE ADVISED OF THE RULES TO PROTECT AND MAINTAIN EXISTING BUFFERS ALONG WATERCOURSES IN THE NEUSE AND TAR RIVER BASINS. THESE RULES ARE ENFORCED BY THE DIVISION OF WATER QUALITY (DWQ). DIRECT ANY QUESTIONS ABOUT THE APPLICABILITY OF THESE RULES TO YOUR PROJECT, THE REGIONAL WATER QUALITY SUPERVISOR, WASHINGTON REGIONAL OFFICE AT (252) 946-6481.
- ALL DEWATERING OPERATIONS SHALL BE FILTERED PRIOR TO LEAVING THE SITE.

NPDES INSPECTION REQUIREMENTS:

- MUST KEEP A RAIN GAUGE ON THE PROJECT SITE.
- DEDICATED DEMOLITION AND OTHER WASTE AREAS AND EARTHEN MATERIAL STOCKPILES MUST BE LOCATED AT LEAST 50' FORM STORM DRAINS OR STREAMS UNLESS NO ALTERNATIVE IS FEASIBLE.
- MUST INSPECT ALL EROSION AND SEDIMENT CONTROL MEASURES AT LEAST ONCE A WEEK AND WITHIN 24 HOURS AFTER ANY STORM EVENT GREATER THAN A HALF-INCH (DURING A 24 HOUR PERIOD). MUST TAKE IMMEDIATE CORRECTIVE ACTION FOR ANY DEVICE FAILURE.
- MUST INSPECT ALL OUTLETS WHERE STORMWATER RUNOFF LEAVES THE SITE AND EVALUATE THE EFFECT ON NEARBY STREAMS OR WETLANDS.
- CORRECTIVE ACTION MUST BE TAKEN IF SEDIMENT IS DEPOSITED OFF-SITE OR INTO A STREAM OR WETLAND, OR CAUSES A VISIBLE INCREASE IN TURBIDITY OF ANY WATERBODY.
- MUST KEEP RECORDS OF THESE INSPECTIONS AND ANY CORRECTIVE ACTIONS TAKEN.

GROUND STABILIZATION		
SITE AREA DESCRIPTION	STABILIZATION TIME FRAME	STABILIZATION TIME FRAME EXCEPTIONS
* PERIMETER DIKES, SWALES, DITCHES AND SLOPES	7 DAYS	NONE
* HIGH QUALITY WATER (HQW) ZONES	7 DAYS	NONE
* SLOPES STEEPER THAN 3:1	7 DAYS	IF SLOPES ARE 10' OR LESS IN LENGTH AND ARE NOT STEEPER THAN 2:1, 14 DAYS ARE ALLOWED.
* SLOPES 3:1 OR FLATTER	14 DAYS	7 DAYS FOR SLOPES GREATER THAN 50 FEET IN LENGTH
* ALL OTHER AREAS WITH SLOPES FLATTER THAN 4:1	14 DAYS	NONE (EXCEPT FOR PERIMETERS AND HQW ZONES)

VEGETATIVE PLAN:

VEGETATIVE COVER SHALL BE IN ACCORDANCE WITH THE SEEDING SCHEDULE AND THE FOLLOWING SPECIFICATION SECTIONS:

SECTION 02110 SITE CLEARING
SECTION 02120 EROSION & POLLUTION CONTROL
SECTION 02228 CLEAN-UP & SEEDING

TEMPORARY SEEDING

DATE		
APR 15-AUG 14	GERMAN MILLET	50 LBS/ACRE
AUG 15-APR 14	RYE (GRAIN)	50 LBS/ACRE
YEAR ROUND	FERTILIZER 10-20-20 ANALYSIS	400 LBS/ACRE

SEEDING AND MULCHING

ALL ROADWAY AREAS

MARCH 1 - AUGUST 31	
50#	TALL FESCUE
10#	CENTPEDE
25#	BERMUDAGRASS (HULLED)
500#	FERTILIZER
4000#	LIMESTONE

SEPTEMBER 1 - FEBRUARY 28	
50#	TALL FESCUE
10#	CENTPEDE
35#	BERMUDAGRASS (HULLED)
500#	FERTILIZER
4000#	LIMESTONE

WATER AND BORROW LOCATIONS

MARCH 1 - AUGUST 31	
75#	TALL FESCUE
25#	BERMUDAGRASS (HULLED)
500#	FERTILIZER
4000#	LIMESTONE

SEPTEMBER 1 - FEBRUARY 28	
75#	TALL FESCUE
35#	BERMUDAGRASS (HULLED)
500#	FERTILIZER
4000#	LIMESTONE

NOTE:
50# OF BAHAGRASS MAY BE SUBSTITUTED FOR EITHER CENTPEDE OR BERMUDAGRASS ONLY UPON ENGINEER'S REQUEST.

CONSTRUCTION SEQUENCE

- OBTAIN AND POST A COPY OF THE CERTIFICATE OF EROSION AND SEDIMENT CONTROL PLAN APPROVAL. NOTIFY NCEQ - LAND QUALITY SECTION, WASHINGTON REGIONAL OFFICE AT 252-946-6481 PRIOR TO COMMENCING CONSTRUCTION. A PRECONSTRUCTION MEETING MAY BE REQUIRED AT THE DISCRETION OF THE DIVISION.
- CONSTRUCT TEMPORARY CONSTRUCTION ENTRANCE/EXIT.
- DISTURB LAND ONLY AS NECESSARY TO INSTALL TEMPORARY EROSION AND SEDIMENT CONTROL DEVICES. INSTALL ADDITIONAL EROSION AND SEDIMENT CONTROL DEVICES AS NEEDED OR AS DIRECTED BY THE ENGINEER.
- PERFORM SITE CLEARING INCLUDING STRIPPING TOPSOIL AND DISPOSE OF DEBRIS AT AN APPROVED SITE. PRIOR TO AND DURING DEMOLITION PHASE INSTALL APPROPRIATE EROSION AND SEDIMENTATION CONTROL MEASURES.
- TRANSITION EROSION CONTROL MEASURES FROM DEMOLITION PHASE TO CONSTRUCTION PHASE AND INSTALL MEASURES IN APPROPRIATE AREAS.
- BEGIN CONSTRUCTION OF THE BUILDING PAD, PARKING LOT AND DRIVES INCLUDING AGGREGATE STONE BASE AND STORM DRAINAGE PIPE.
- BEGIN UTILITY MAIN CONSTRUCTION INCLUDING GRAVITY SEWER, WATER MAIN AND ROOF DRAINS.
- MAINTAIN EROSION AND SEDIMENTATION MEASURES DURING CONSTRUCTION. CHECK THE MEASURES FOR FAILURE AND AVAILABLE SEDIMENT STORAGE AFTER EACH SIGNIFICANT RAINFALL EVENT.
- COMPLETE CONSTRUCTION OF THE BUILDING, PARKING LOT, SIDEWALKS AND DRIVES INCLUDING THE PLACEMENT OF THE ASPHALT PAVEMENT.
- MULCH AND SEED ALL DISTURBED AREAS. ANY SLOPES LEFT EXPOSED WILL WITHIN 14 CALENDAR DAYS OF COMPLETION OF ANY PHASE OF GRADING, BE PLANTED OR OTHERWISE PROVIDED WITH TEMPORARY OR PERMANENT GROUND COVER, DEVICES, OR STRUCTURES SUFFICIENT TO RESTRAIN EROSION.
- REMOVE ALL TEMPORARY EROSION CONTROL MEASURES ONCE PERMANENT VEGETATION IS ESTABLISHED $\geq$ 80%.
- TIME OF EXPOSURE IS APPROXIMATELY 9 MONTHS OR UNTIL COMPLETION AND STABILIZATION OF THE SITE. CONTRACTOR SHALL PREPARE FOR MAINTENANCE OF THE SITE EROSION AND SEDIMENTATION MEASURES APPROPRIATE FOR THE EXPECTED DURATION.

NCG01 GROUND STABILIZATION AND MATERIALS HANDLING

EFFECTIVE: 04/01/19

PART III SELF-INSPECTION, RECORDKEEPING AND REPORTING		
SECTION A: SELF-INSPECTION		
Self-inspections are required during normal business hours in accordance with the table below. When adverse weather or site conditions would cause the safety of the inspection personnel to be in jeopardy, the inspection may be delayed until the next business day on which it is safe to perform the inspection. In addition, when a storm event of equal to or greater than 1.0 inch occurs outside of normal business hours, the self-inspection shall be performed upon the commencement of the next business day. Any time when inspections were delayed shall be noted in the Inspection Record.		
Inspect	Frequency (during normal business hours)	Inspection records must include:
(1) Rain gauge maintained in good working order	Daily	Daily rainfall amounts. If no daily rain gauge observations are made during weekend or holiday periods, and no individual day rainfall information is available, record the cumulative rain measurement for those unattended days (see this will determine if a site inspection is needed). Days on which no rainfall occurred shall be recorded as "zero." The permittee may use another rain-monitoring device approved by the Division.
(2) E&S Measures	At least once per 7 calendar days and within 24 hours of a rain event $\geq$ 1.0 inch in 24 hours	1. Identification of the measures inspected. 2. Date and time of the inspection. 3. Name of the person performing the inspection. 4. Indication of whether the measures were operating properly. 5. Description of evidence needed for the measure. 6. Description, evidence, and date of corrective actions taken.
(3) Stormwater discharge outfalls (SDCs)	At least once per 7 calendar days and within 24 hours of a rain event $\geq$ 1.0 inch in 24 hours	1. Identification of the discharge outfalls inspected. 2. Date and time of the inspection. 3. Name of the person performing the inspection. 4. Evidence of indication of stormwater pollution such as oil shivers, floating or suspended solids or discoloration. 5. Indication of visible sediment leaving the site. 6. Description, evidence, and date of corrective actions taken.
(4) Perimeter of site	At least once per 7 calendar days and within 24 hours of a rain event $\geq$ 1.0 inch in 24 hours	1. Visible sedimentation is found outside site limits, then a record of the following shall be made: a. Actions taken to clean up or stabilize the sediment that has left the site limits. b. Description, evidence, and date of corrective actions taken, and c. An explanation as to the actions taken to control future releases.
(5) Streams or wetlands onsite or offsite (where accessible)	At least once per 7 calendar days and within 24 hours of a rain event $\geq$ 1.0 inch in 24 hours	1. If the stream or wetland has increased visible sedimentation or a stream has visible increased turbidity from the construction activity, then a record of the following shall be made: a. Description, evidence and date of corrective actions taken. b. Records of the required reports to the appropriate Division Regional Office (see Part III, Section C, Item (3)(c) of this permit).
(6) Ground stabilization measures	After each phase of grading	1. The phase of grading (disturbance of perimeter E&S measures, clearing and grubbing, installation of storm drainage facilities, completion of all land-disturbing activity, construction or redevelopment, permanent ground cover). 2. Documentation that the required ground stabilization measures have been provided within the required timeframe or an assurance that they will be provided as soon as possible.
NOTE: The rain inspection resets the required 7 calendar day inspection requirement.		
PART II, SECTION G, ITEM (4) DRAW DOWN OF SEDIMENT BASINS FOR MAINTENANCE OR CLOSE OUT		
Sediment basins and traps that receive runoff from drainage areas of one acre or more shall use outlet structures that withdraw water from the surface when these devices need to be drawn down for maintenance or close out unless this is infeasible. The circumstances in which it is not feasible to withdraw water from the surface shall be rare (for example, times with extended cold weather). Non-surface withdrawals from sediment basins shall be allowed only when all of the following criteria have been met:		
(a) The E&S plan authority has been provided with documentation of the non-surface withdrawal and the specific time periods or conditions in which it will occur. The non-surface withdrawal shall not commence until the E&S plan authority has approved these items.		
(b) The non-surface withdrawal has been reported as an anticipated bypass in accordance with Part III, Section C, Item (2)(c) and (d) of this permit.		
(c) Dewatering discharges are treated with controls to minimize discharges of pollutants from stormwater that is removed from the sediment basin. Examples of appropriate controls include properly sized, designed and maintained dewatering tanks, weir tanks, and filtration systems.		
(d) Vegetated, upland areas of the sites or a properly designed stone pad is used to the extent feasible at the outlet of the dewatering treatment devices described in item (c) above.		
(e) Velocity dissipation devices such as check dams, sediment traps, and riprap are provided at all dewatering devices, and		
(f) Sediment removed from the dewatering treatment devices described in item (e) above is disposed of in a manner that does not cause deposition of sediment into waters of the United States.		



NCG01 SELF-INSPECTION, RECORDKEEPING AND REPORTING

EFFECTIVE: 04/01/19


MATERIALS KEYING LEGEND

GENERAL NOTES




•Engineering•Architecture•Surveying•Technology
324 E. 5th St., Greenville, NC 27838 (252) 758-3746 (252) 635-3054 (Fax)
4332 Lake Boone Trail, Suite 301, Raleigh, NC 27607 (919) 784-8330 (919)
•NC Engineering License No. C-0208 • NC Architectural License No. 50231
• NC Landscape Architectural License No. C-427

KEY PLAN

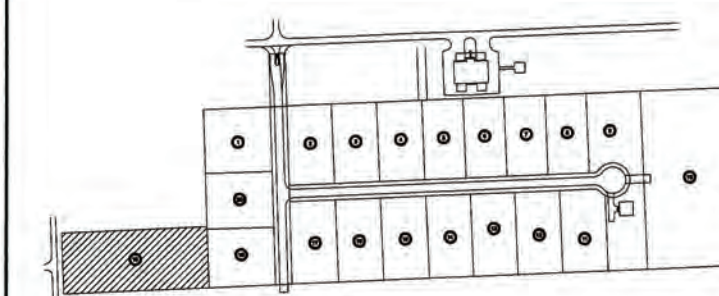

SCO ID #23-27044-01A

NO REVISION DATE

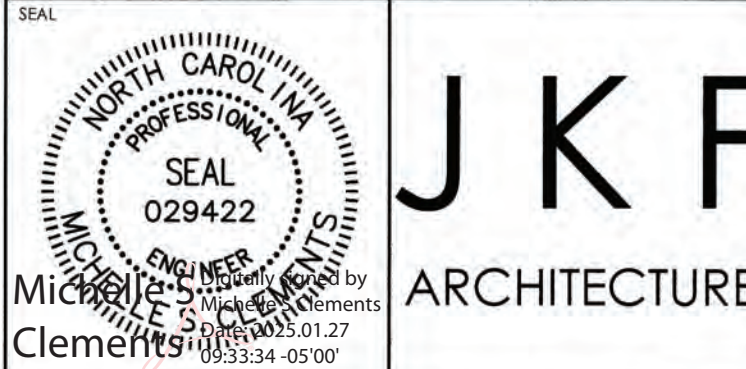

BEAUFORT COUNTY
COMMUNITY COLLEGE
INDUSTRIAL TRAINING CENTER
AURORA, NC

DRAWING TITLE

NOTES





SCALE AS NOTED

DRAWN BY SLJ

CHECKED MSC

DATE 1-6-2025


PROJECT NO. 20240128

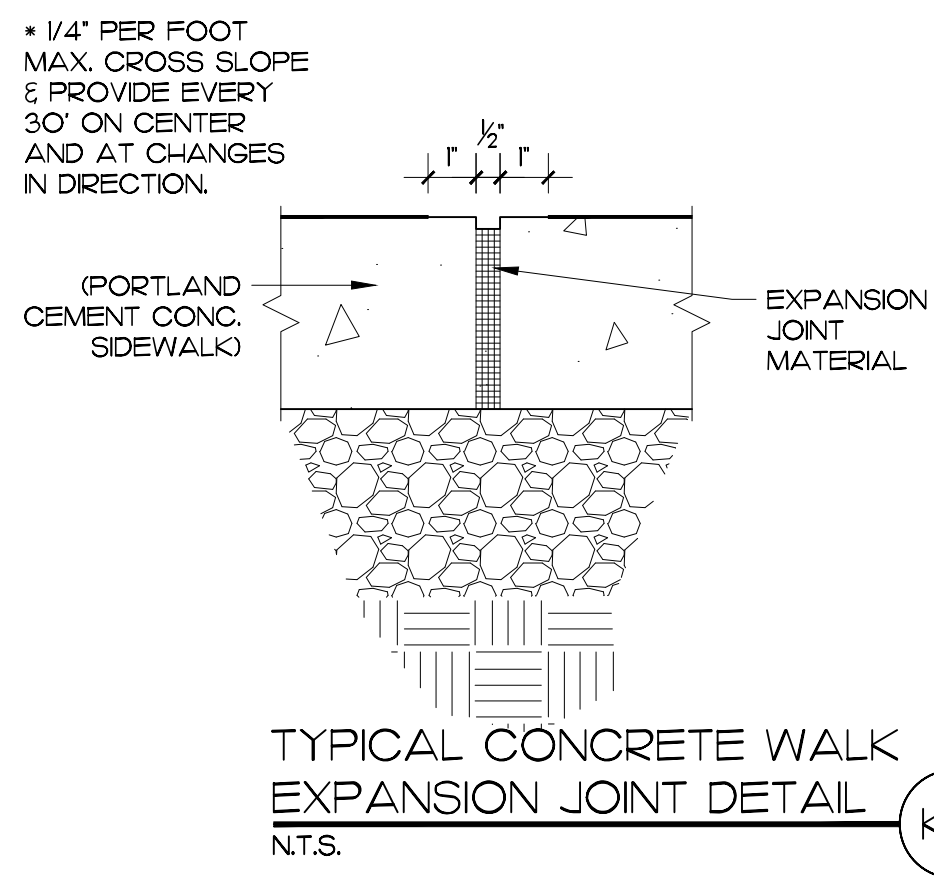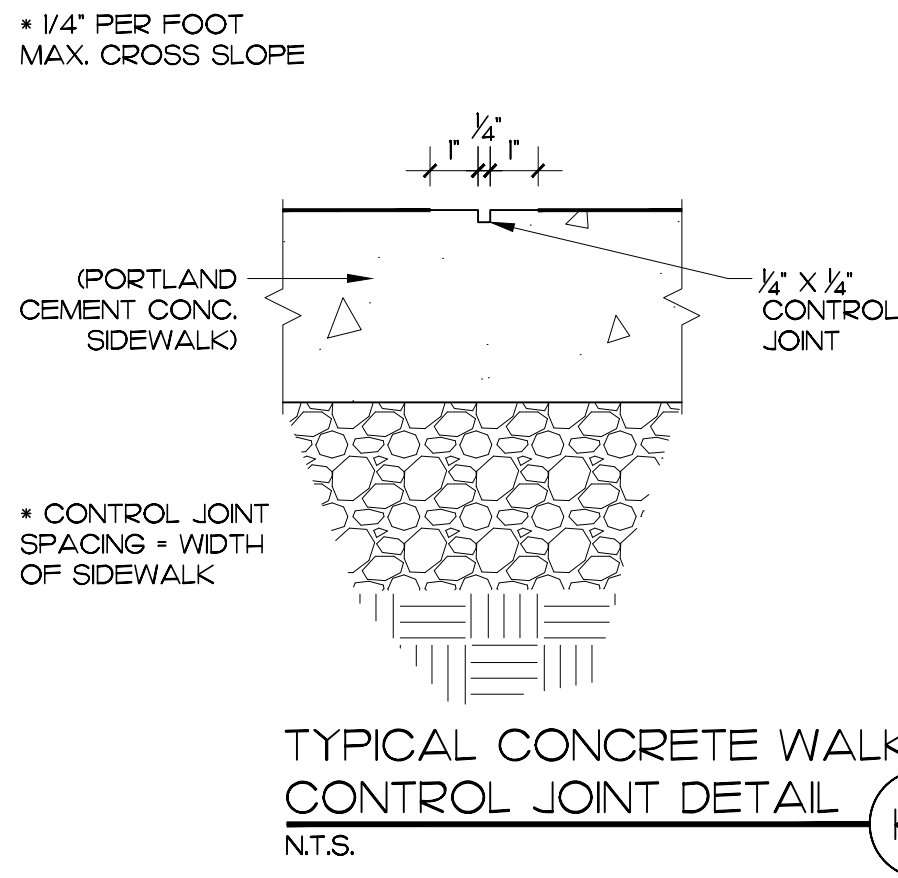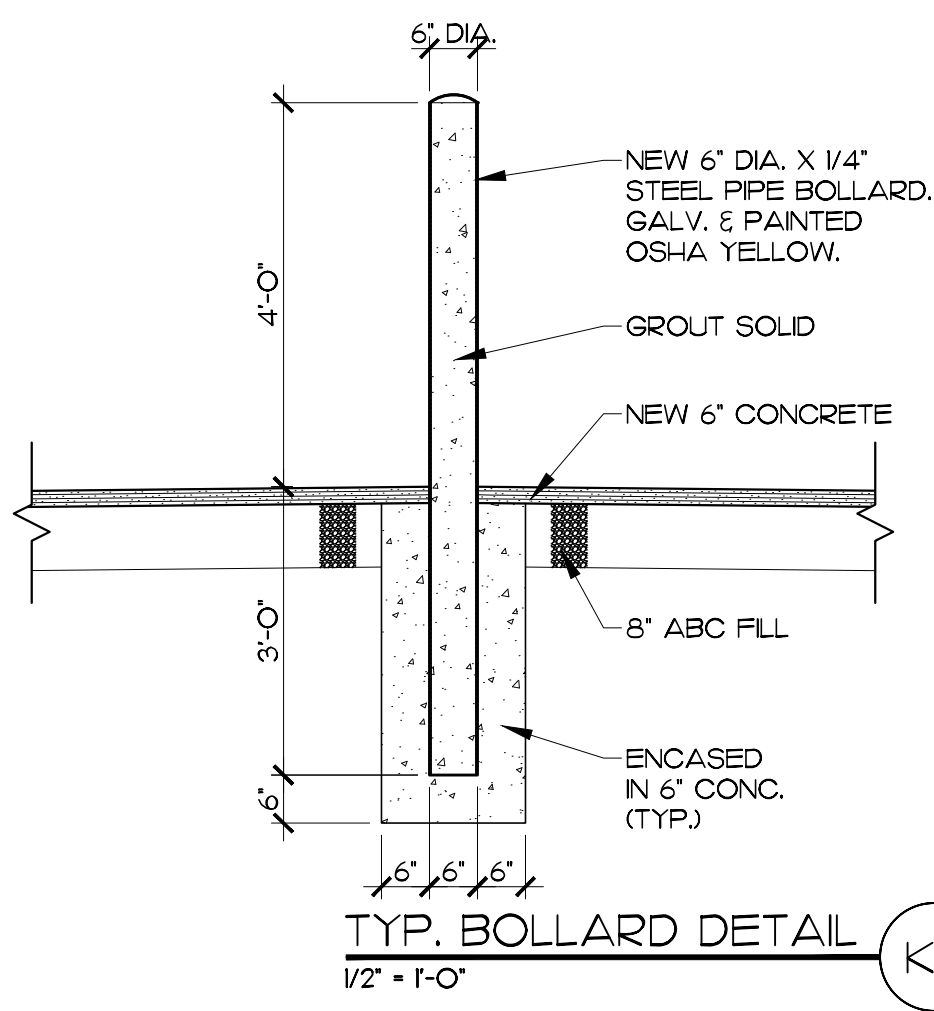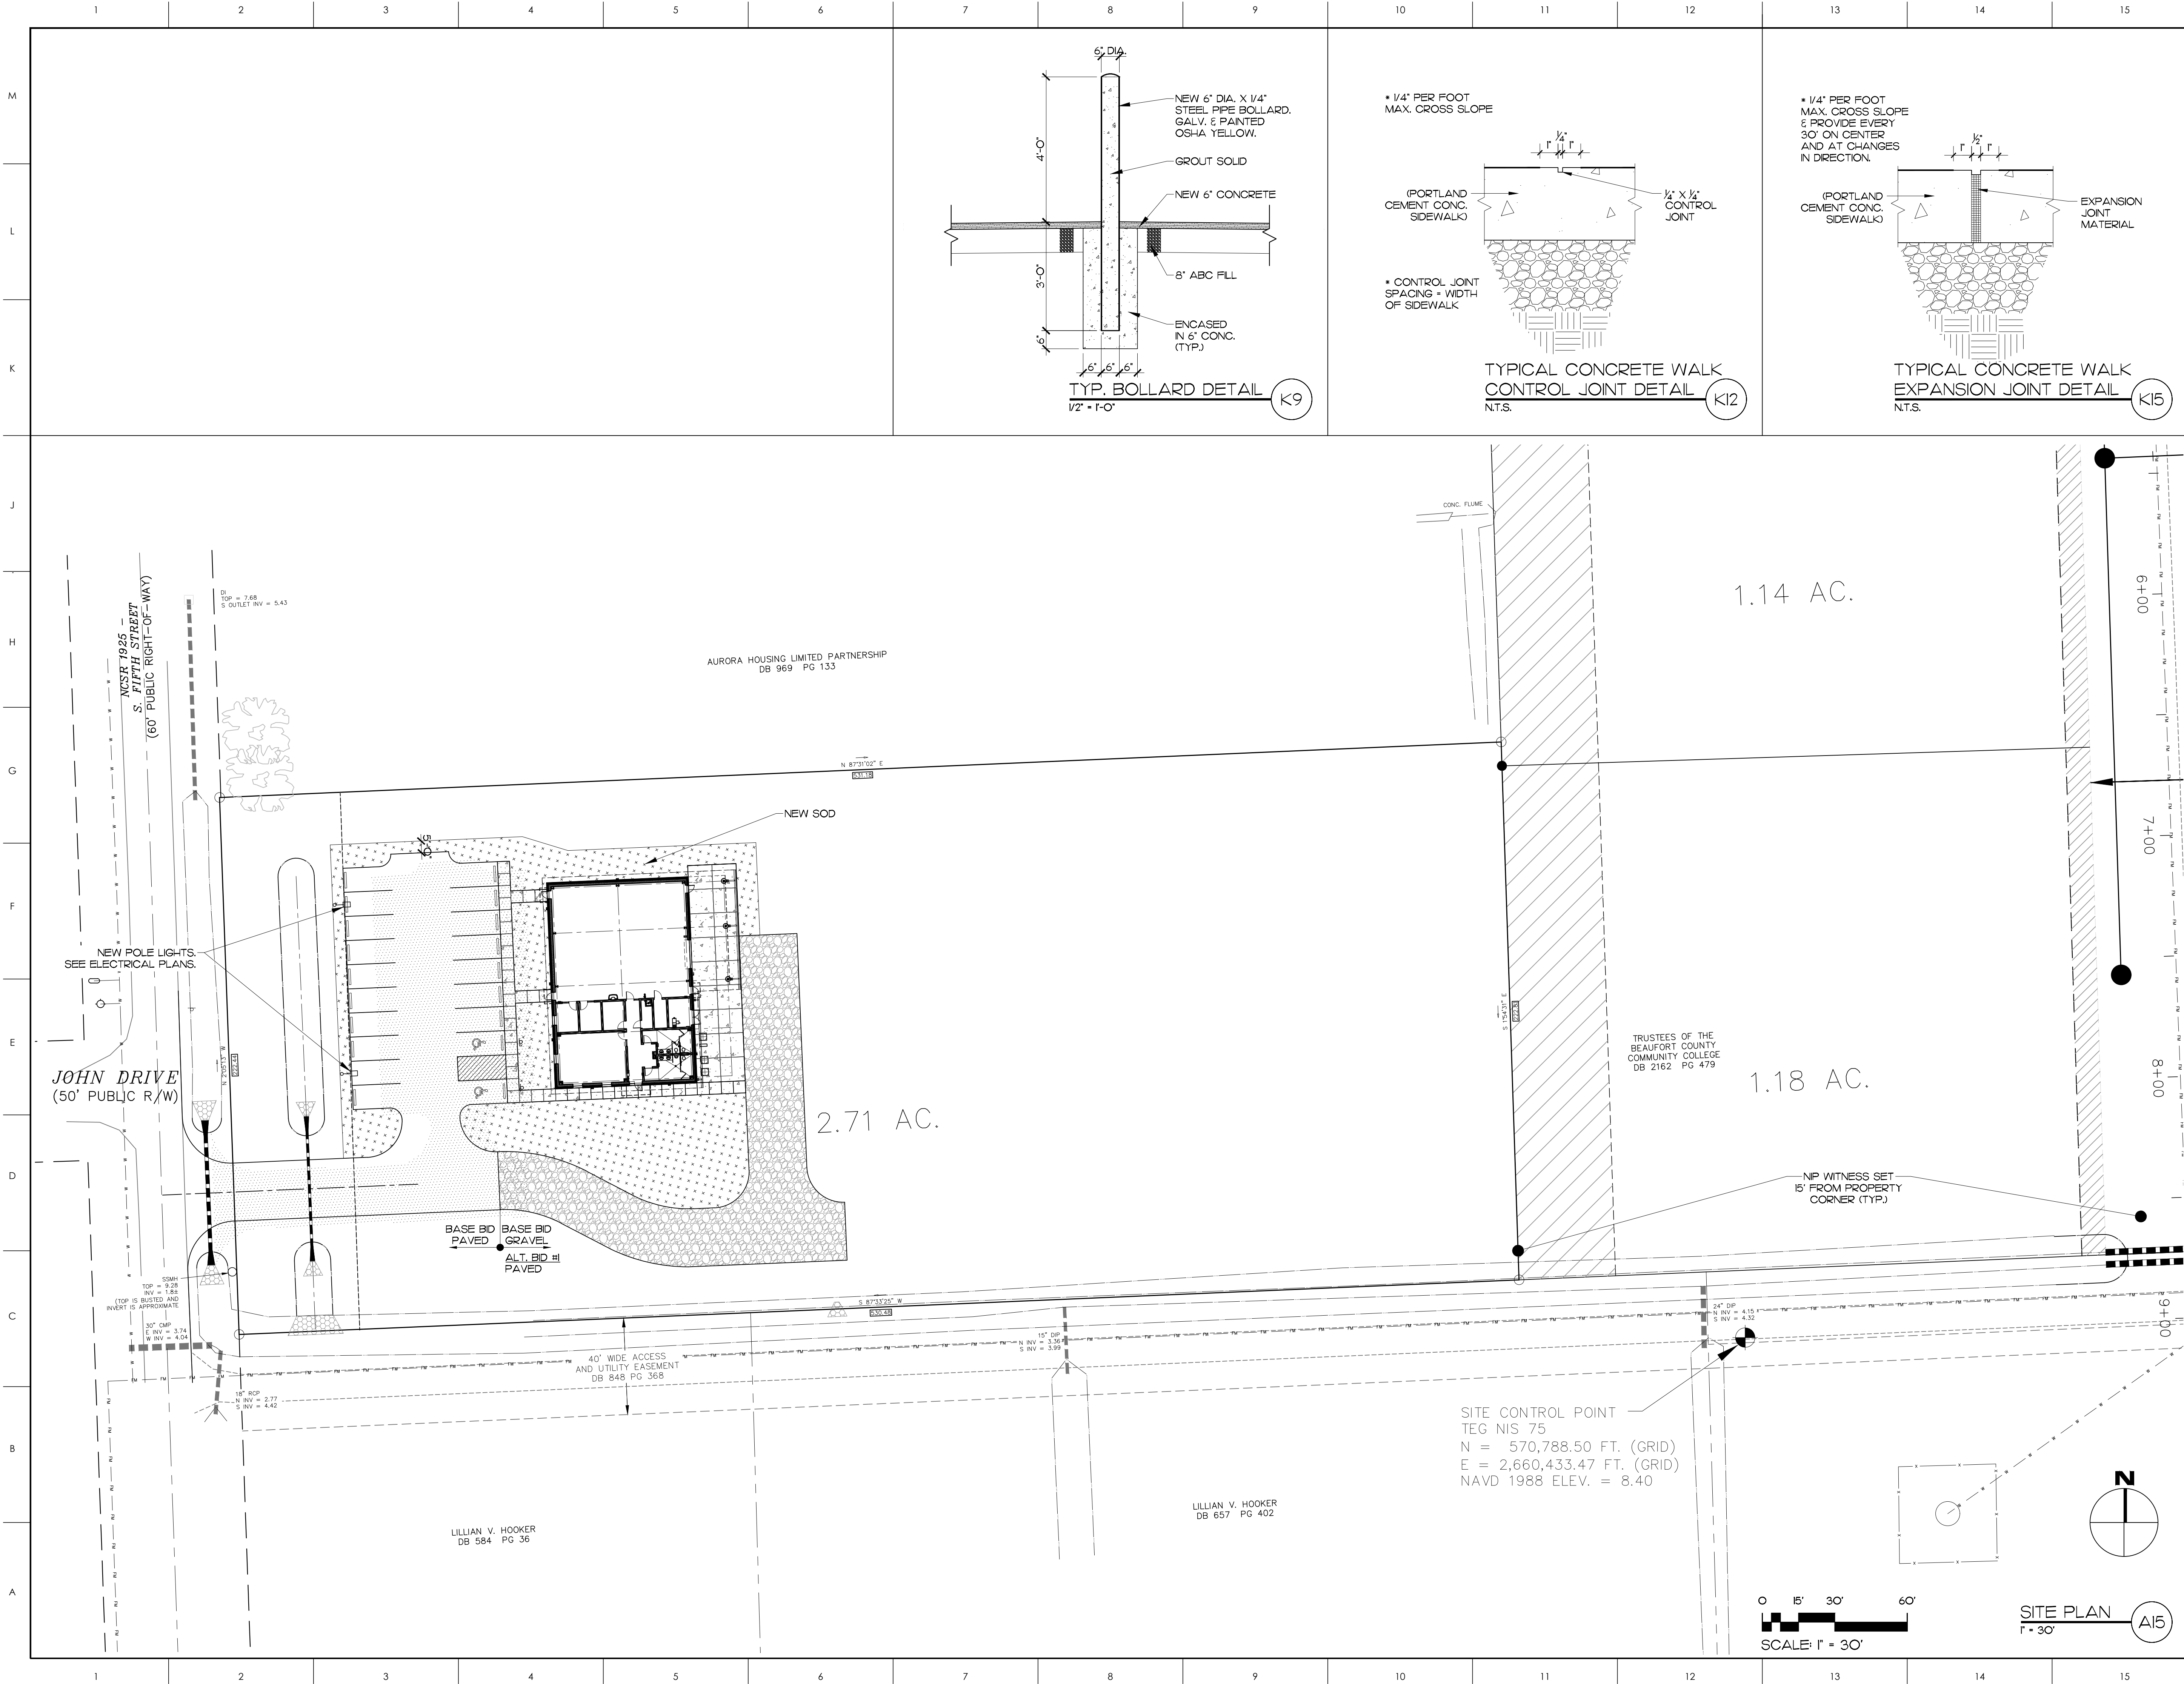

MATERIALS KEYING LEGEND

GENERAL NOTES

KEY PLAN

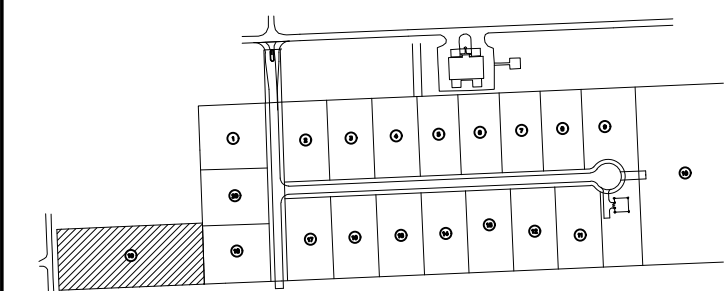

SCO ID #23-27044-01A

NO	REVISION	DATE



JKF
ARCHITECTURE

425 LYNDALE CT., SUITE F, GREENVILLE, NC 27858 252-355-1068


BEAUFORT COUNTY
COMMUNITY COLLEGE
INDUSTRIAL TRAINING CENTER
AURORA, NC

ARCHITECTURAL SITE PLAN

SCALE	DRAWING NO.
AS NOTED	
DRAWN	JRH
CHECKED	JKF
DATE	1-6-2025
PROJECT NO.	2024-10

ASPII

© COPYRIGHT, JKF ARCHITECTURE PC, JOHN K. FARKAS, AIA

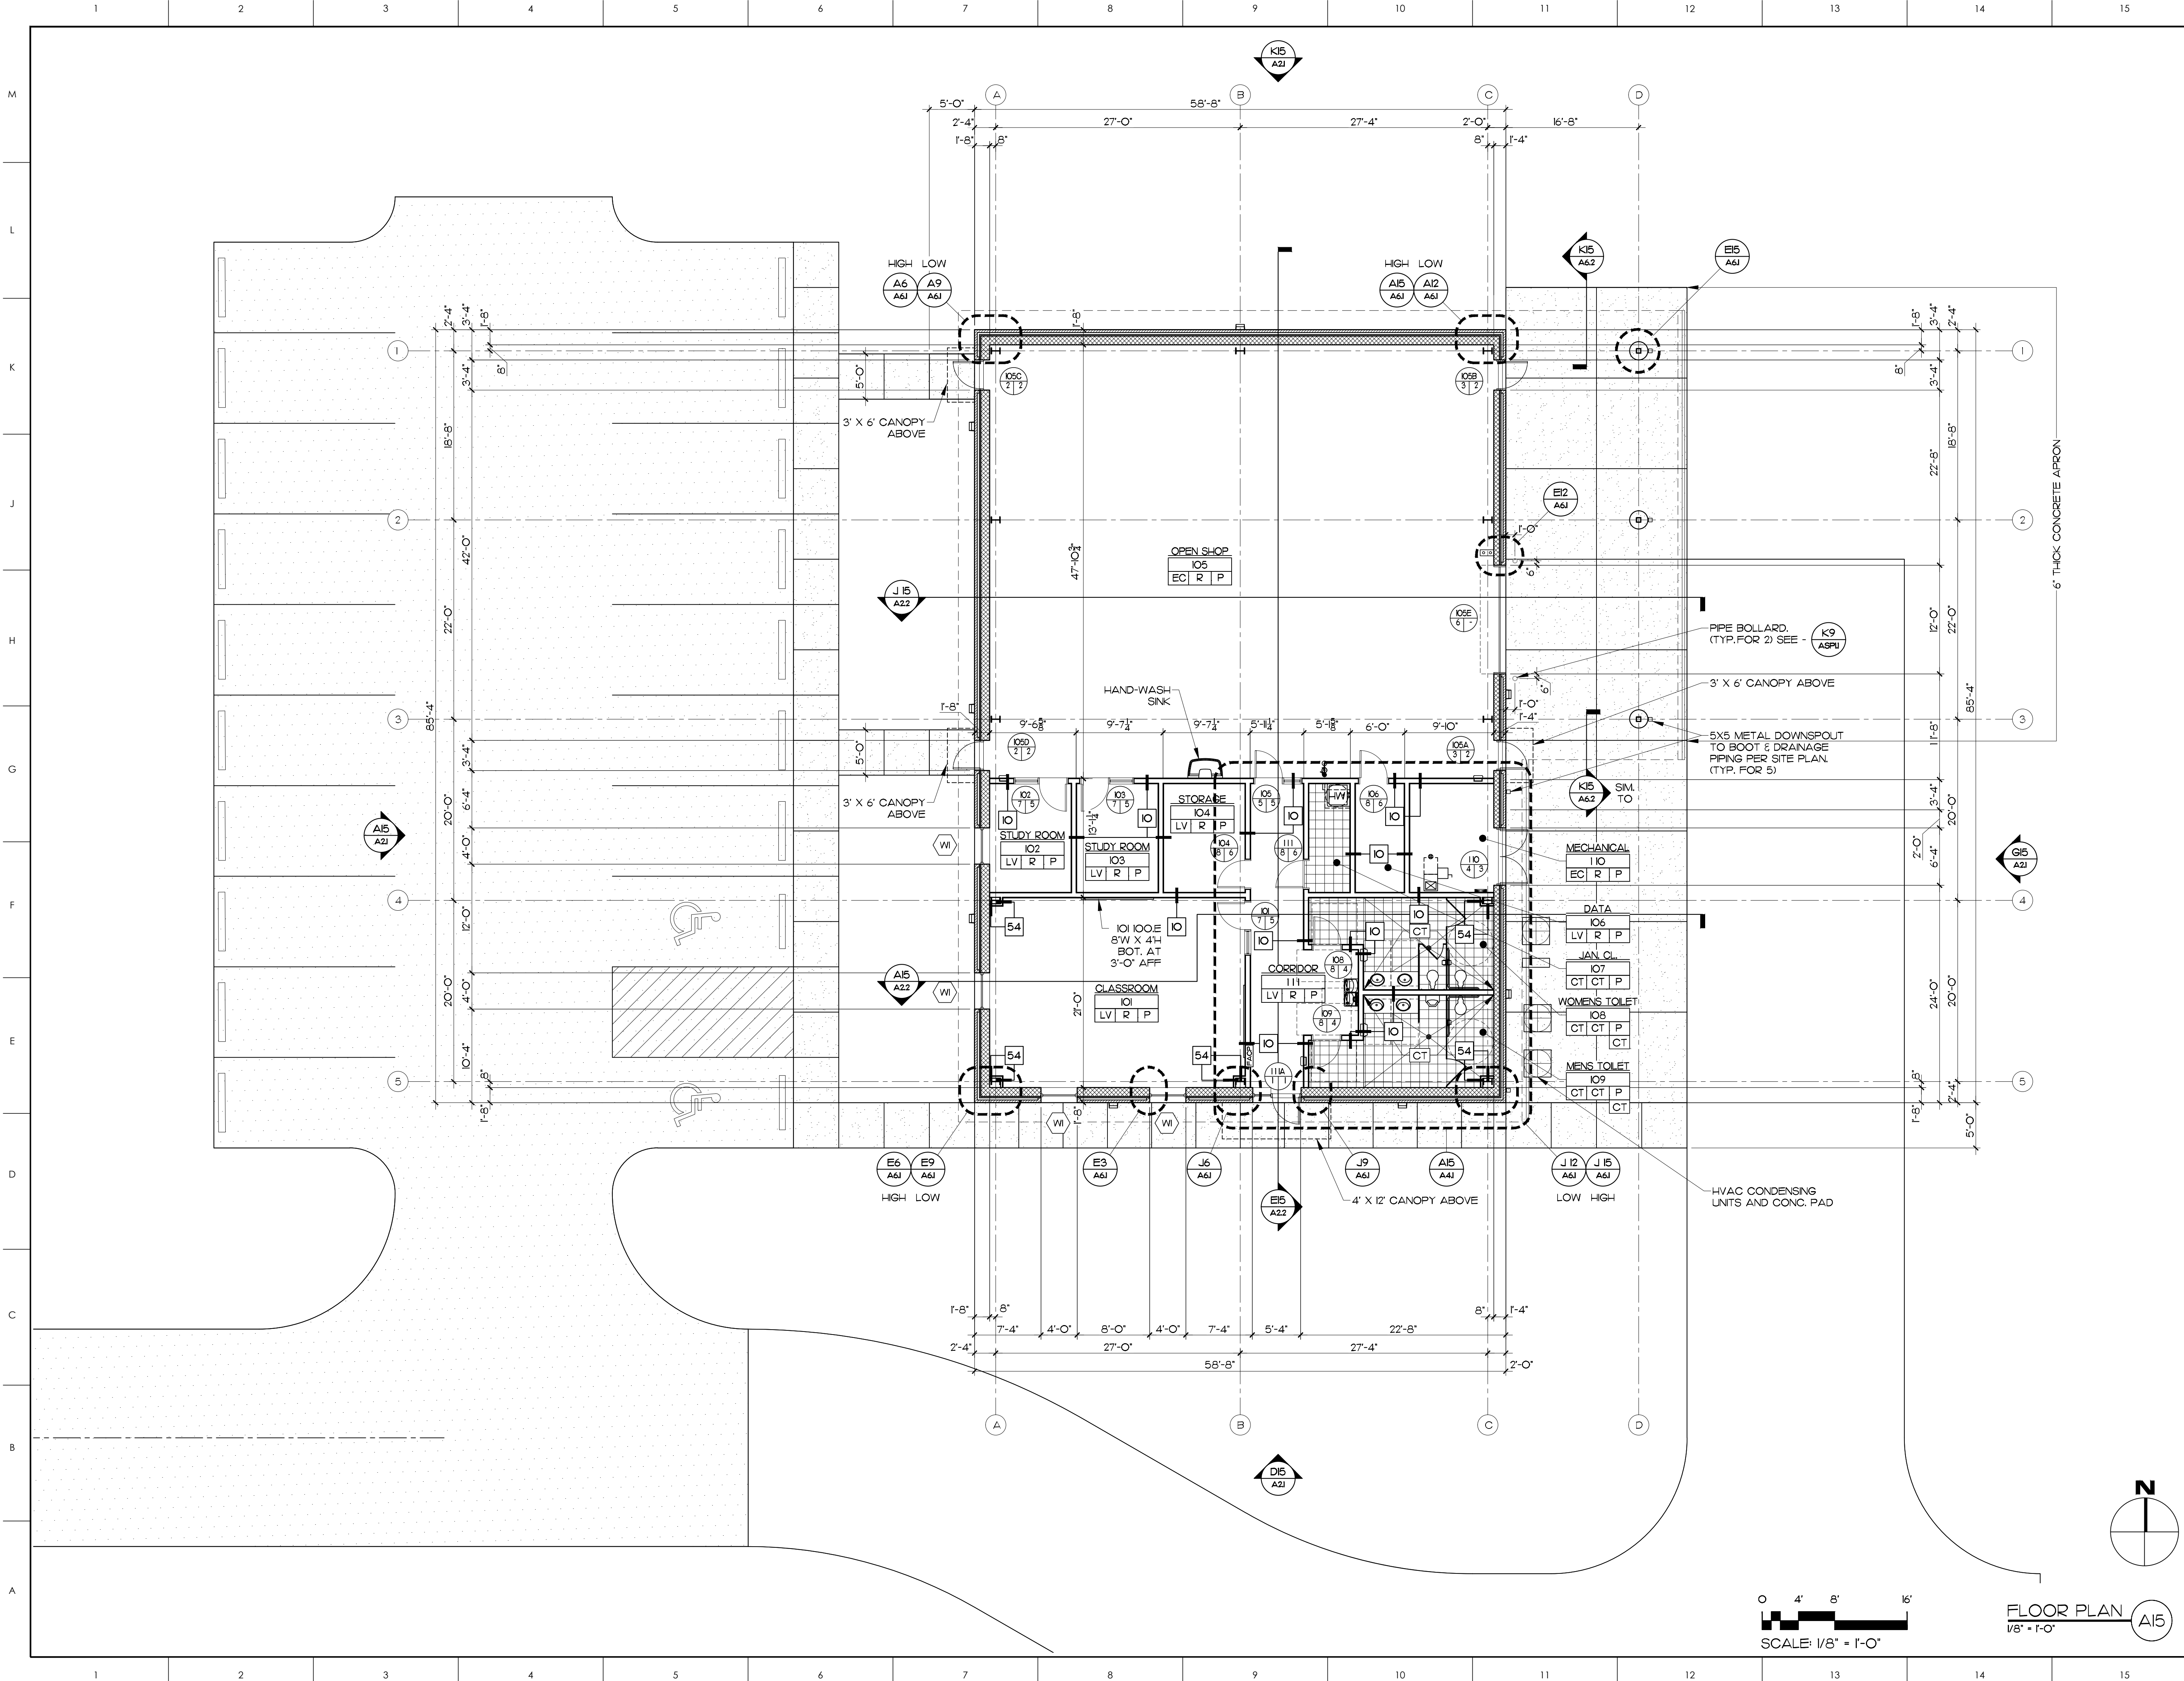

- MATERIALS KEYING LEGEND
- O76200.B - METAL DOWNSPOUT
 - IO1 IOO.E - GLASS MARKER BOARD
 - IO4416.A - SEMI-RECESSED FIRE EXTINGUISHER CABINET
 - IO4416.A - FIRE EXTINGUISHER

GENERAL NOTES

KEY PLAN

SCO ID #23-27044-01A

NO	REVISION	DATE



JKF
ARCHITECTURE

625 LYNDALE CT., SUITE F, GREENVILLE, NC 27658 252-355-1068

BEAUFORT COUNTY
COMMUNITY COLLEGE
INDUSTRIAL TRAINING CENTER
AURORA, NC

DRAWING TITLE

FLOOR PLAN

SCALE
1/8" = 1'-0"

DRAWN
JRH

CHECKED
JKF

DATE
1-6-2025

PROJECT NO.
2024-10

DRAWING NO

ALL

© COPYRIGHT, JKF ARCHITECTURE PC, JOHN K. FARKAS, AIA



- MATERIALS KEYING LEGEND**
- 042000.E - FACE BRICK
 - 042000.E6 - FACE BRICK, SHELF BRICK, SOLDIER COURSE
 - 042000.EIO - FACE BRICK, SOLDIER COURSE SILL, SPECIAL SHAPE
 - 042000.RI - CONTROL JOINT
 - 051200.A - STRUCTURAL STEEL, SEE STRUCTURAL DRAWINGS
 - 055000.G - STEEL BOLLARD, PAINTED
 - 0741 I3.A - METAL ROOF, STANDING SEAM SYSTEM
 - 0741 I3.H - METAL FASCIA
 - 0741 I3.J - METAL GUTTER
 - 0741 I3.L3 - METAL DOWNSPOUT, 5X5
 - 074213.A - METAL WALL PANEL
 - 083323.A - OVER-HEAD COLING DOOR
 - 084213.A - STOREFRONT FRAMING, THERMALLY BROKEN
 - 084213.D - ALUMINUM FRP DOOR
 - 084213.F - ALUMINUM STILE AND RAIL DOOR
 - 0851 I3.AI - ALUMINUM WINDOW ASSEMBLY, FIXED WINDOW
 - 088000.BI - I" INSULATING GLASS-LOW E
 - 091 I3.A - PAINT FINISH, EXTERIOR SYSTEM
 - 105300.A2 - ALUMINUM CANOPY ASSEMBLY WITH SUPPORT RODS
 - 230000.J - MECH. LOUVER-SEE HVAC DRAWINGS
 - 260000.A - EXTERIOR LIGHT FIXTURE

GENERAL NOTES

KEY PLAN

SCO ID #23-27044-01A

NO	REVISION	DATE

JOHN K. FARKAS
REGISTERED ARCHITECT
1/23/2025
Aurora, NC

JKF
ARCHITECTURE

425 LYNNDAL CT., SUITE F, GREENVILLE, NC 27858 252-355-1068

BEAUFORT COUNTY
COMMUNITY COLLEGE
INDUSTRIAL TRAINING CENTER
AURORA, NC

DRAWING TITLE
EXTERIOR ELEVATIONS

SCALE 1/8"=1'-0"	DRAWING NO A2.1
DRAWN JRH	
CHECKED JKF	
DATE 1-6-2025	
PROJECT NO. 2024-10	



MATERIALS KEYING LEGEND

GENERAL NOTES

KEY PLAN

SCO ID #23-27044-01A

NO	REVISION	DATE

SEAL



JKF
ARCHITECTURE

625 LYNNDALE CT., SUITE F, GREENVILLE, NC 27838 252-355-1068

BEAUFORT COUNTY
COMMUNITY COLLEGE
INDUSTRIAL TRAINING CENTER
AURORA, NC

DRAWING TITLE

BUILDING SECTIONS

SCALE

1/8" = 1'-0"

DRAWN

JRH

CHECKED

JKF

DATE

1-6-2025


PROJECT NO.

2024-10

DRAWING NO

A2.2

© COPYRIGHT, JKF ARCHITECTURE PC, JOHN K. FARKAS, AIA

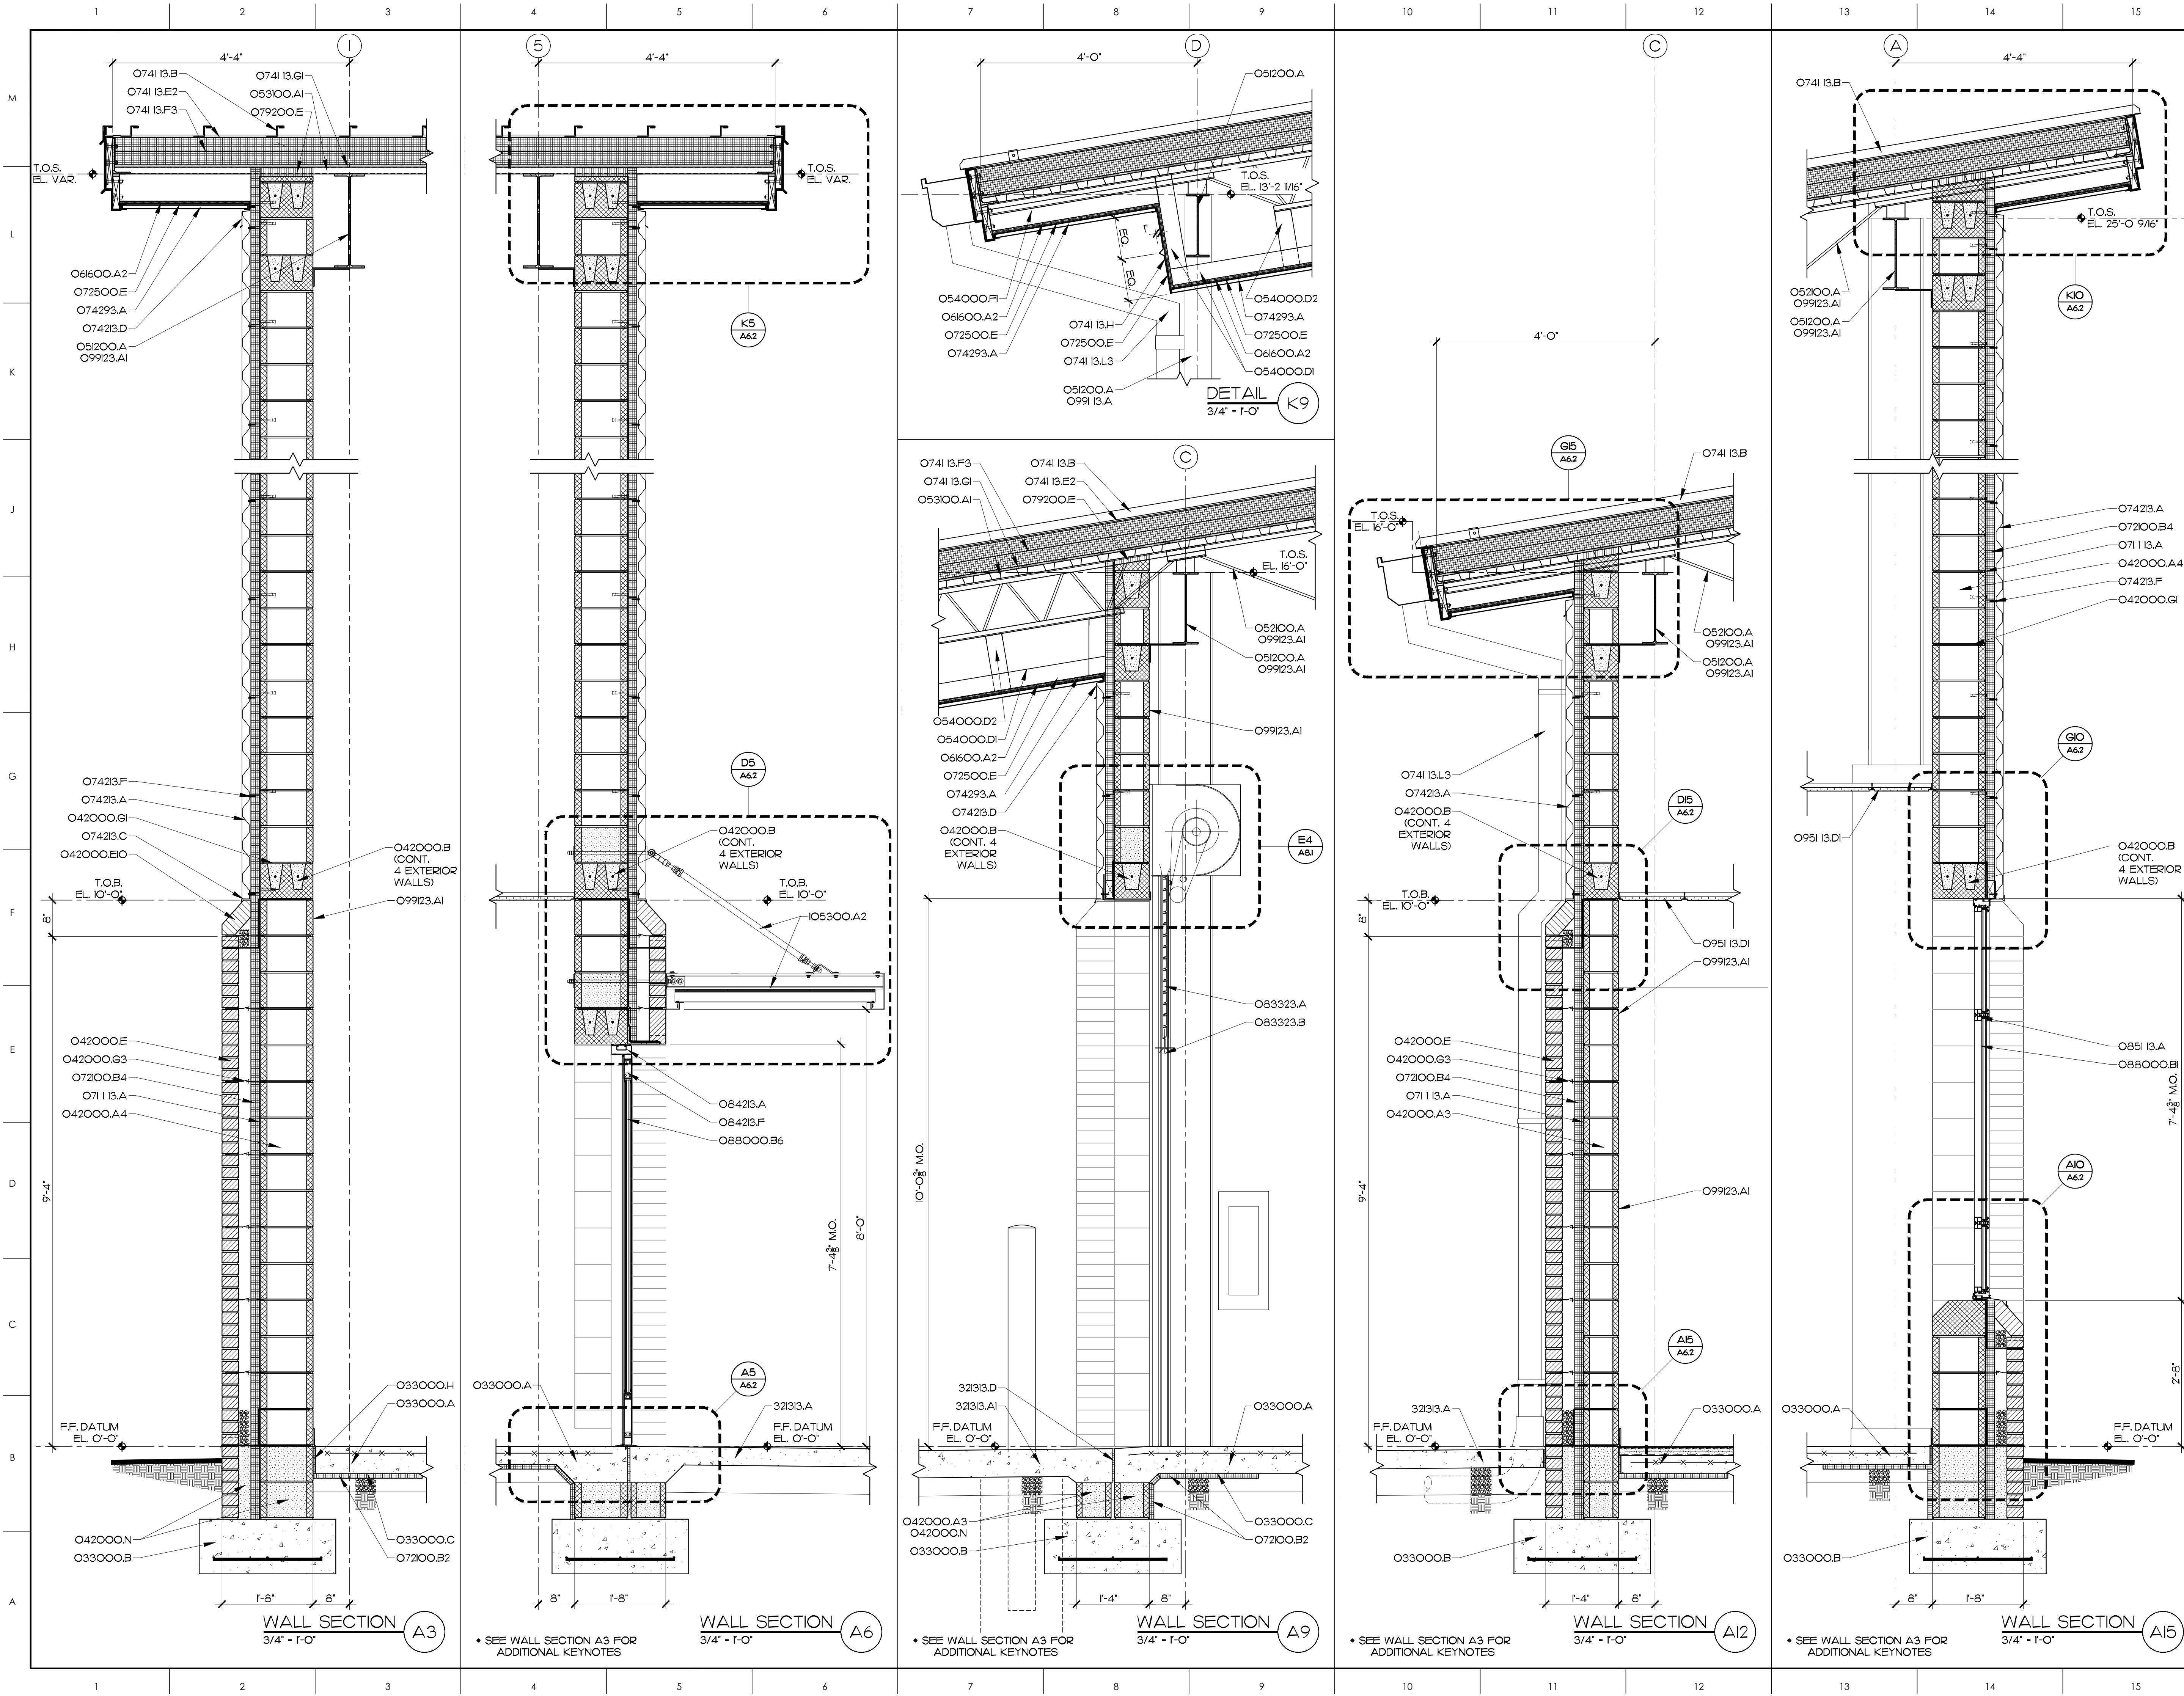

MATERIALS KEYING LEGEND	
O33000.A	- CONCRETE SLAB ON GRADE, SEE
O33000.B	- STRUCTURAL FOOTING, SEE STRUCTURAL
O33000.C	- VAPOR BARRIER, SEE STRUCTURAL
O33000.H	- COMPRESSIBLE FILL
O42000.A3	- CONCRETE MASONRY UNIT, 8"
O42000.A4	- CONCRETE MASONRY UNIT, 12"
O42000.B	- CONCRETE MASONRY, BOND BEAM
O42000.E	- FACE BRICK
O42000.EIO	- FACE BRICK, SOLDIER COURSE SILL, SPECIAL SHAPE
O42000.GI	- HORIZONTAL JOINT REINFORCING AT 16" O.C. VERT.
O42000.G3	- HORIZONTAL JOINT REINFORCING AT 16" VERT. & BRICK TIE EYES AT 24" O.C. HORIZ.
O42000.N	- GROUT SOLID
O5200.A	- STRUCTURAL STEEL, SEE STRUCTURAL DRAWINGS
O5200.A	- STEEL BAR JOIST, SEE STRUCTURAL DRAWINGS
O53000.AI	- ROOF DECK, 1/2"
O54000.D1	- COLD FORMED METAL FRAMING, 3 5/8" STUD AT 16" O.C.
O54000.D2	- COLD FORMED METAL FRAMING, 3 5/8" STUD AT 48" O.C.
O54000.FI	- COLD FORMED METAL FRAMING, 6" STUD AT 16" O.C.
O56000.A2	- PLYWOOD SHEATHING, 1/2" THICK
O711 I3.A	- BITUMINOUS DAMPROOFING
O7200.B2	- 1" RIGID INSULATION
O7200.B4	- 2" RIGID INSULATION
O72500.E	- BUILDING WRAP
O741 I3.B	- METAL ROOF, STANDING SEAM PANEL
O741 I3.E2	- SELF ADHERING SHEET
O741 I3.F3	- RIGID INSULATION, 6" THICK
O741 I3.GI	- GLASS-MAT GYP. SHEATHING, 1/2" THICK
O741 I3.H	- METAL FASCIA
O741 I3.L3	- METAL DOWNSPOUT, 5X5
O74213.A	- METAL WALL PANEL
O74213.C	- METAL SILL FLASHING
O74213.D	- METAL CLOSURE TRIM
O74213.F	- 2" METAL Z-FLUERING CHANNEL, 16" O.C.
O74213.A	- METAL SOFFIT PANELS
O79200.E	- COMPRESSIBLE FILL
O83323.A	- OVER-HEAD COLING DOOR
O83323.B	- OVER-HEAD COLING DOOR, METAL TRACK
O84213.A	- STOREFRONT FRAMING, THERMALLY BROKEN
O84213.F	- ALUMINUM STILE AND RAIL DOOR
O851 I3.A	- ALUMINUM WINDOW ASSEMBLY
O88000.BI	- 1" INSULATING GLASS-LOW E
O88000.B6	- 1" INSULATING GLASS, TEMPERED LOW E
O951 I3.DI	- ACOUSTICAL PANEL, CEILING TILE, 2X2
O991 I3.A	- PAINT FINISH- EXTERIOR SYSTEM
O99123.AI	- PAINT FINISH- INTERIOR SYSTEM
O53000.A2	- ALUMINUM CANOPY ASSEMBLY WITH SUPPORT RODS
32333.A	- CONCRETE SIDEWALK, 4" THICK
32333.AI	- CONCRETE SIDEWALK, 6" THICK
32333.D	- COMPRESSIBLE FILL

GENERAL NOTES

KEY PLAN

SCO ID #23-27044-01A

NO REVISION DATE












625 LYNDALE CT., SUITE F, GREENVILLE, NC 27658 252-355-1068

BEAUFORT COUNTY
COMMUNITY COLLEGE
INDUSTRIAL TRAINING CENTER
AURORA, NC

WALL SECTIONS

SCALE	3/4" = 1'-0"	DRAWING NO.	
DRAWN	JRH		
CHECKED	JKF		
DATE	1-6-2025		
PROJECT NO.	2024-10		

A3.1

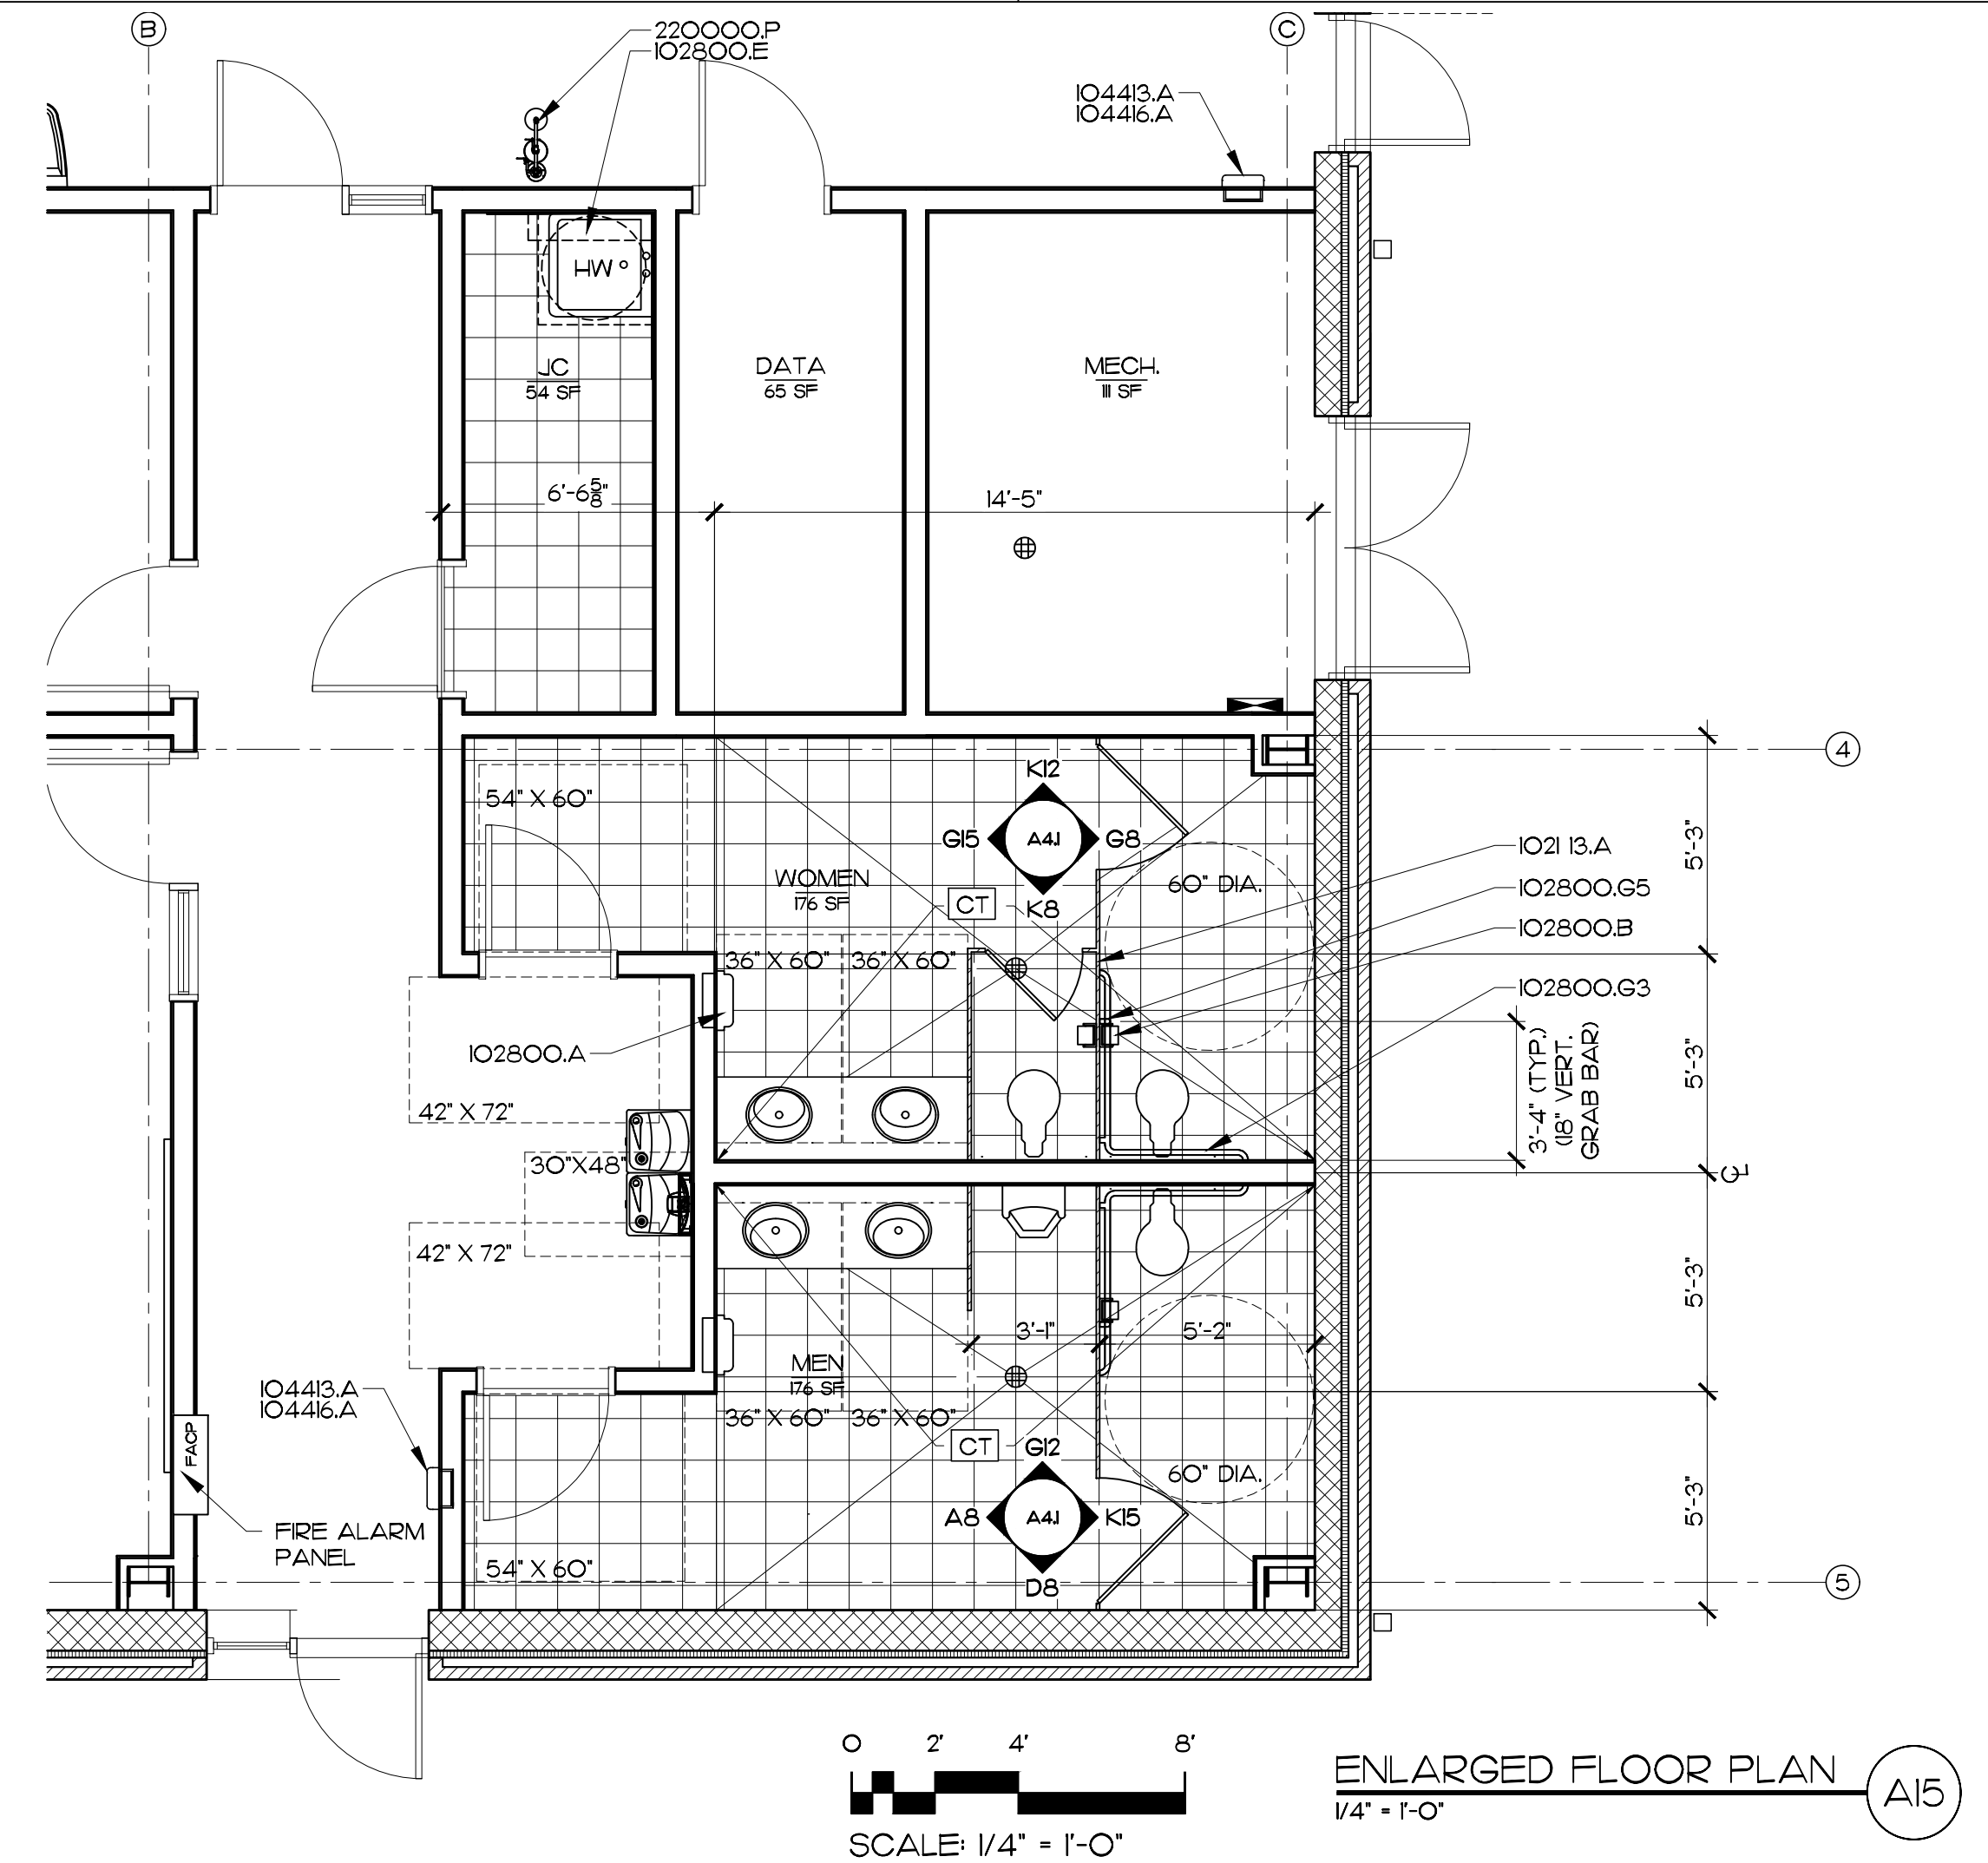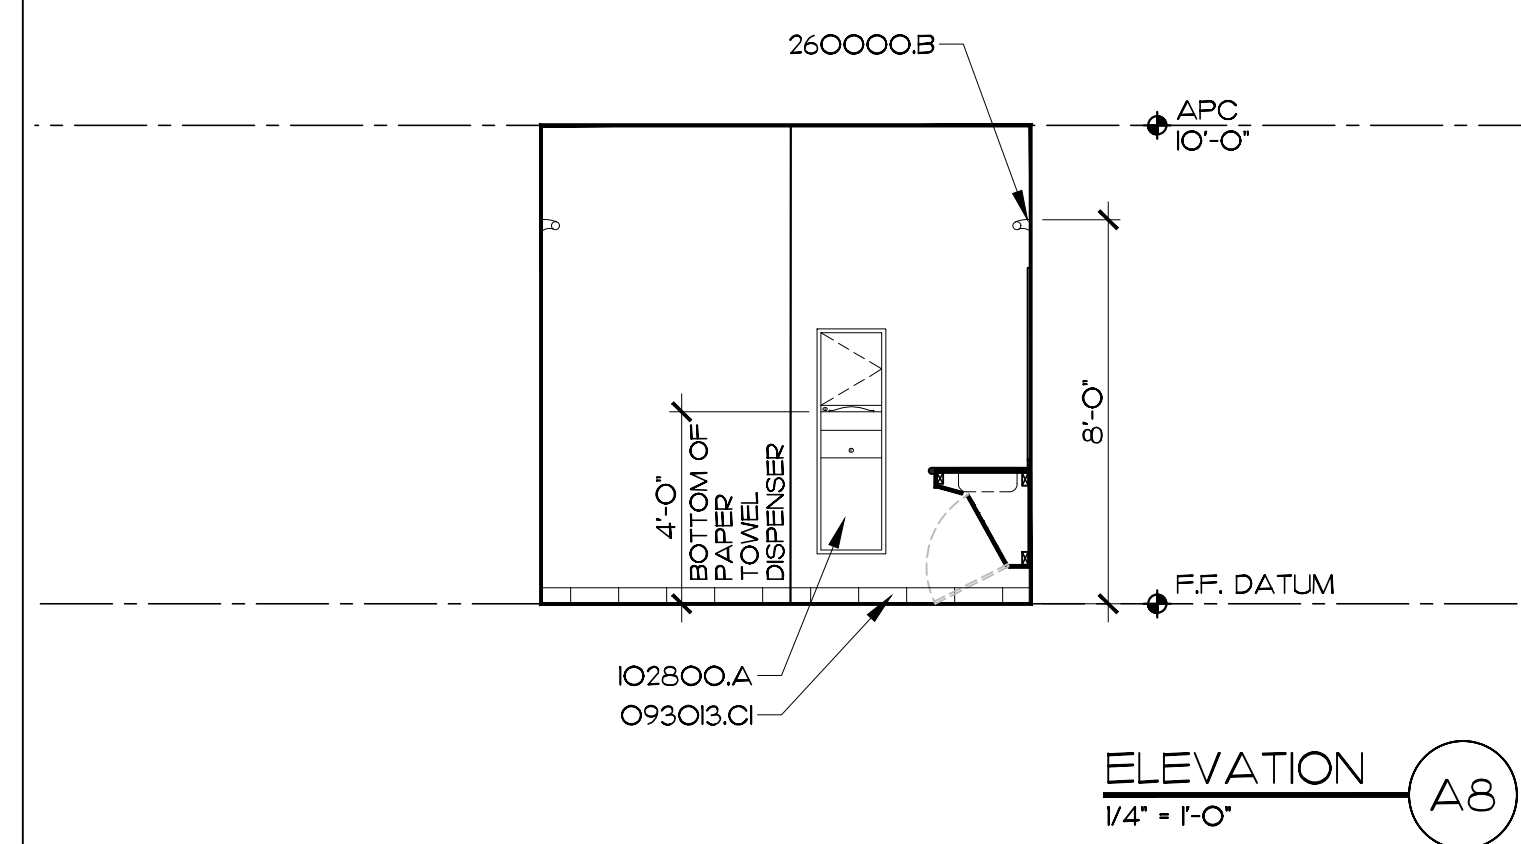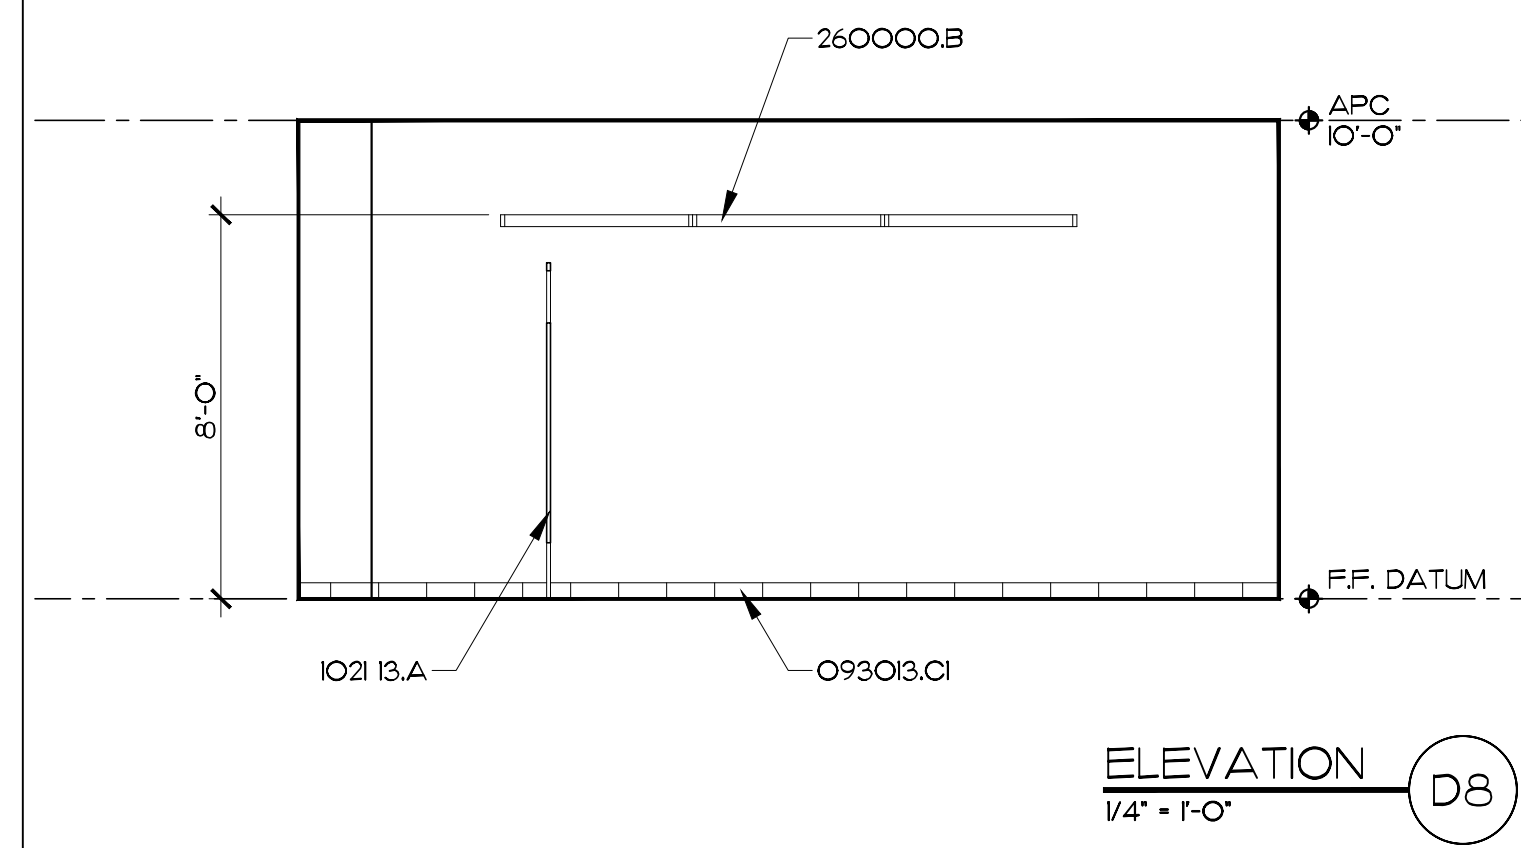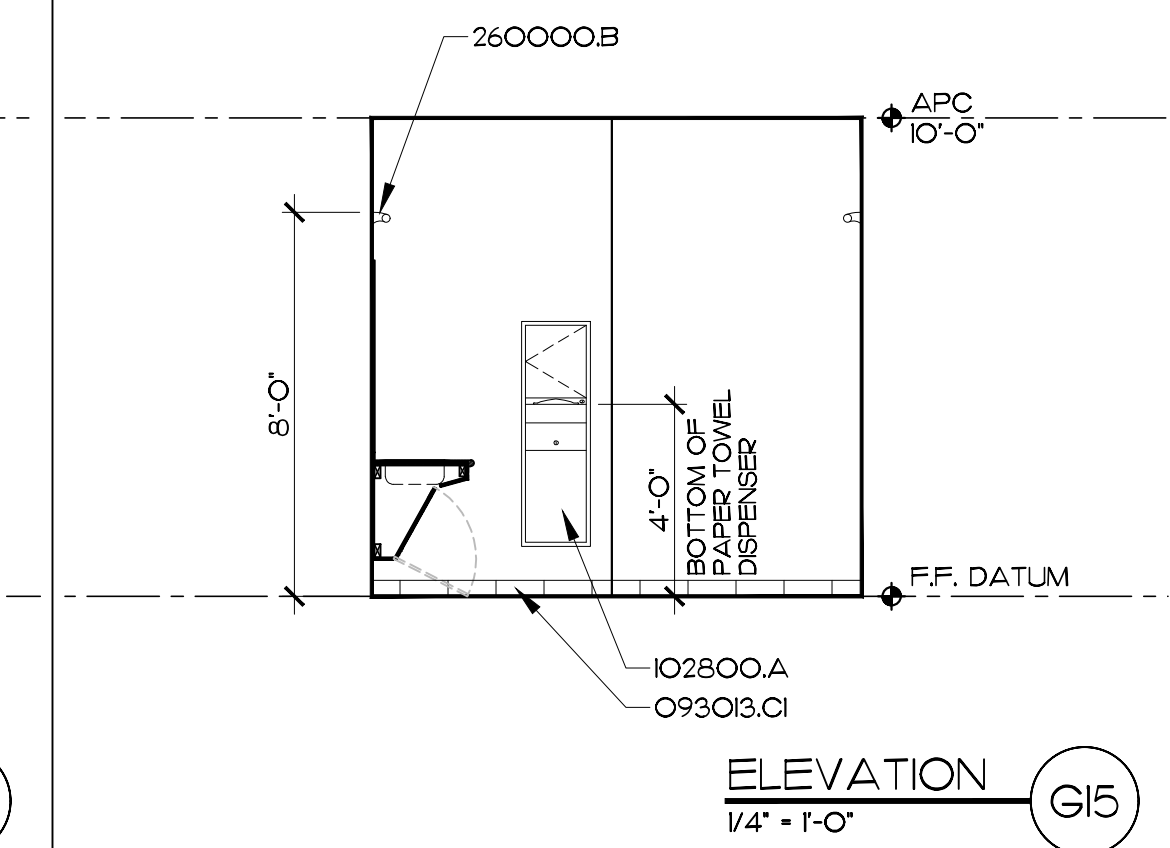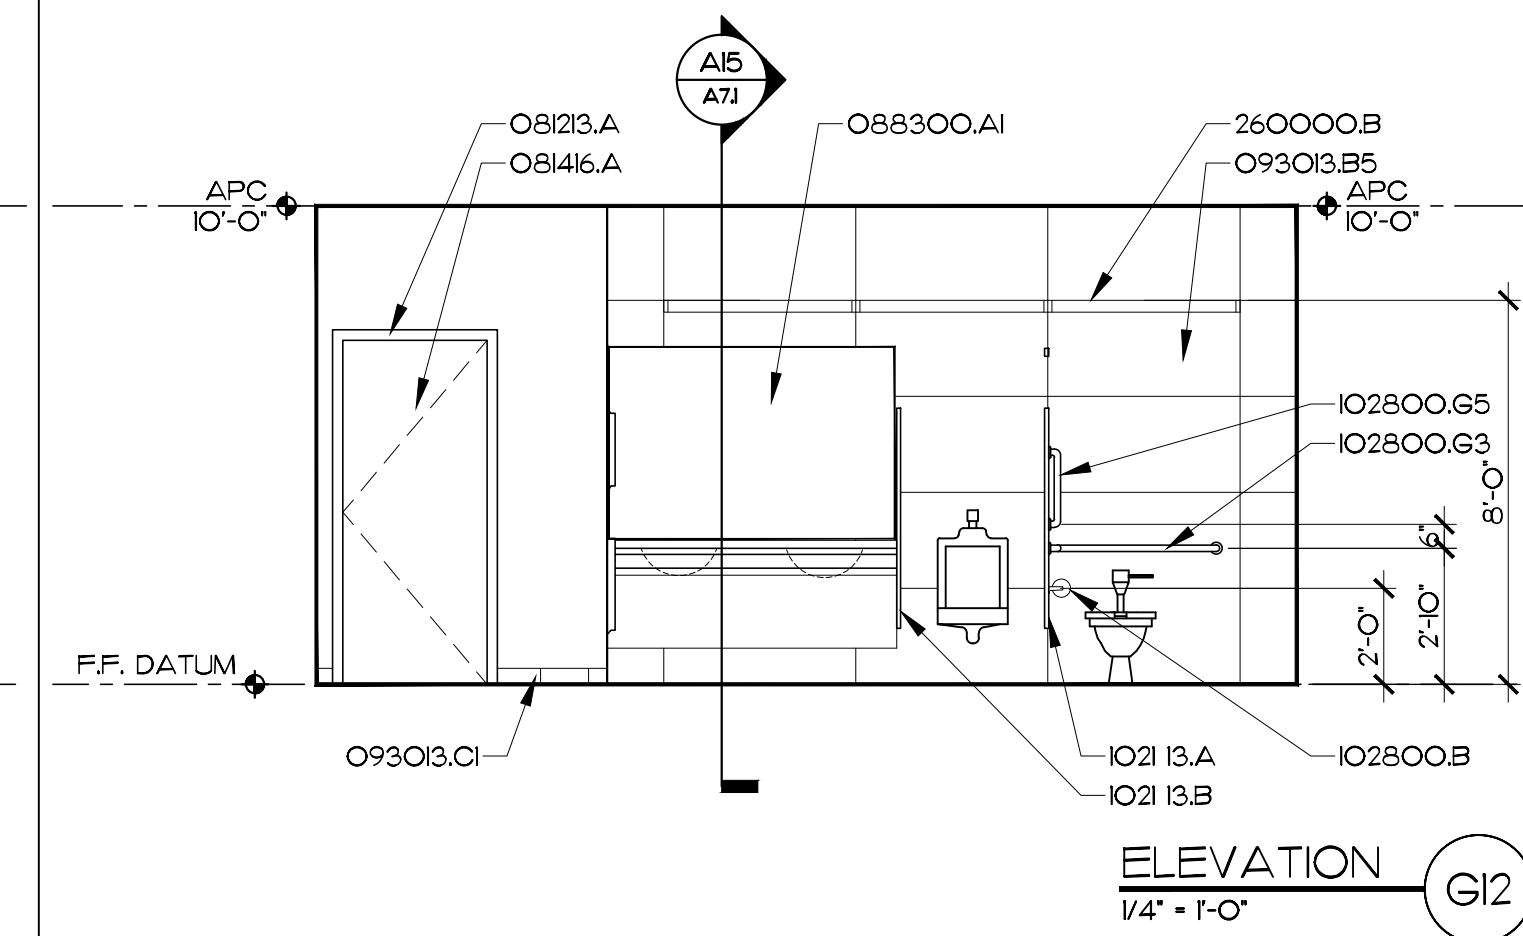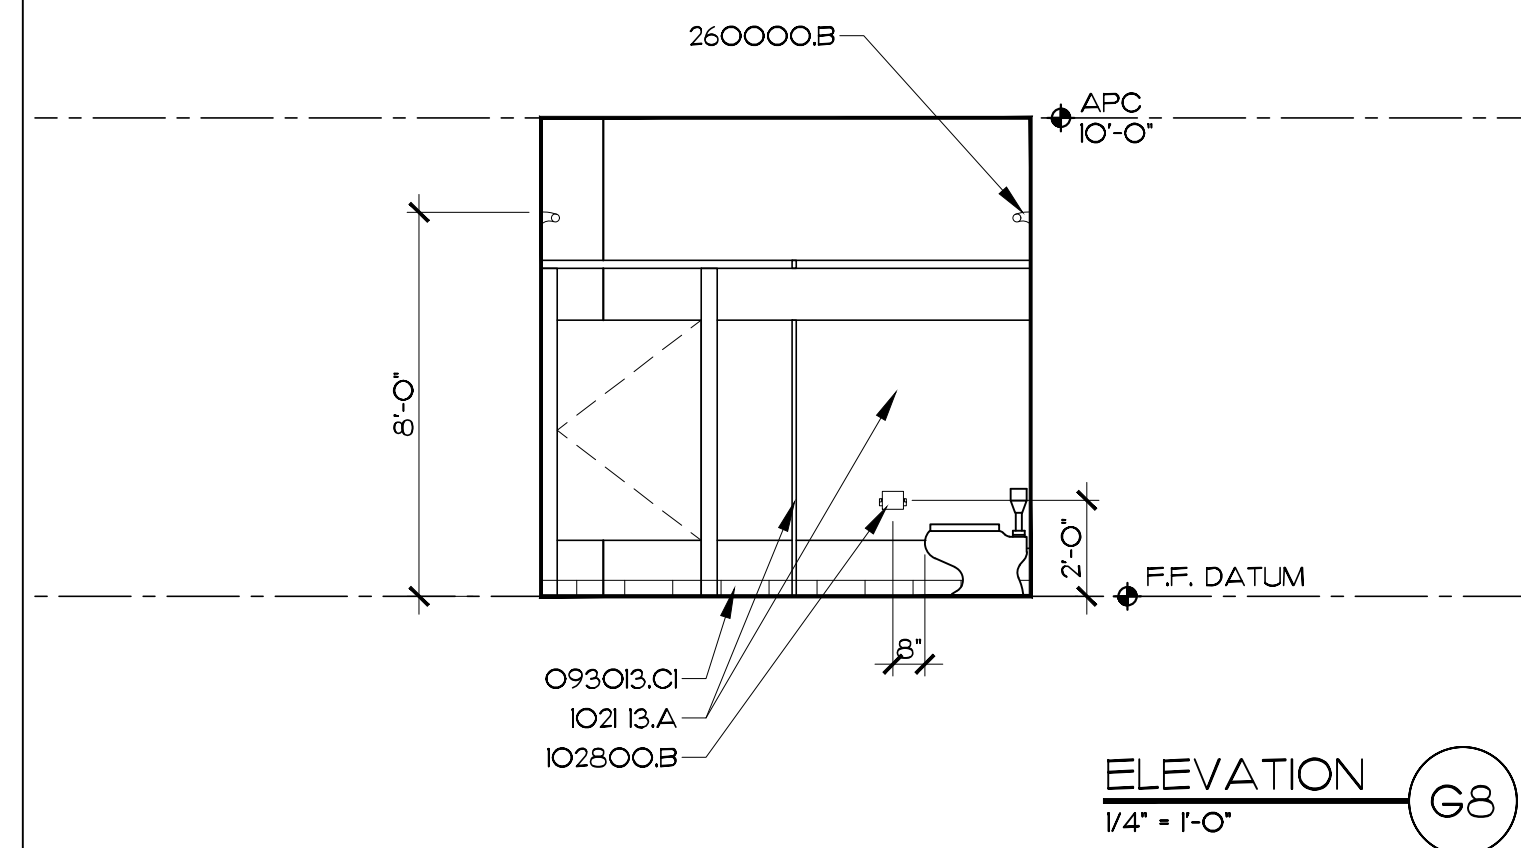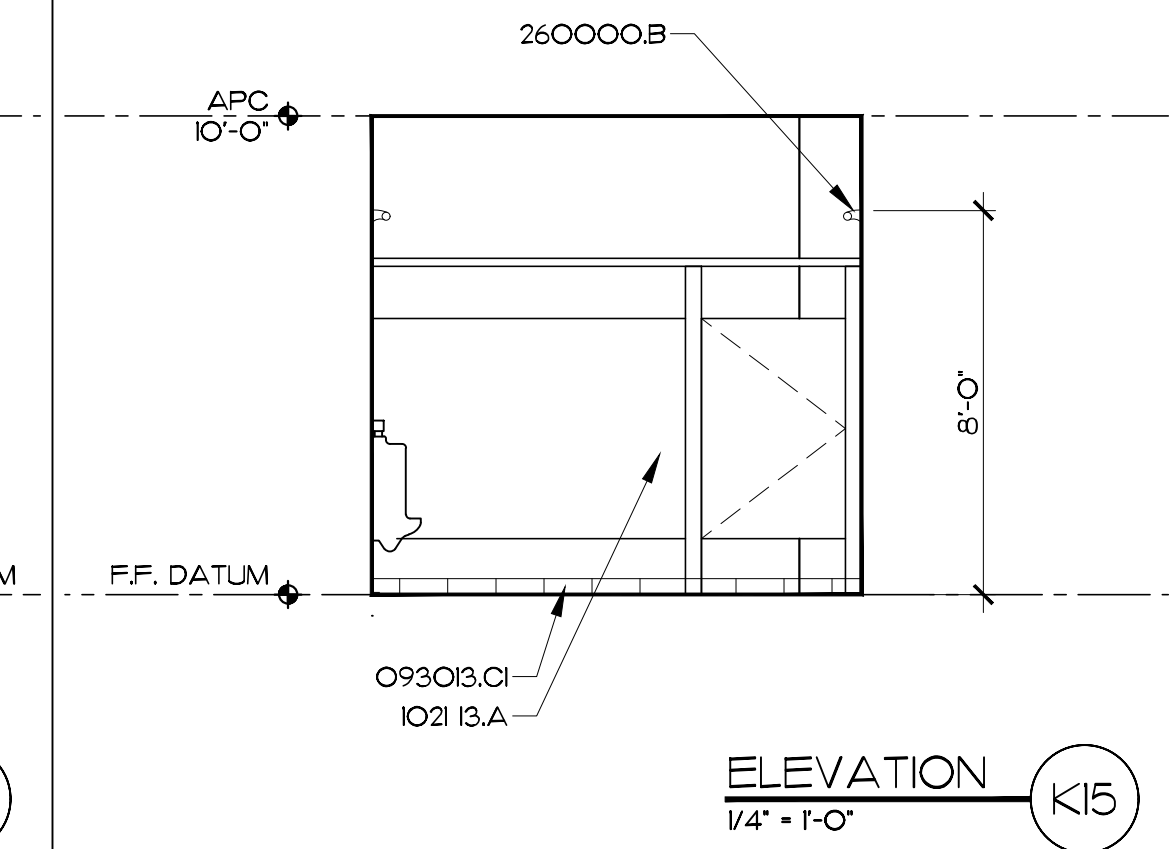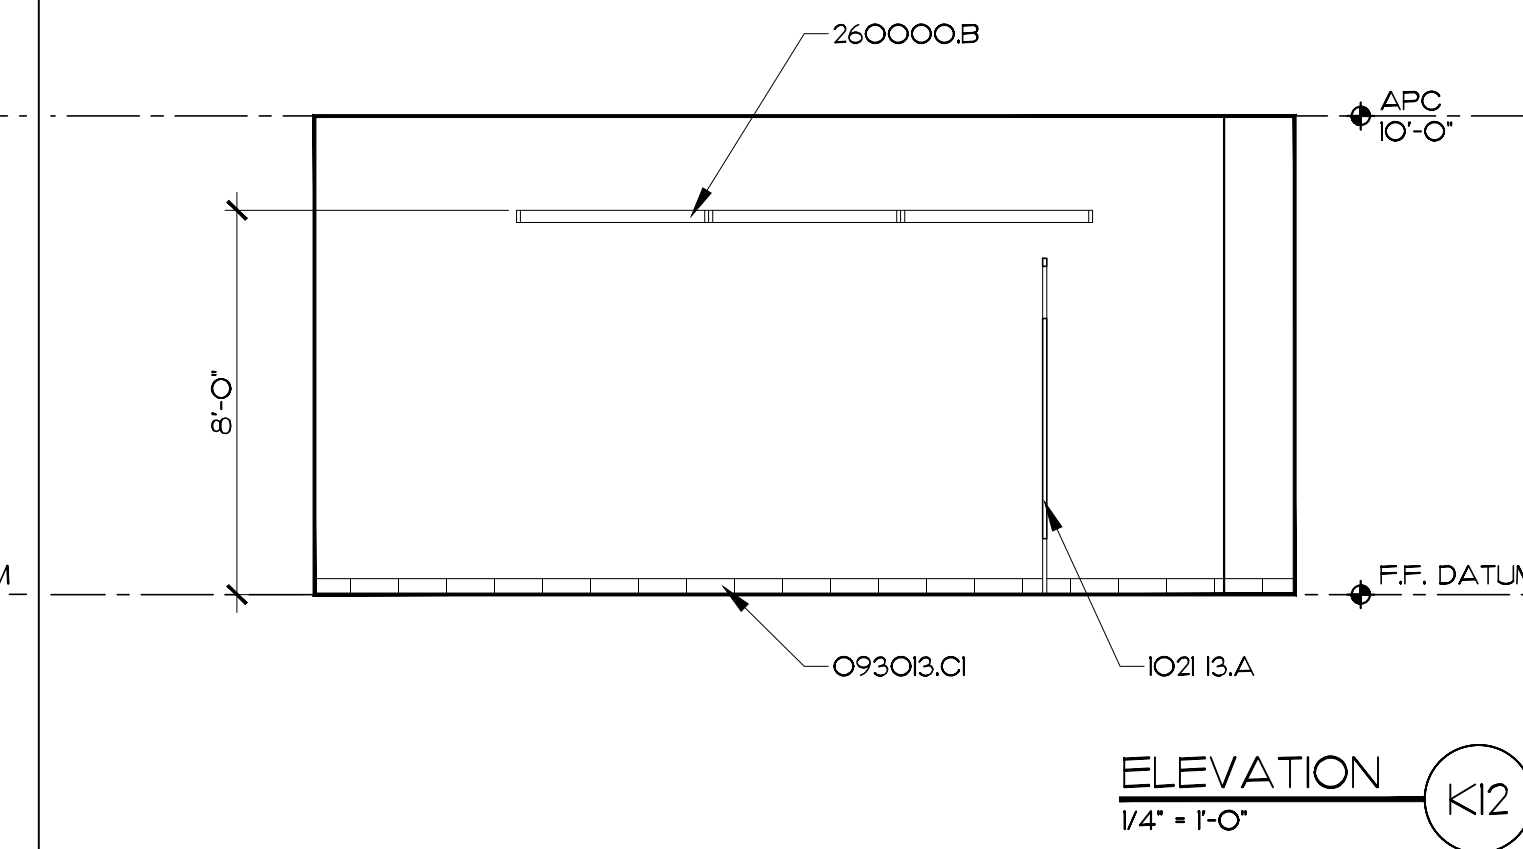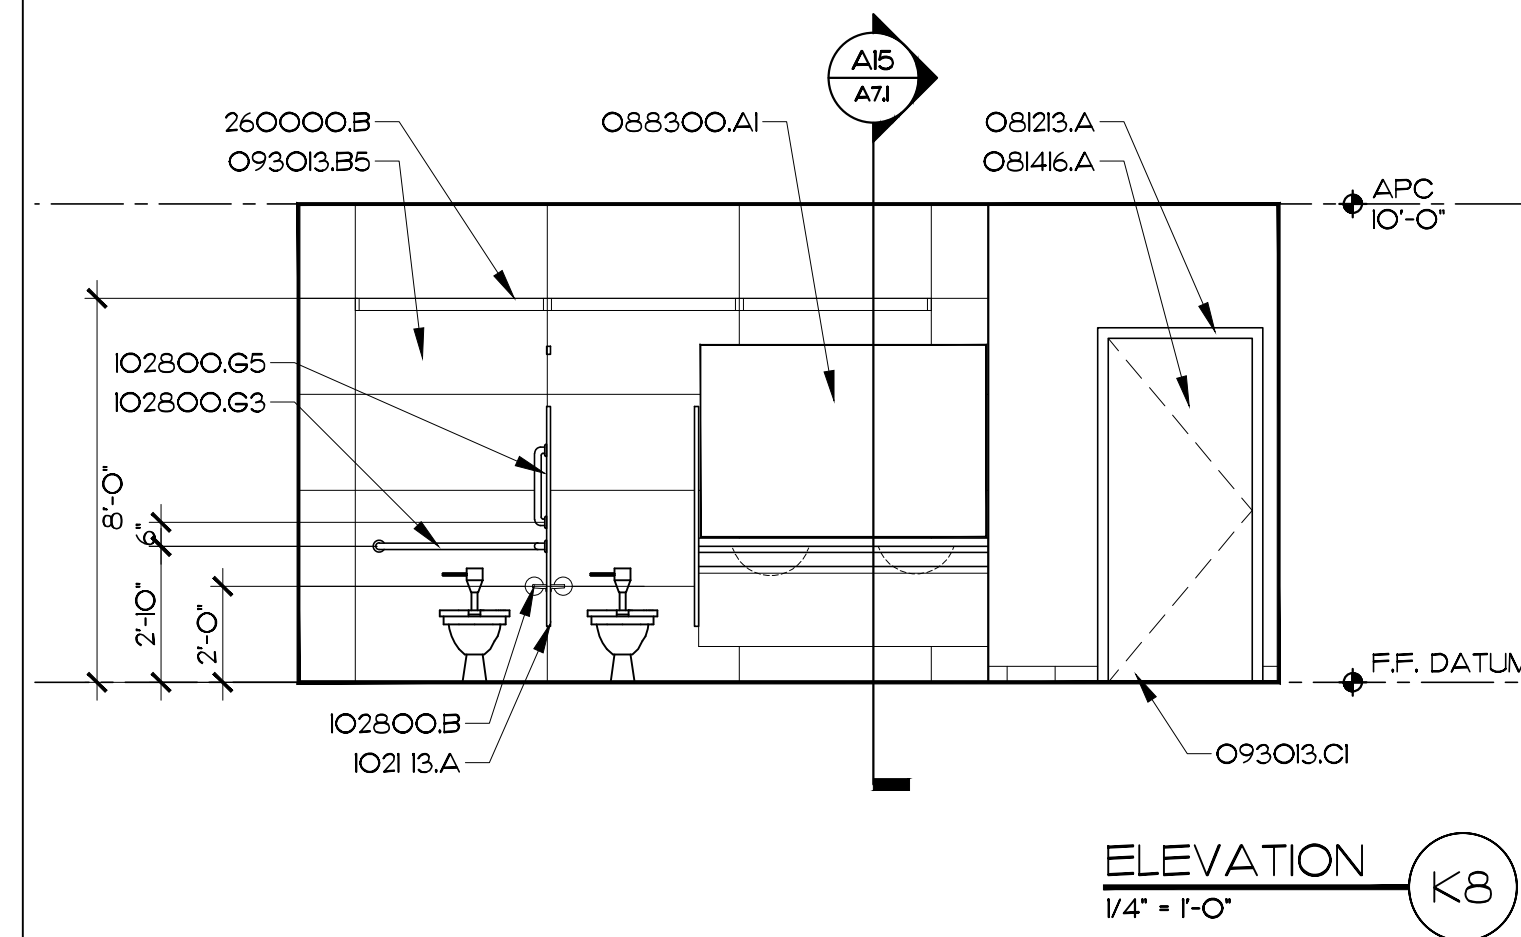


MATERIALS KEYING LEGEND	
08I23.A	- HOLLOW METAL FRAME
08I46.A	- SOLID CORE WOOD DOOR, FLUSH
08B30O.AI	- 1/4" GLASS MIRROR
093OI3.B5	- CERAMIC TILE, 24X48
093OI3.CI	- CERAMIC TILE, SPECIAL SHAPE, COVE BASE, 4" HIGH
IO2I I3.A	- TOILET COMPARTMENT
IO2I I3.B	- URINAL SCREEN
IO28OO.A	- TOWEL DISPENSER/WASTE RECEPTACLE
IO28OO.B	- TOILET TISSUE DISPENSER
IO28OO.E	- MOP AND BROOM HOLDER W/ UTILITY SHELF
IO28OO.G3	- 42X54 GRAB BAR
IO28OO.G5	- 18" VERT. GRAB BAR
IO44I3.A	- SEMI-RECESSED FIRE EXTINGUISHER CABINET
IO44I6.A	- FIRE EXTINGUISHER
22OOOO.P	- EMERGENCY SHOWER W/WEYEWASH
26OOOO.B	- INTERIOR LIGHT FIXTURE

GENERAL NOTES

KEY PLAN

SCO ID #23-27044-01A

NO	REVISION	DATE
----	----------	------

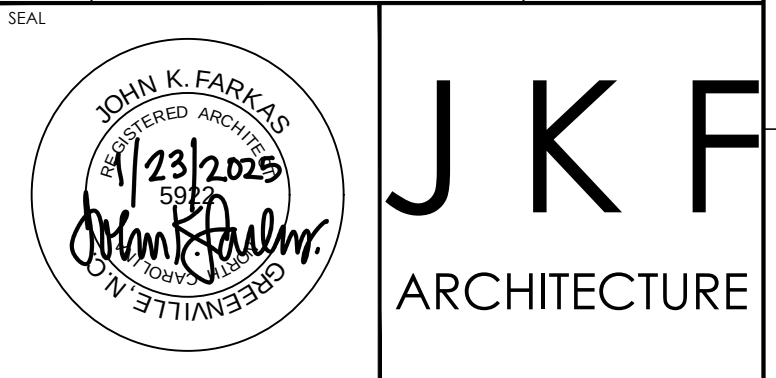


625 LYNDALE CT., SUITE F, GREENVILLE, NC 27858 252-355-1068

BEAUFORT COUNTY
COMMUNITY COLLEGE
INDUSTRIAL TRAINING CENTER
AURORA, NC

DRAWING TITLE

ENLARGED FLOOR PLAN
AND INTERIOR ELEVATIONS

SCALE	DRAWING NO
1/4" = 1'-0"	
DRAWN	
JRH	
CHECKED	
JKF	A4.1
DATE	
1-6-2025	
PROJECT NO.	
2024-10	

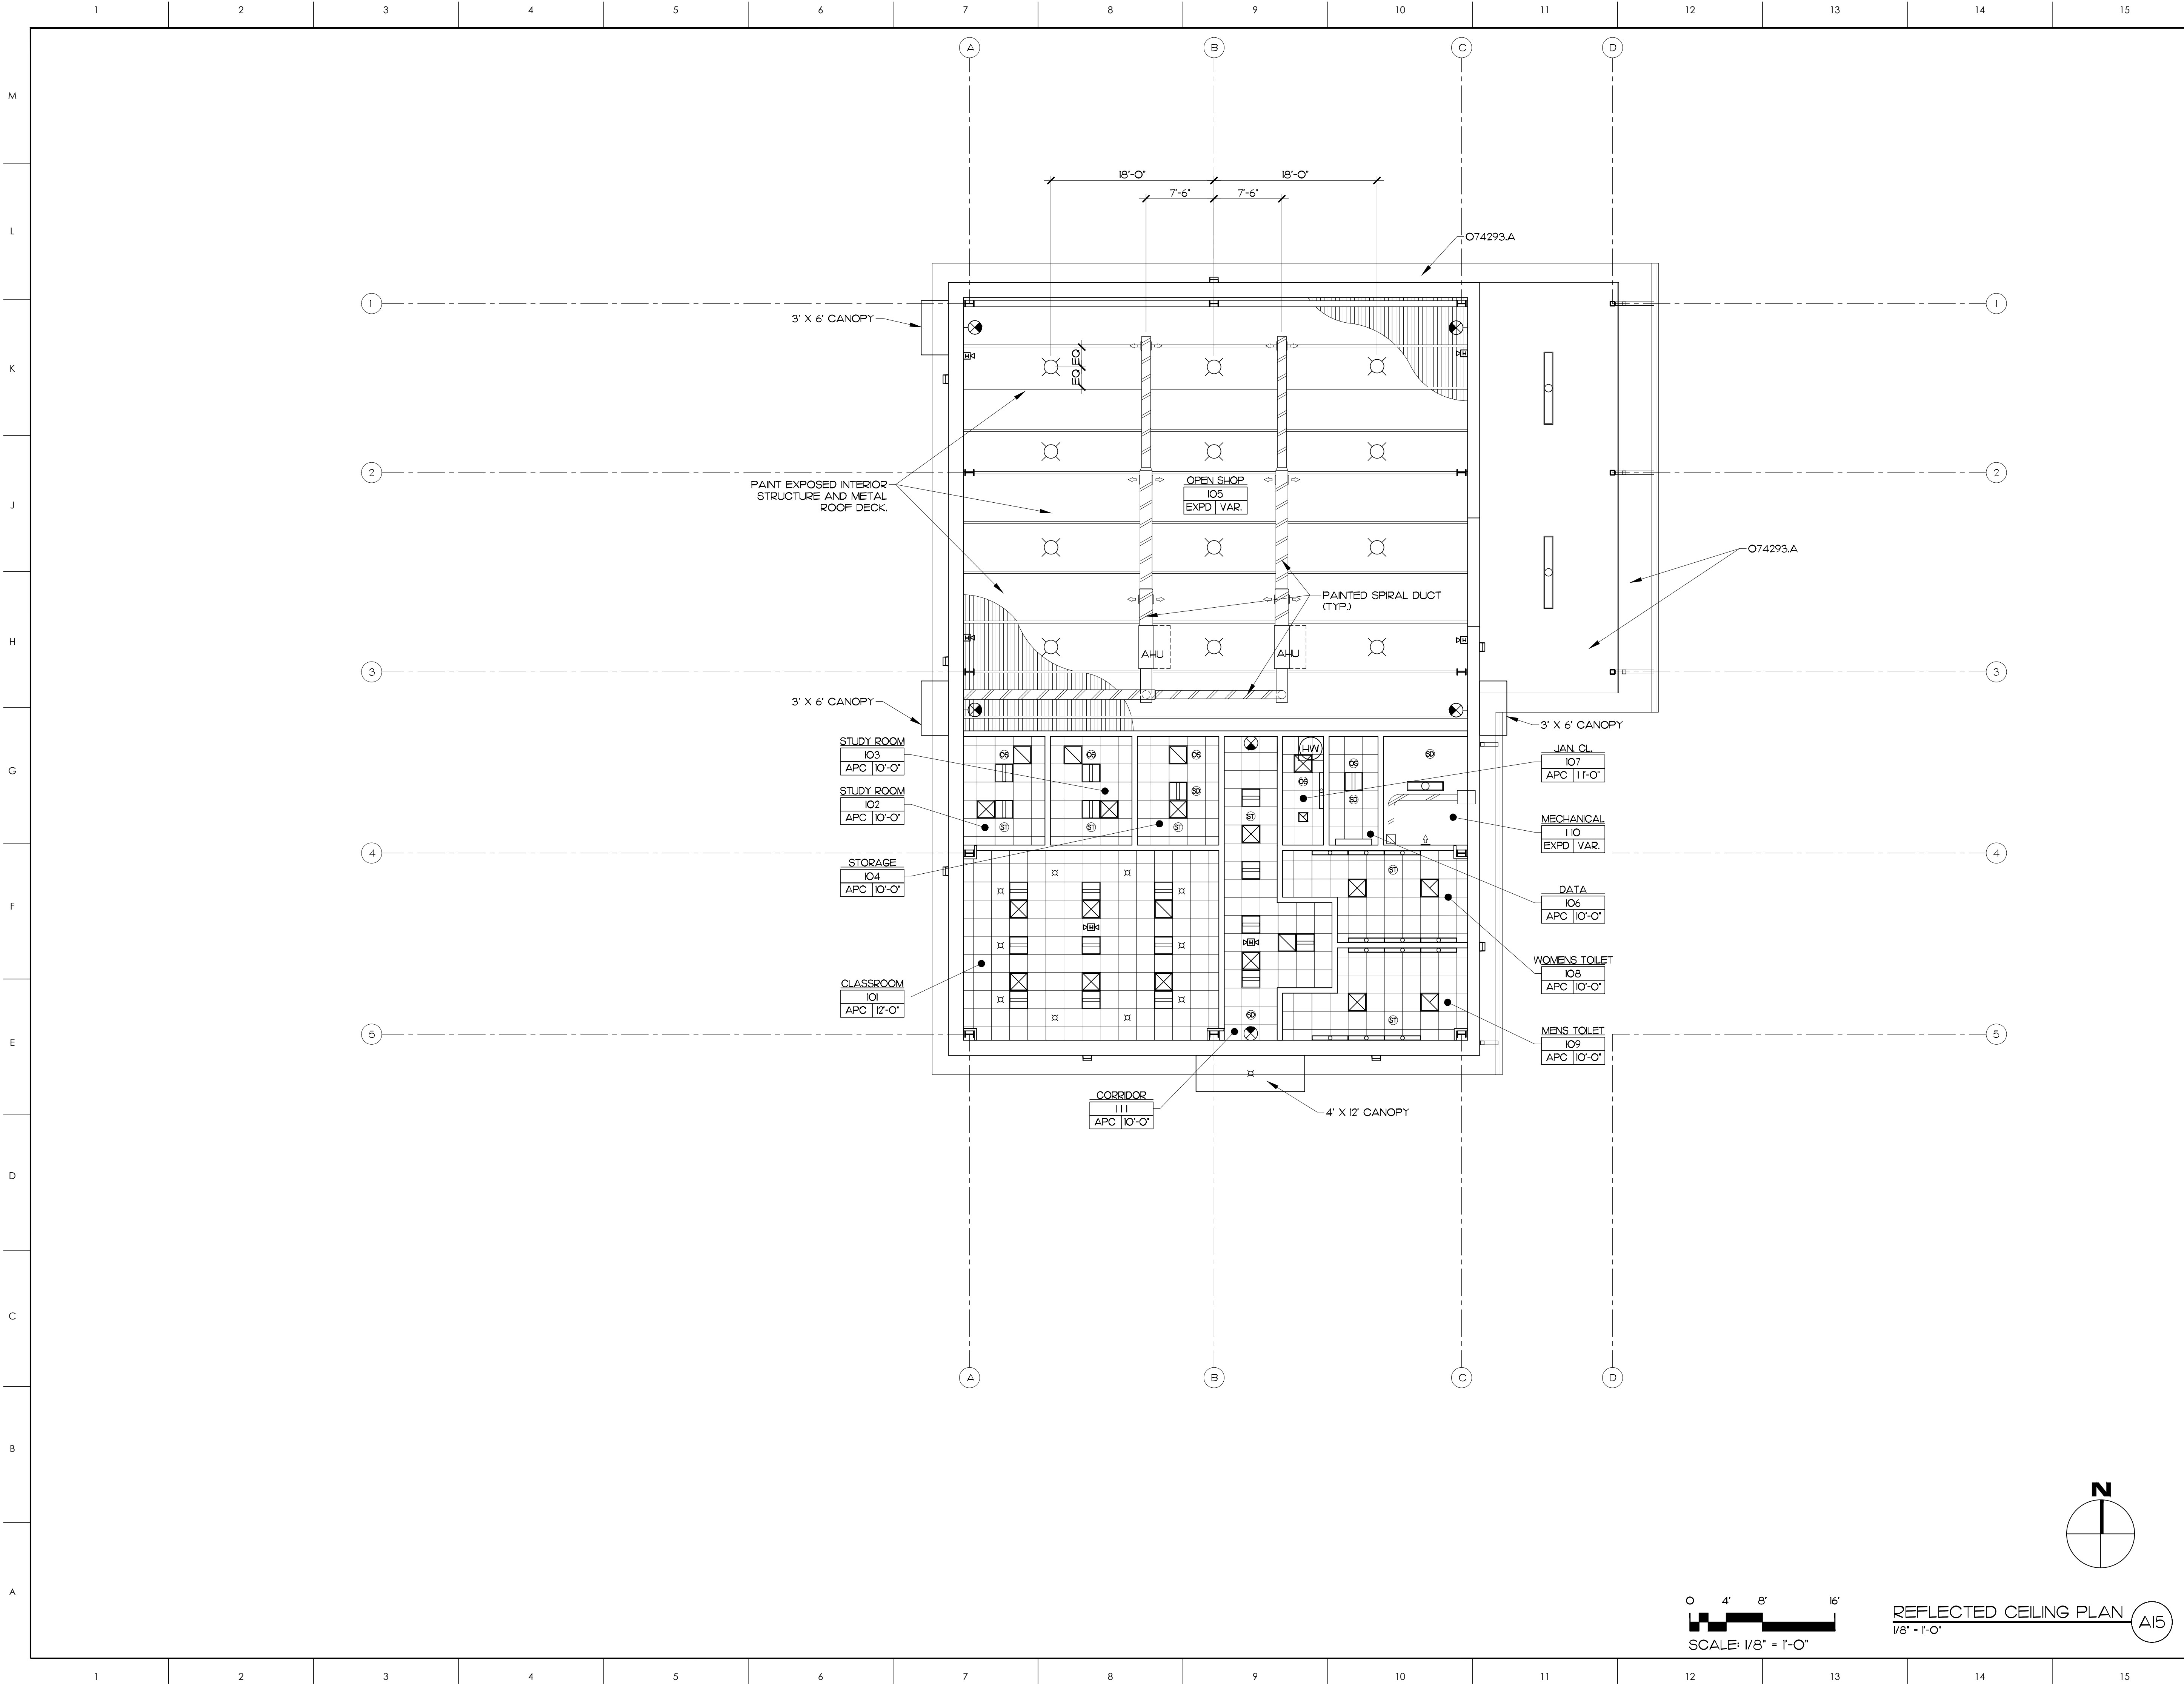

MATERIALS KEYING LEGEND
O74293.A - METAL SOFFIT PANELS

GENERAL NOTES

KEY PLAN

SCO ID #23-27044-01A

NO	REVISION	DATE

SEAL


JKF
ARCHITECTURE

625 LYNNDALE CT., SUITE F, GREENVILLE, NC 27858 252-355-1068

BEAUFORT COUNTY
COMMUNITY COLLEGE
INDUSTRIAL TRAINING CENTER
AURORA, NC

DRAWING TITLE
REFLECTED CEILING PLAN

SCALE 1/8" = 1'-0"	DRAWING NO. A5.1
DRAWN JRH	
CHECKED JKF	
DATE 1-6-2025	
PROJECT NO. 2024-10	

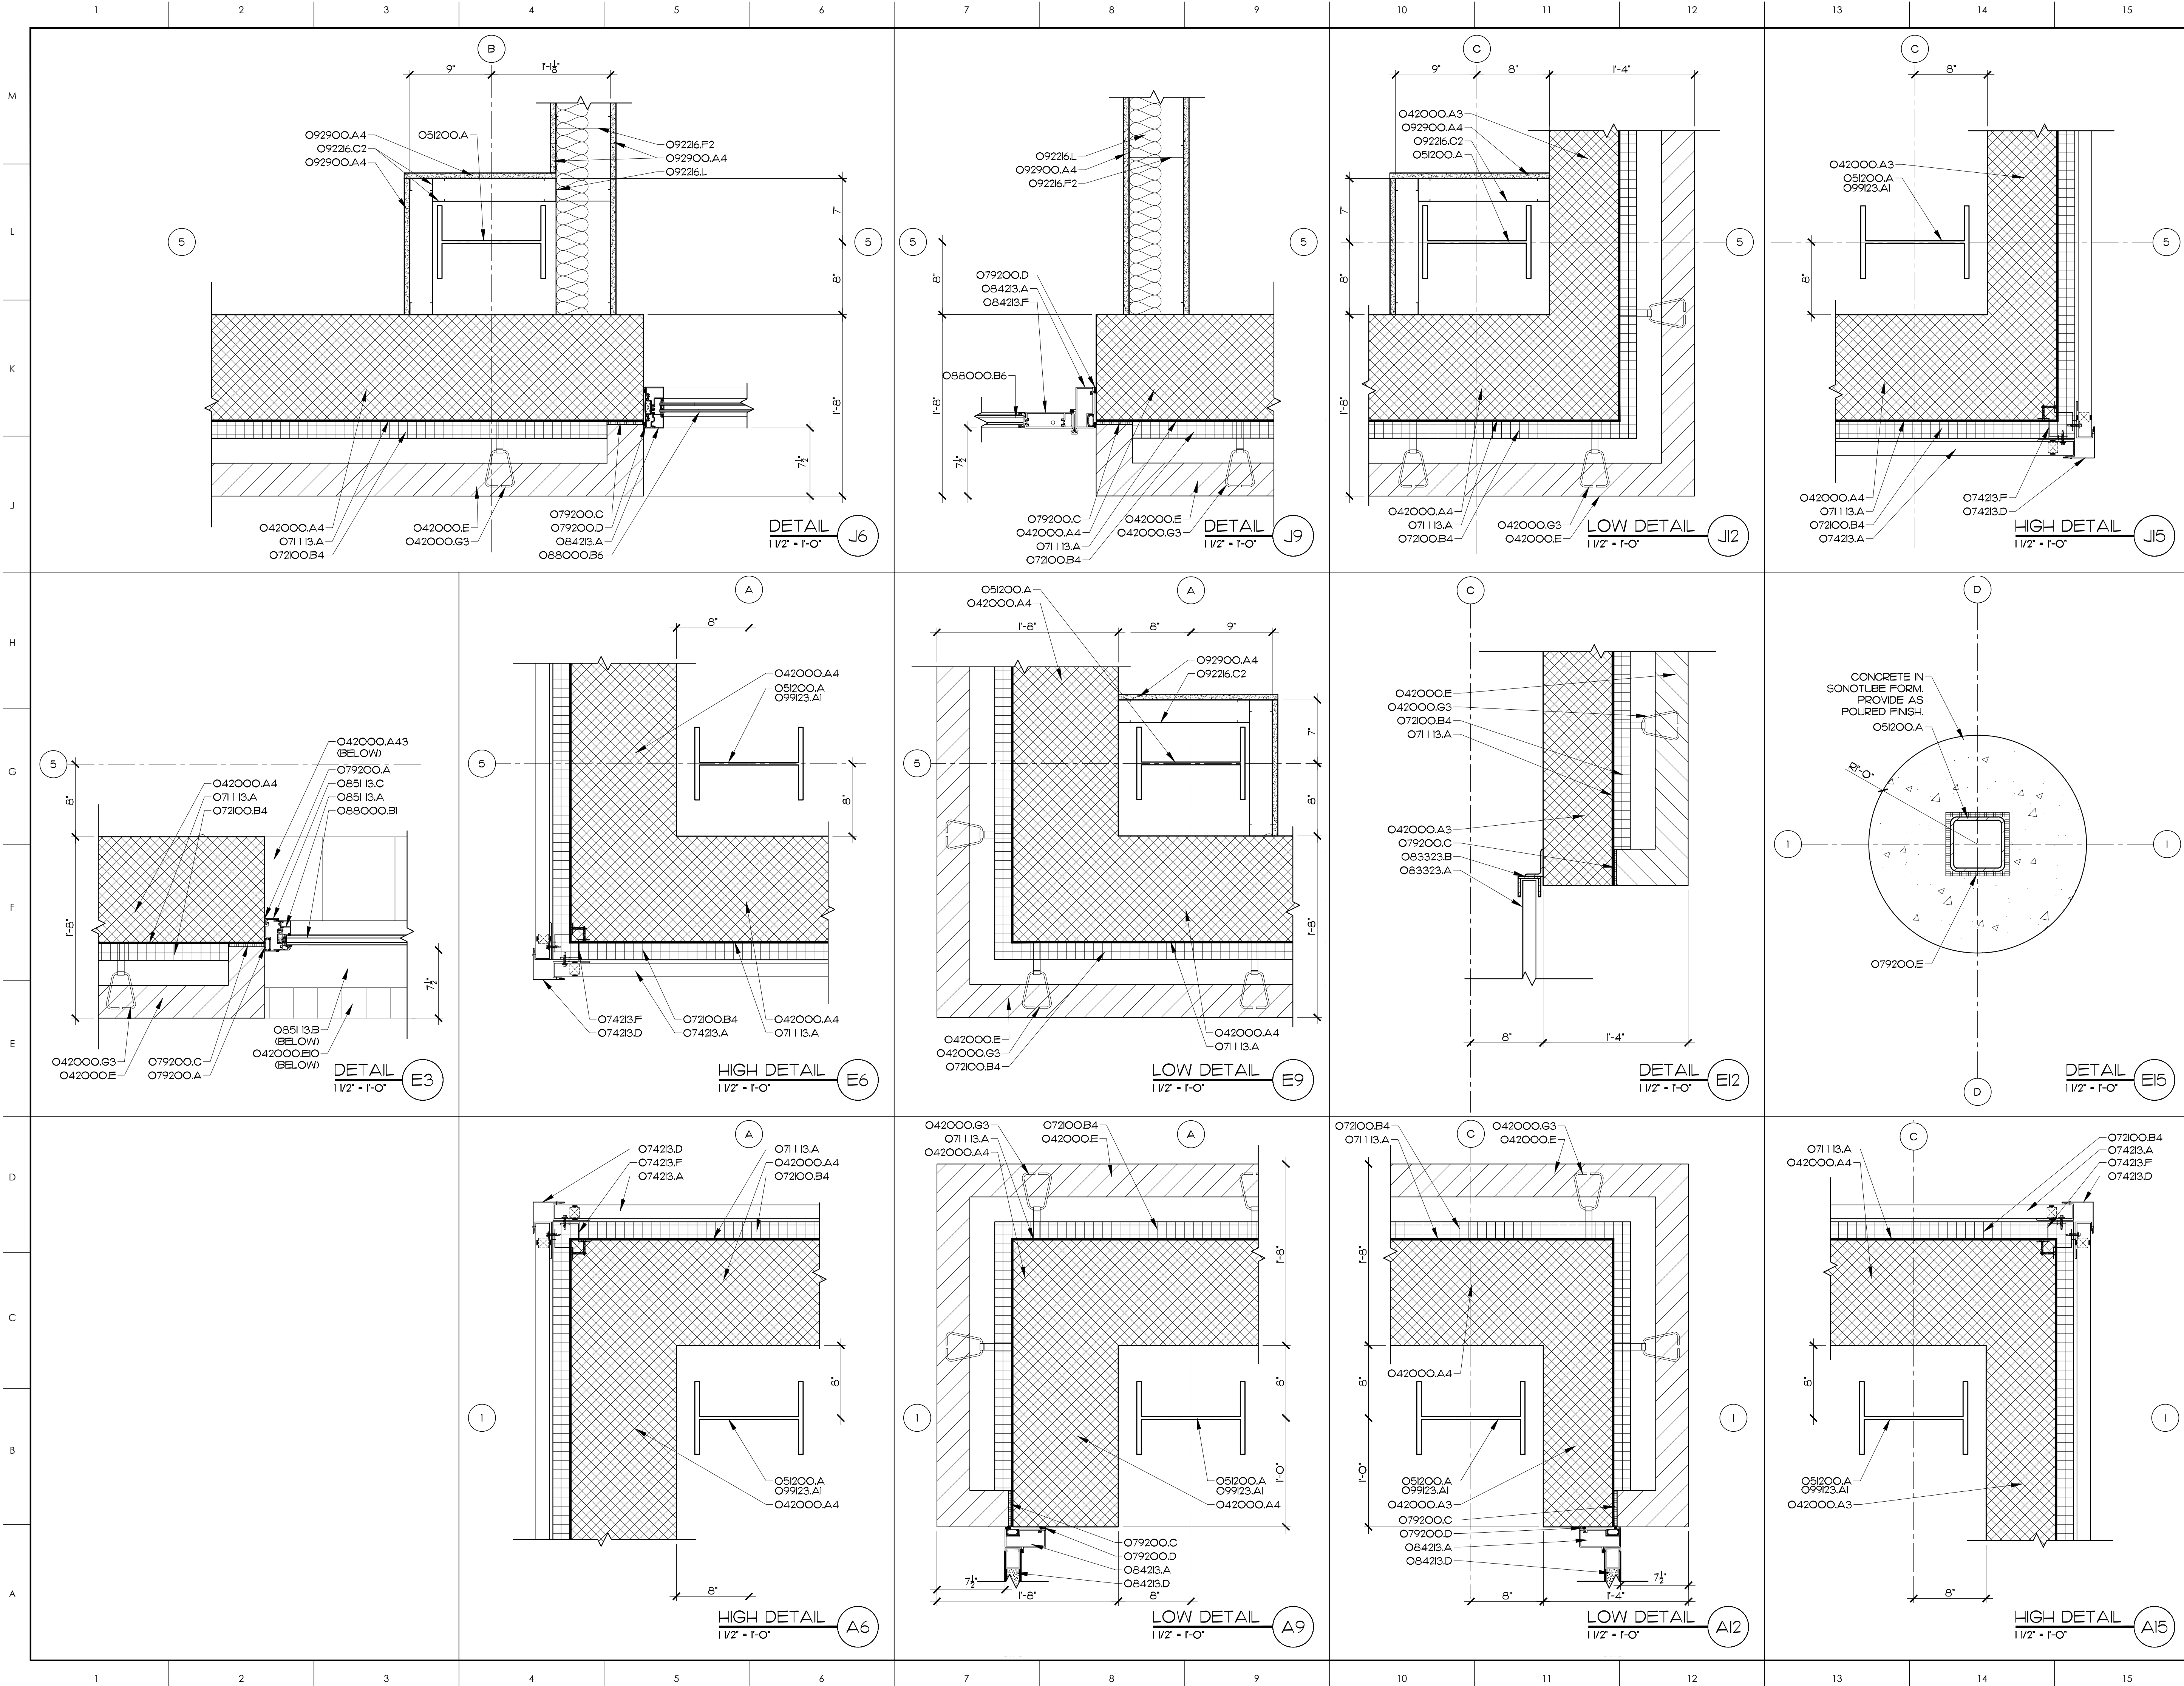

GENERAL NOTES

KEY PLAN

SCO ID #23-27044-01A

NO REVISION DATE

SEAL



JKF
ARCHITECTURE

425 LYNNDALE CT., SUITE F, GREENVILLE, NC 27658 252-355-1068

BEAUFORT COUNTY
COMMUNITY COLLEGE
INDUSTRIAL TRAINING CENTER
AURORA, NC

DRAWING TITLE

EXTERIOR DETAILS

SCALE

1 1/2" = 1'-0"

DRAWN

JRH

CHECKED

JKF

DATE

1-6-2025




PROJECT NO.

2024-10




DRAWING NO

A6.1

© COPYRIGHT, JKF ARCHITECTURE PC, JOHN K. FARKAS, AIA

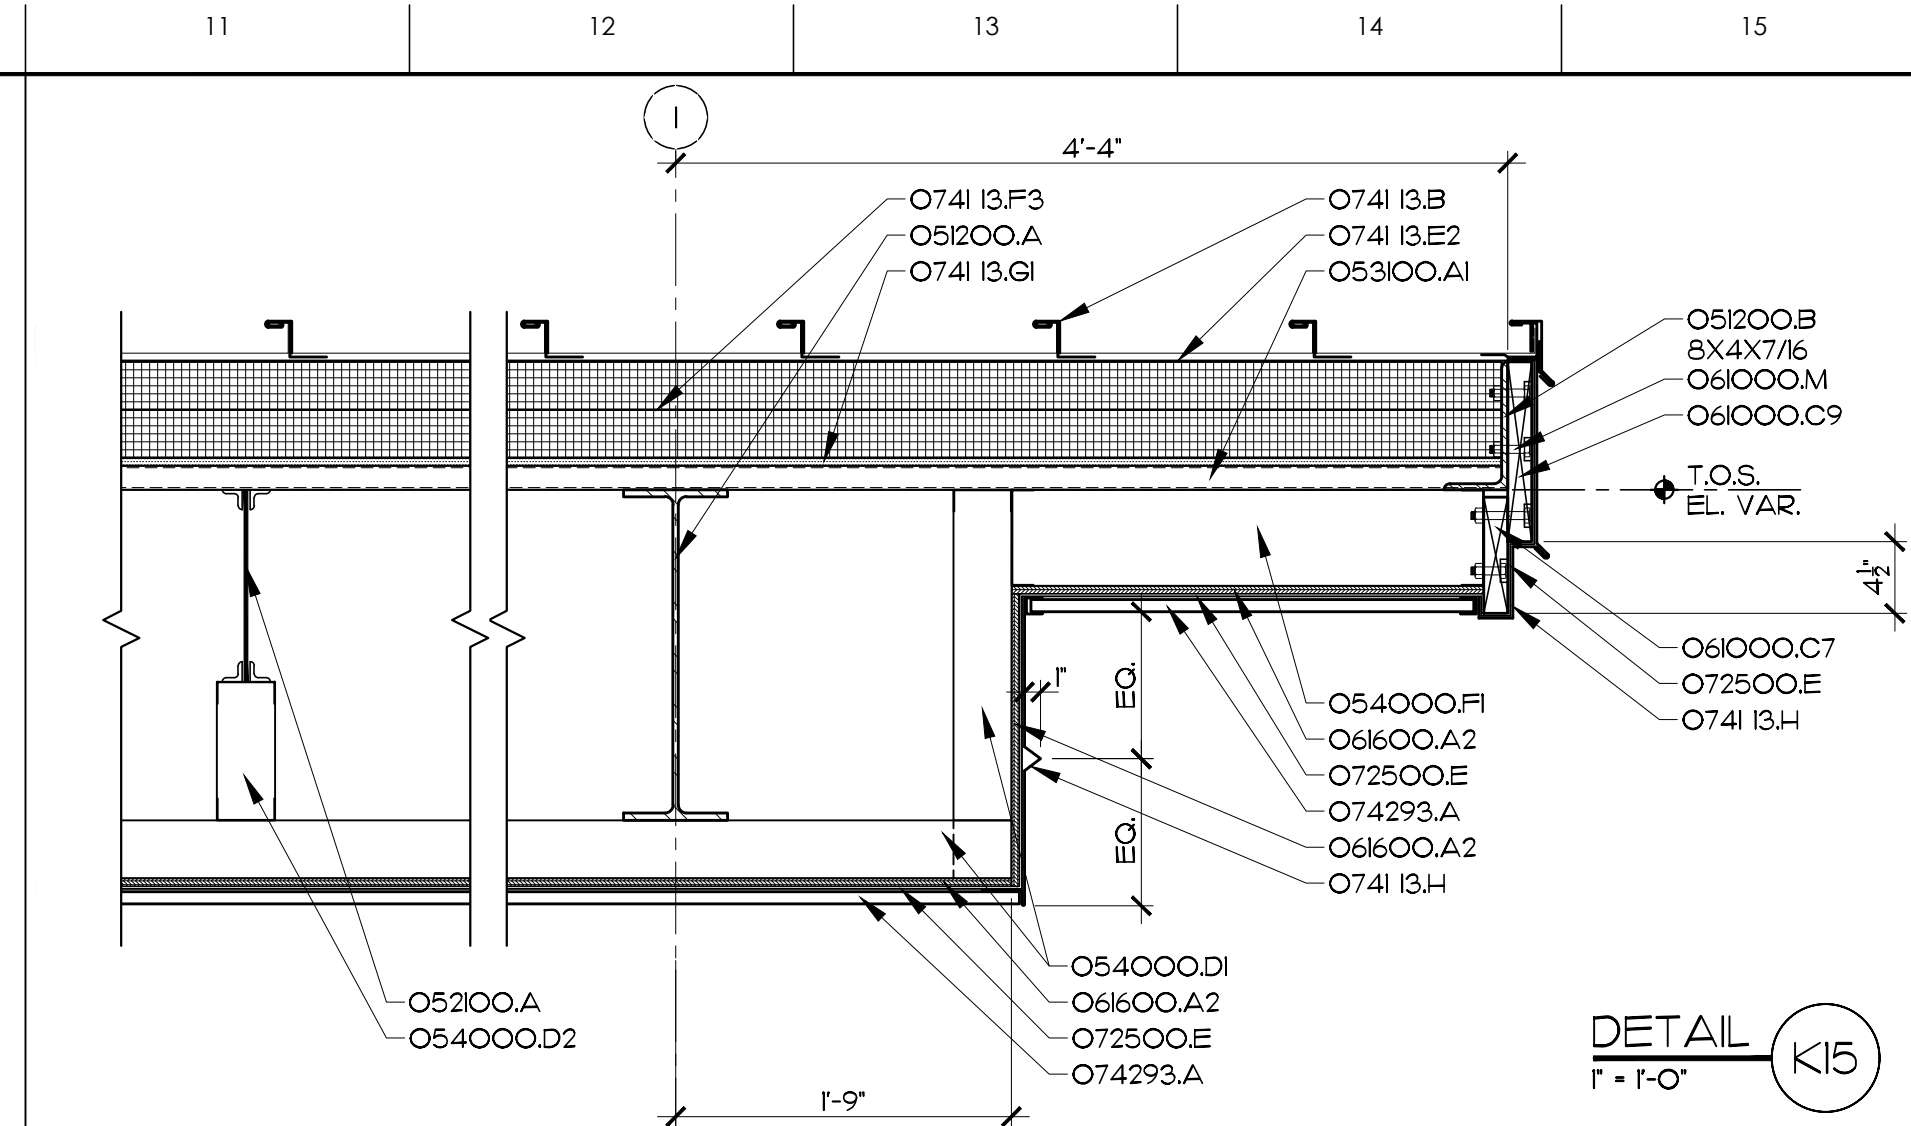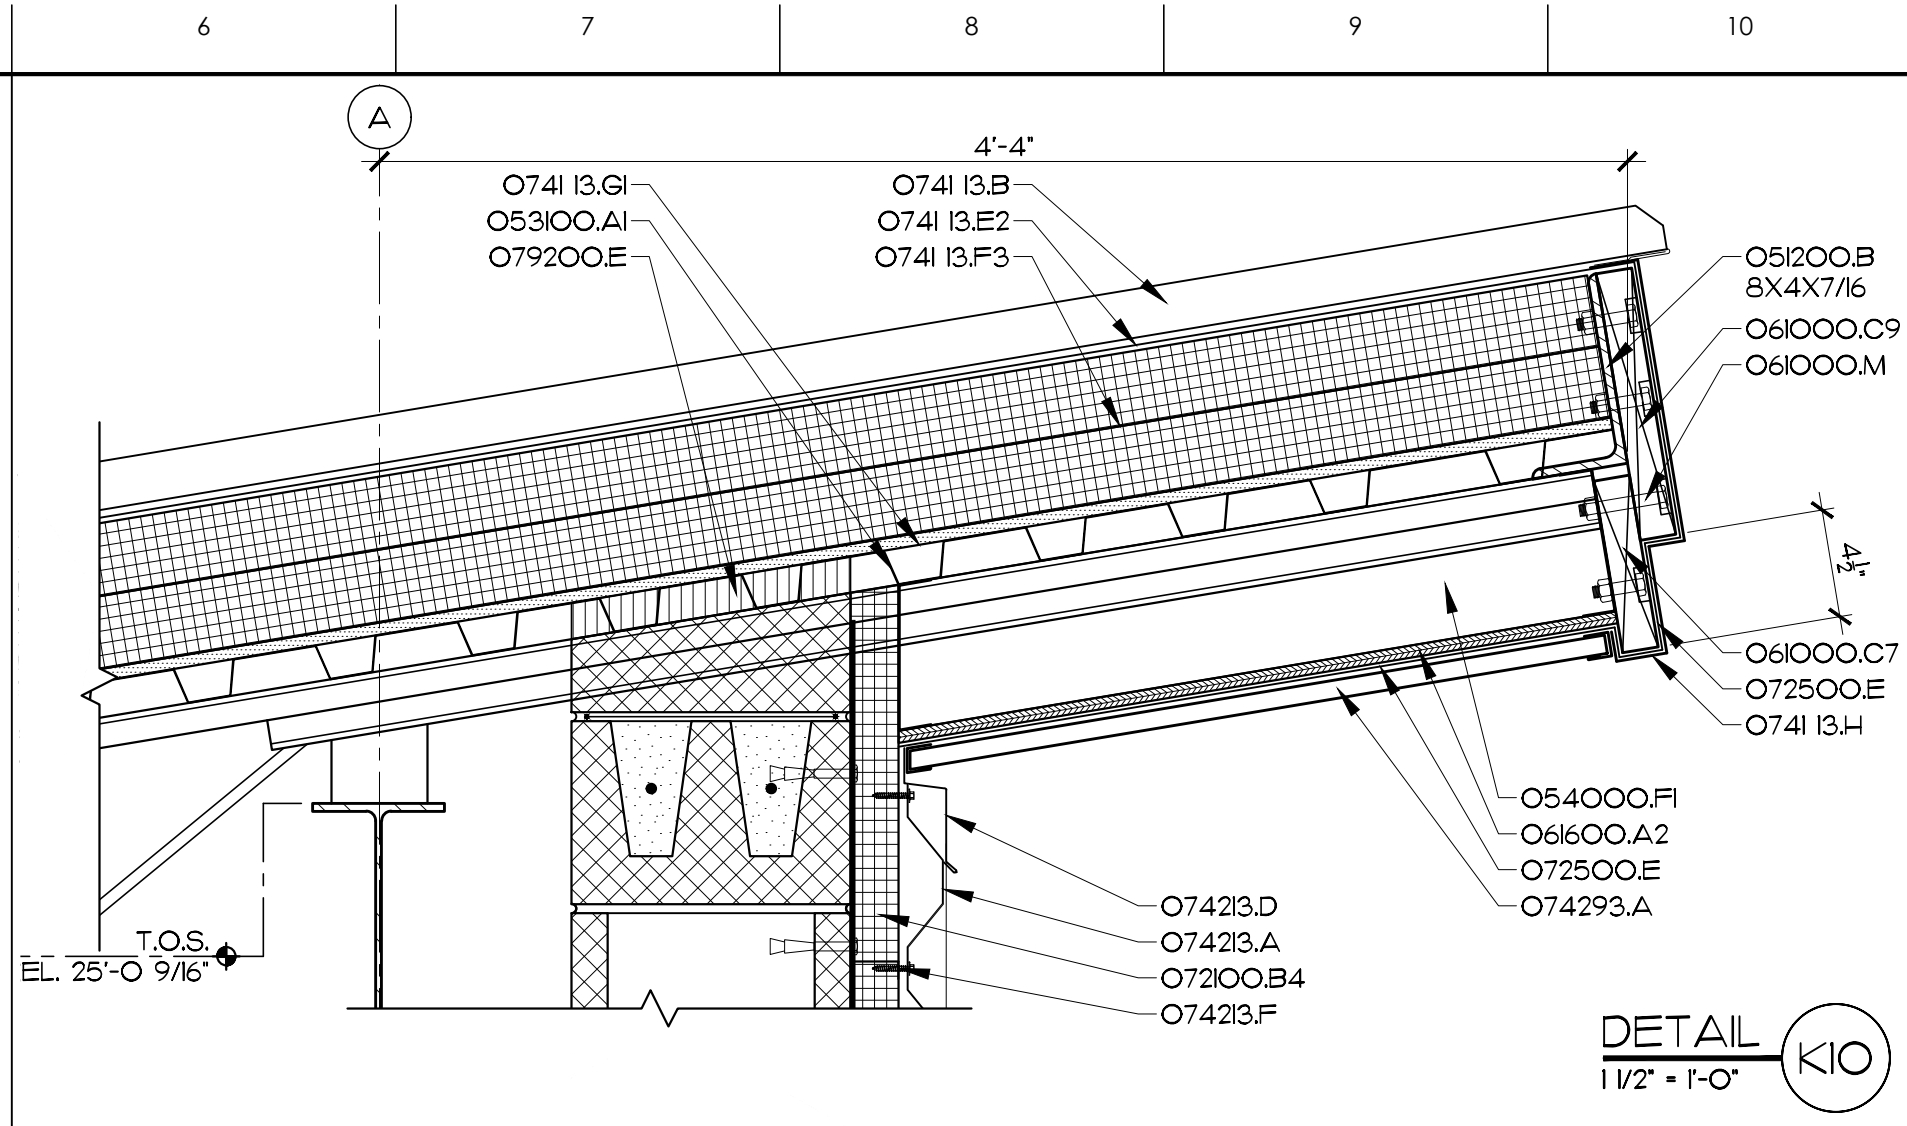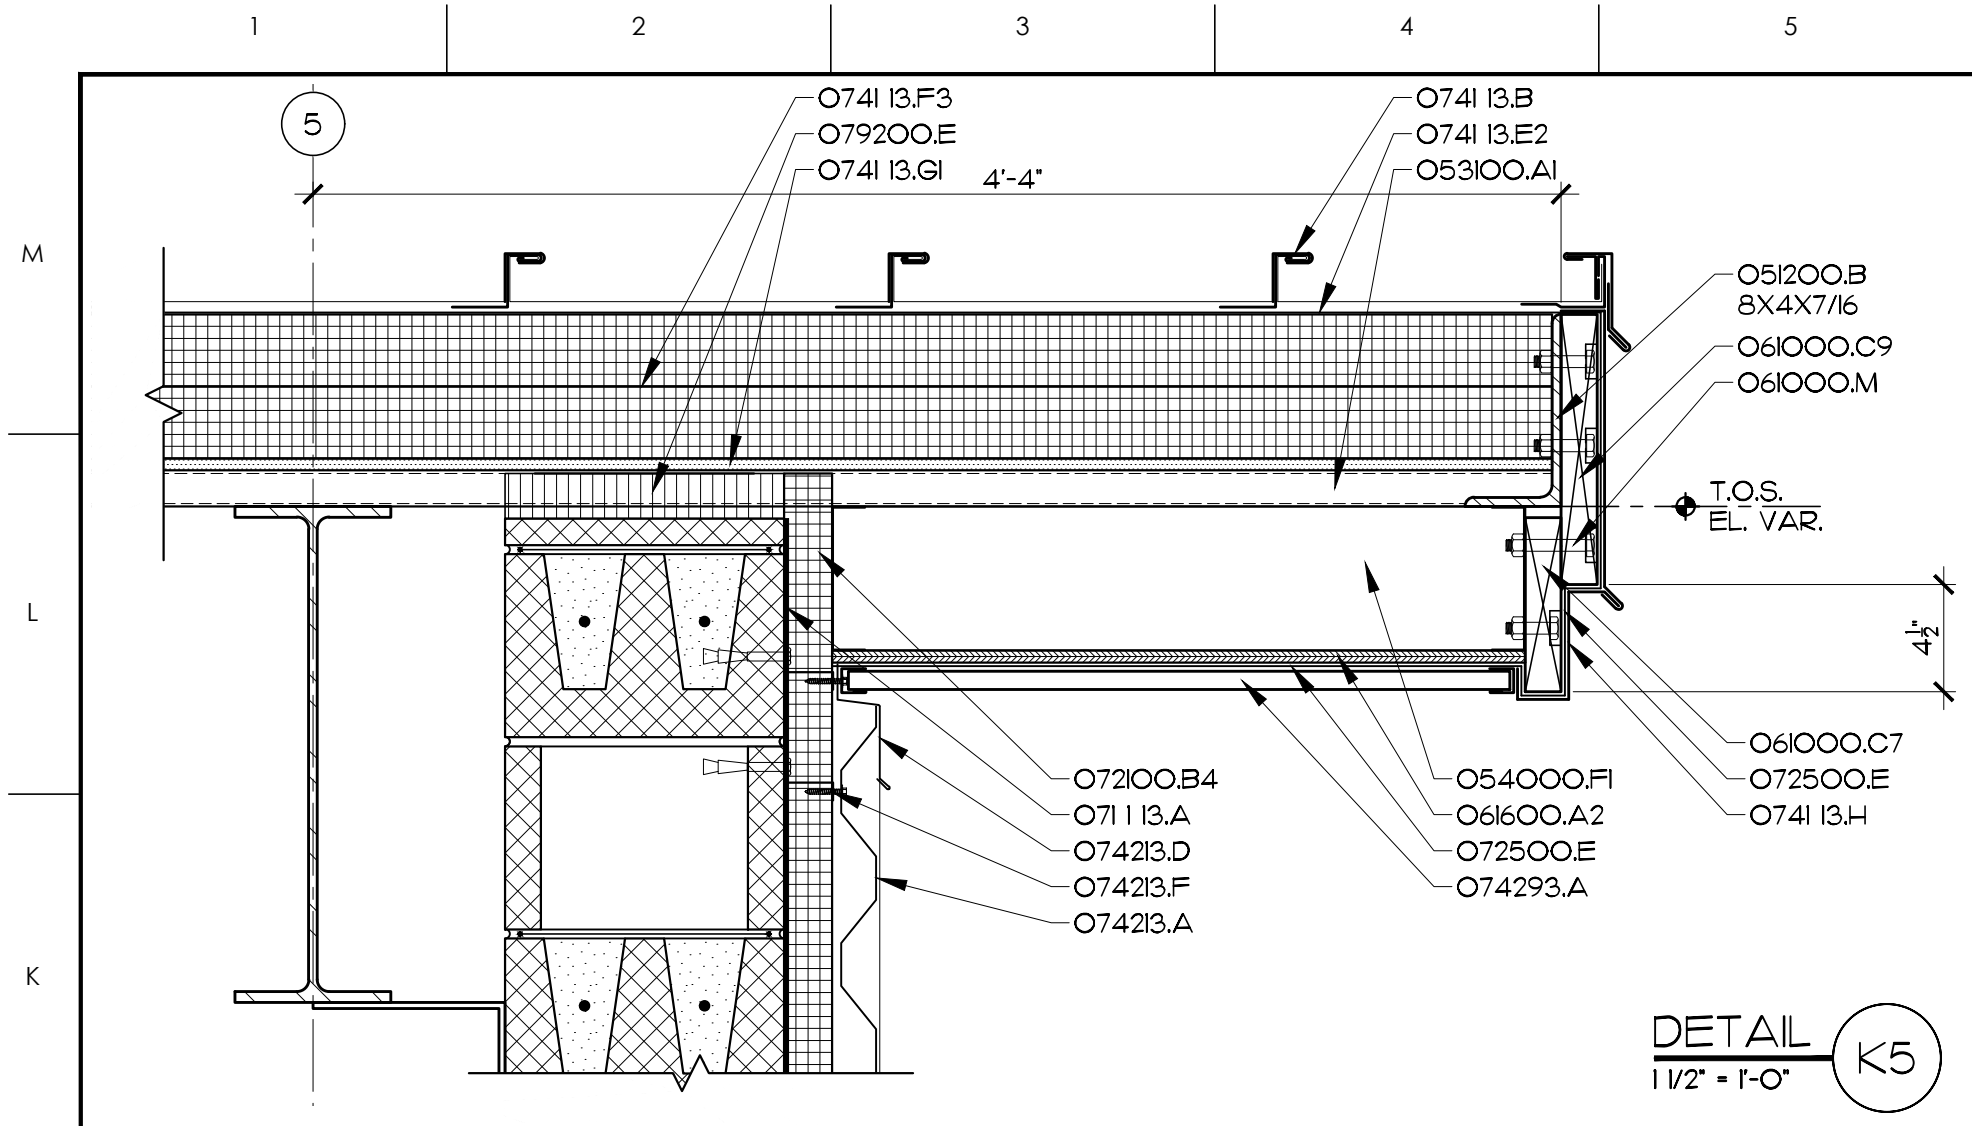

- MATERIALS KEYING LEGEND**
- 033000.C - VAPOR BARRIER
 - 033000.H - COMPRESSIBLE FILL
 - 042000.A3 - CONCRETE MASONRY UNIT, 8"
 - 042000.A4 - CONCRETE MASONRY UNIT, 12"
 - 042000.A43 - CONCRETE MASONRY UNIT, 12" SOLID BEVELED
 - 042000.B - CONCRETE MASONRY, BOND BEAM
 - 042000.E - FACE BRICK
 - 042000.E6 - FACE BRICK, SOLDER COURSE
 - 042000.E10 - FACE BRICK, SOLDER COURSE SILL, SPECIAL SHAPE
 - 042000.G1 - HORIZONTAL JOINT REINFORCING
 - 042000.G3 - HORIZONTAL JOINT REINFORCING, AT 16" VERT. & BRICK TIE EYES AT 24" O.C. HORIZ.
 - 042000.J1 - METAL DRIP FLASHING
 - 042000.J2 - WEEP SLOTS AT 16" O.C.
 - 042000.L - CAVITY DRAINAGE MATERIAL
 - 042000.N - GROUT SOLID
 - 051200.A - STRUCTURAL STEEL, SEE STRUCTURAL DRAWINGS
 - 051200.B - STEEL ANGLE, SIZE AS INDICATED
 - 05200.A - STEEL BAR JOIST, SEE STRUCTURAL DRAWINGS
 - 053000.A1 - ROOF DECK, 1/2"
 - 054000.D1 - COLD FORMED METAL FRAMING, 3-5/8" STUD AT 16" O.C.
 - 054000.D2 - COLD FORMED METAL FRAMING, 3-5/8" STUD AT 24" O.C.
 - 054000.F1 - COLD FORMED METAL FRAMING, 6" STUD AT 16" O.C.
 - 061000.C7 - TREATED 2X8
 - 061000.C9 - TREATED 2X12
 - 061000.J2 - WOOD BLOCKING, PRESSURE TREATED
 - 061000.M - 1/2" DIA. BOL. T. COUNTERSUNK AT 16" O.C. STAGGERED
 - 061000.O2 - FLYWOOD SHEATHING, 1/2" THICK
 - 071113.A - BITUMINOUS DAMPROOFING
 - 072000.B2 - 1" RIGID INSULATION
 - 072000.B4 - 2" RIGID INSULATION
 - 072500.E - BUILDING WRAP
 - 074113.B - METAL ROOF, STANDING SEAM PANEL
 - 074113.E2 - SELF ADHERING SHEET
 - 074113.F3 - RIGID INSULATION, 6" THICK
 - 074113.G1 - GLASS-MAT GYP. SHEATHING, 1/2" THICK
 - 074113.H - METAL FASCIA
 - 074113.J - METAL GUTTER
 - 074213.A - METAL WALL PANEL
 - 074213.C - METAL SILL FLASHING
 - 074213.D - METAL CLOSURE TRIM
 - 074213.F - 2" METAL Z-FLURRING CHANNEL, 16" O.C.
 - 074213.A1 - METAL SOFFIT PANELS
 - 077253.A - SNOW GUARD
 - 079200.A - SEALANT
 - 079200.E - COMPRESSIBLE FILL
 - 084213.A - STOREFRONT FRAMING, THERMALLY BROKEN
 - 084213.F - ALUMINUM STILE & RAIL DOOR
 - 085113.A1 - ALUMINUM WINDOW ASSEMBLY, FIXED WINDOW
 - 085113.B - METAL SILL PAN
 - 085113.C - METAL SUB FRAME
 - 087000.A - THERMAL BREAK THRESHOLD
 - 088000.B1 - 1" INSULATING GLASS-LOW E
 - 088000.B6 - 1" INSULATING GLASS, TEMPERED LOW E
 - 095113.D1 - ACOUSTICAL PANEL CEILING TILE, 2X2
 - 096513.A5 - 4" RESILIENT TOP SET BASE
 - 095300.A2 - ALUMINUM CANOPY ASSEMBLY WITH SUPPORT POSTS
 - 321313.D - COMPRESSIBLE FILL

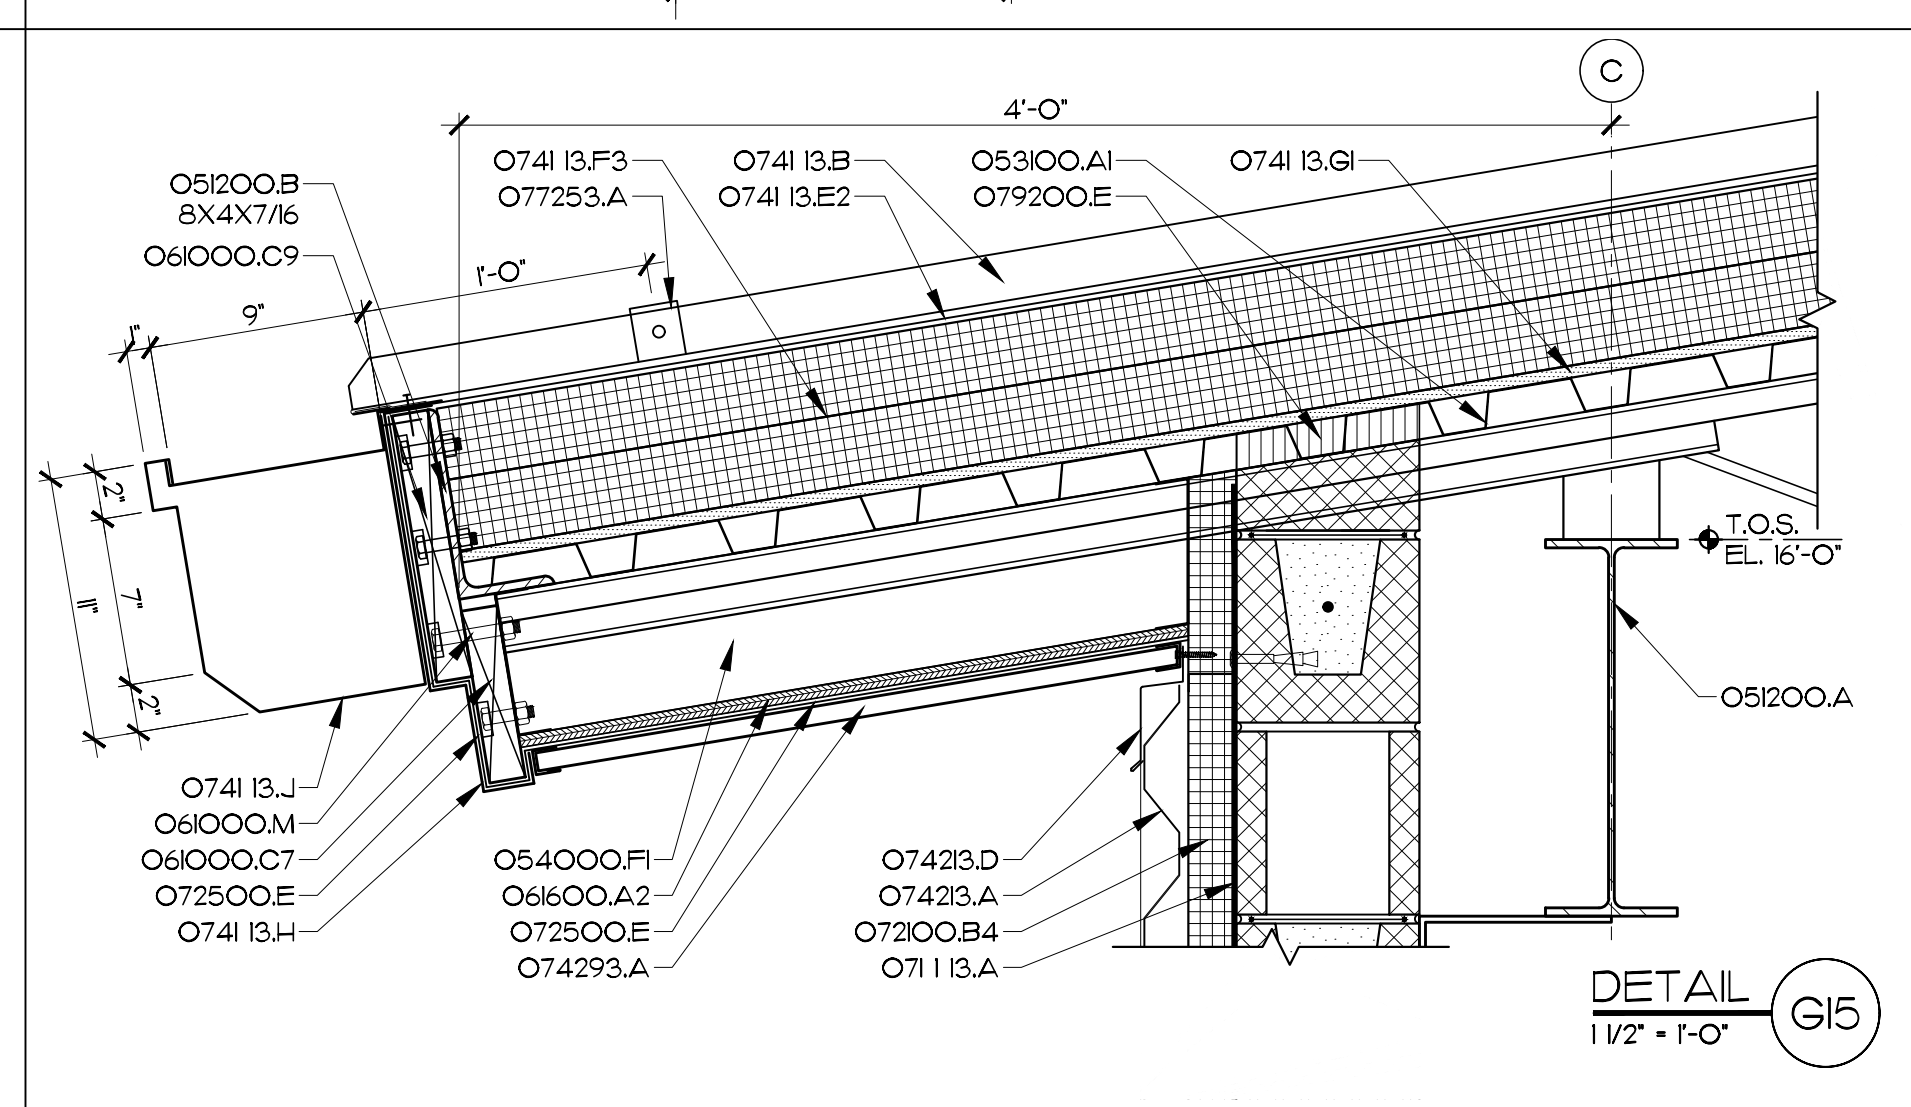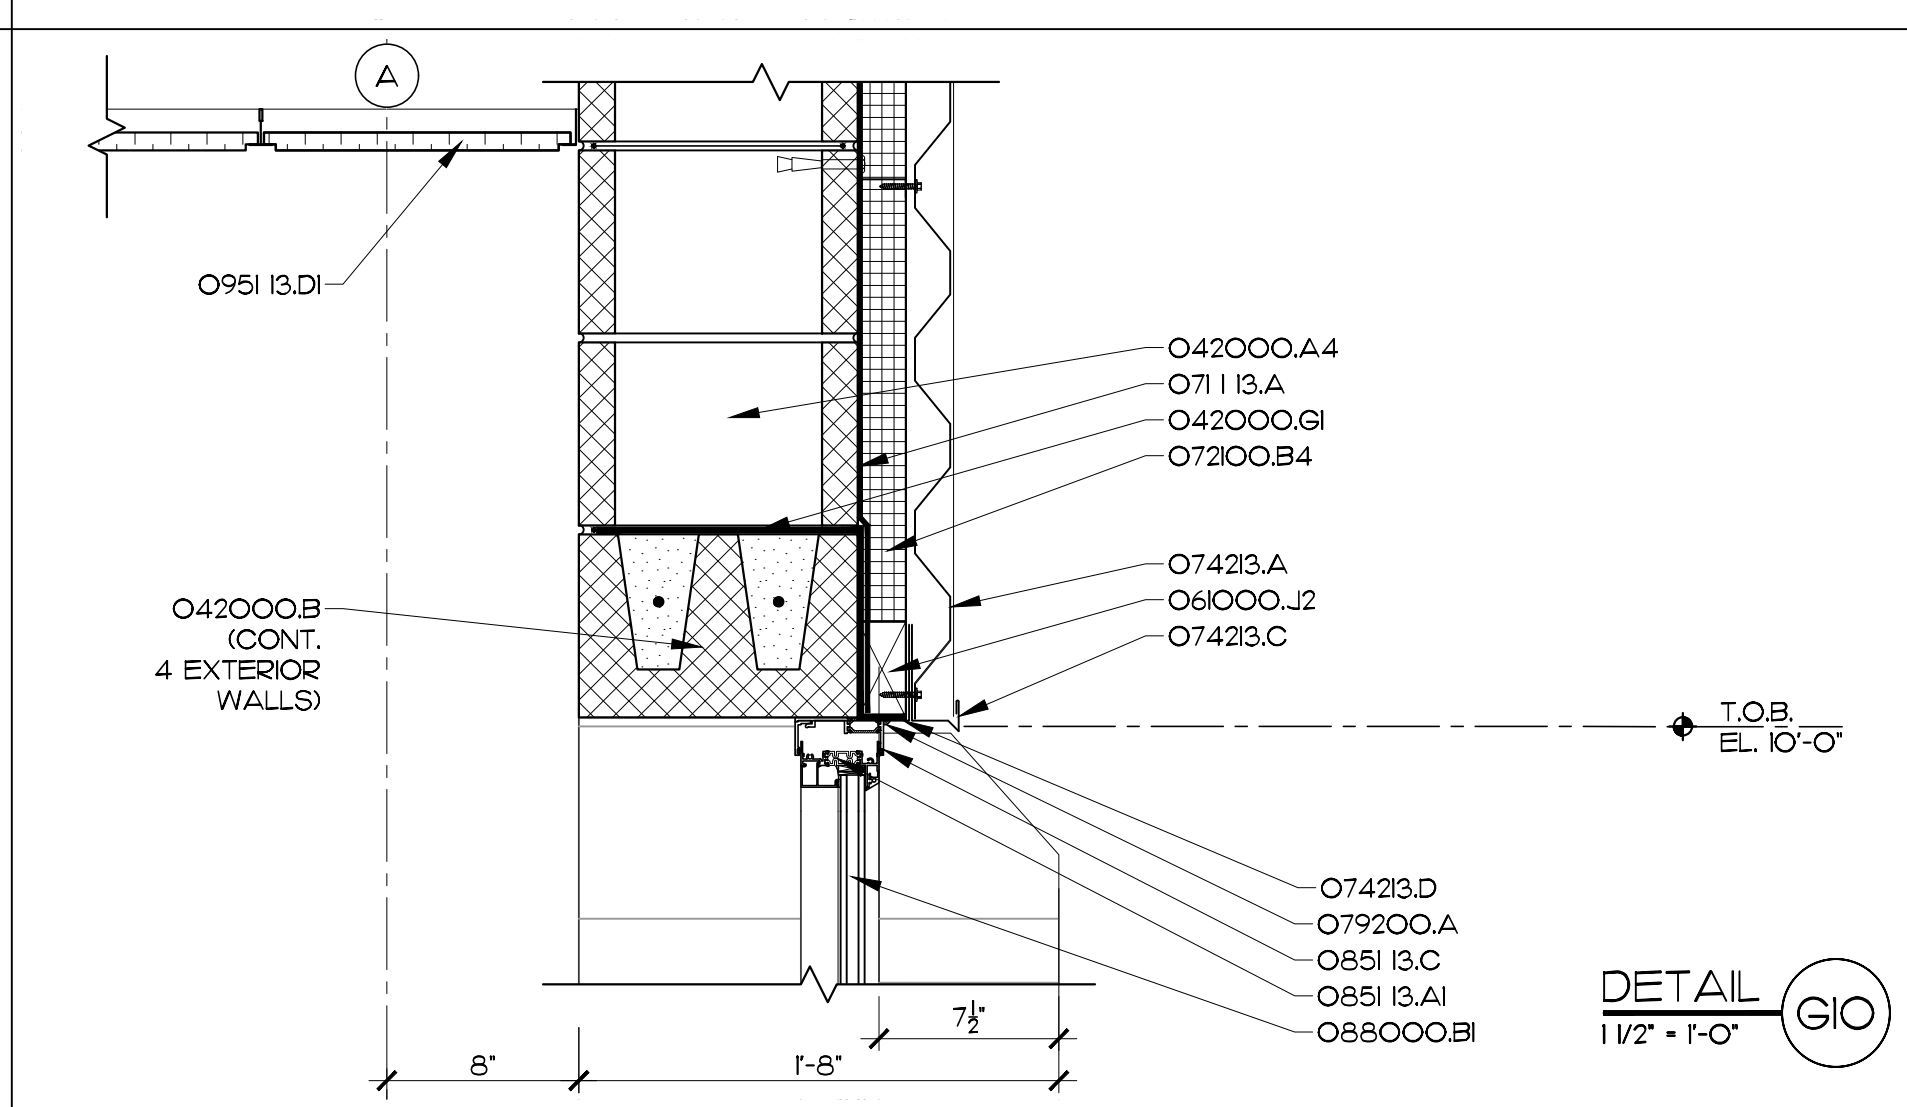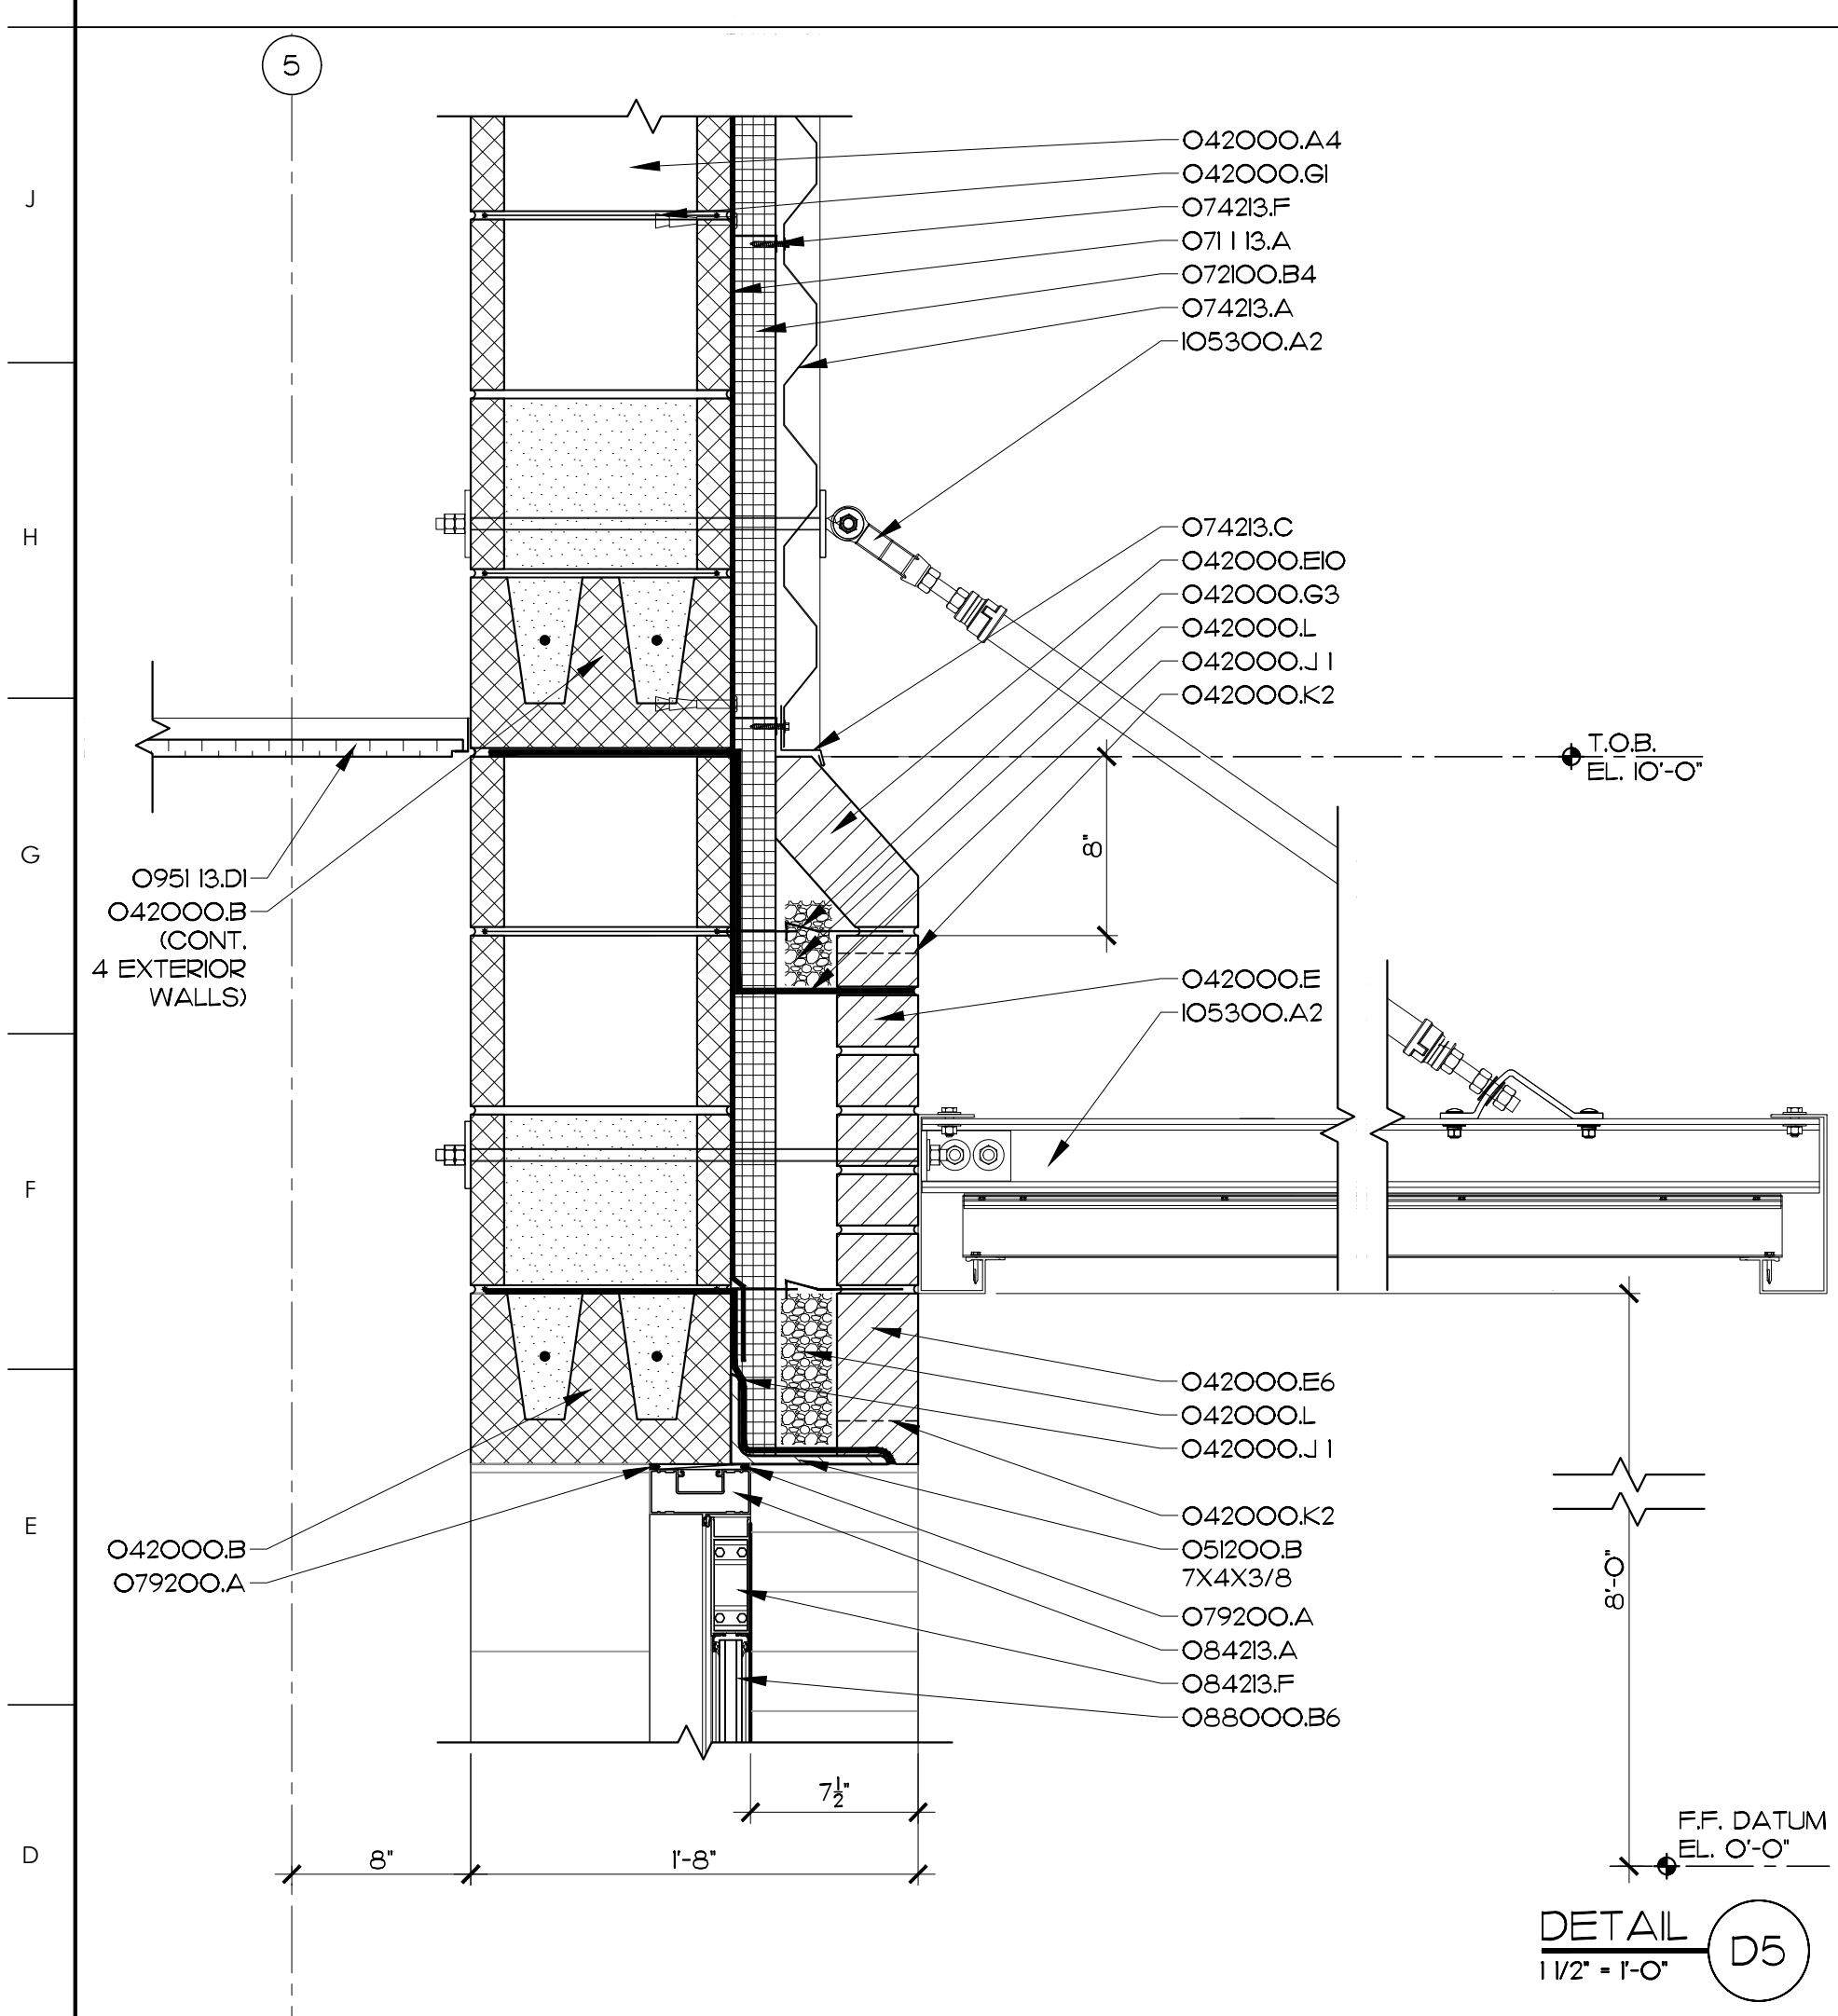

GENERAL NOTES

SCO ID #23-27044-01A

NO REVISION DATE



JKF
ARCHITECTURE

625 LYNNDALE CT., SUITE F, GREENVILLE, NC 27658 252-355-1068

BEAUFORT COUNTY
COMMUNITY COLLEGE
INDUSTRIAL TRAINING CENTER
AURORA, NC

DRAWING TITLE

EXTERIOR DETAILS

SCALE
AS NOTED

DRAWN
JRH


CHECKED
JKF

DATE
1-6-2025

PROJECT NO.
2024-10

DRAWING NO.
A6.2

© COPYRIGHT, JKF ARCHITECTURE PC, JOHN K. FARKAS, AIA

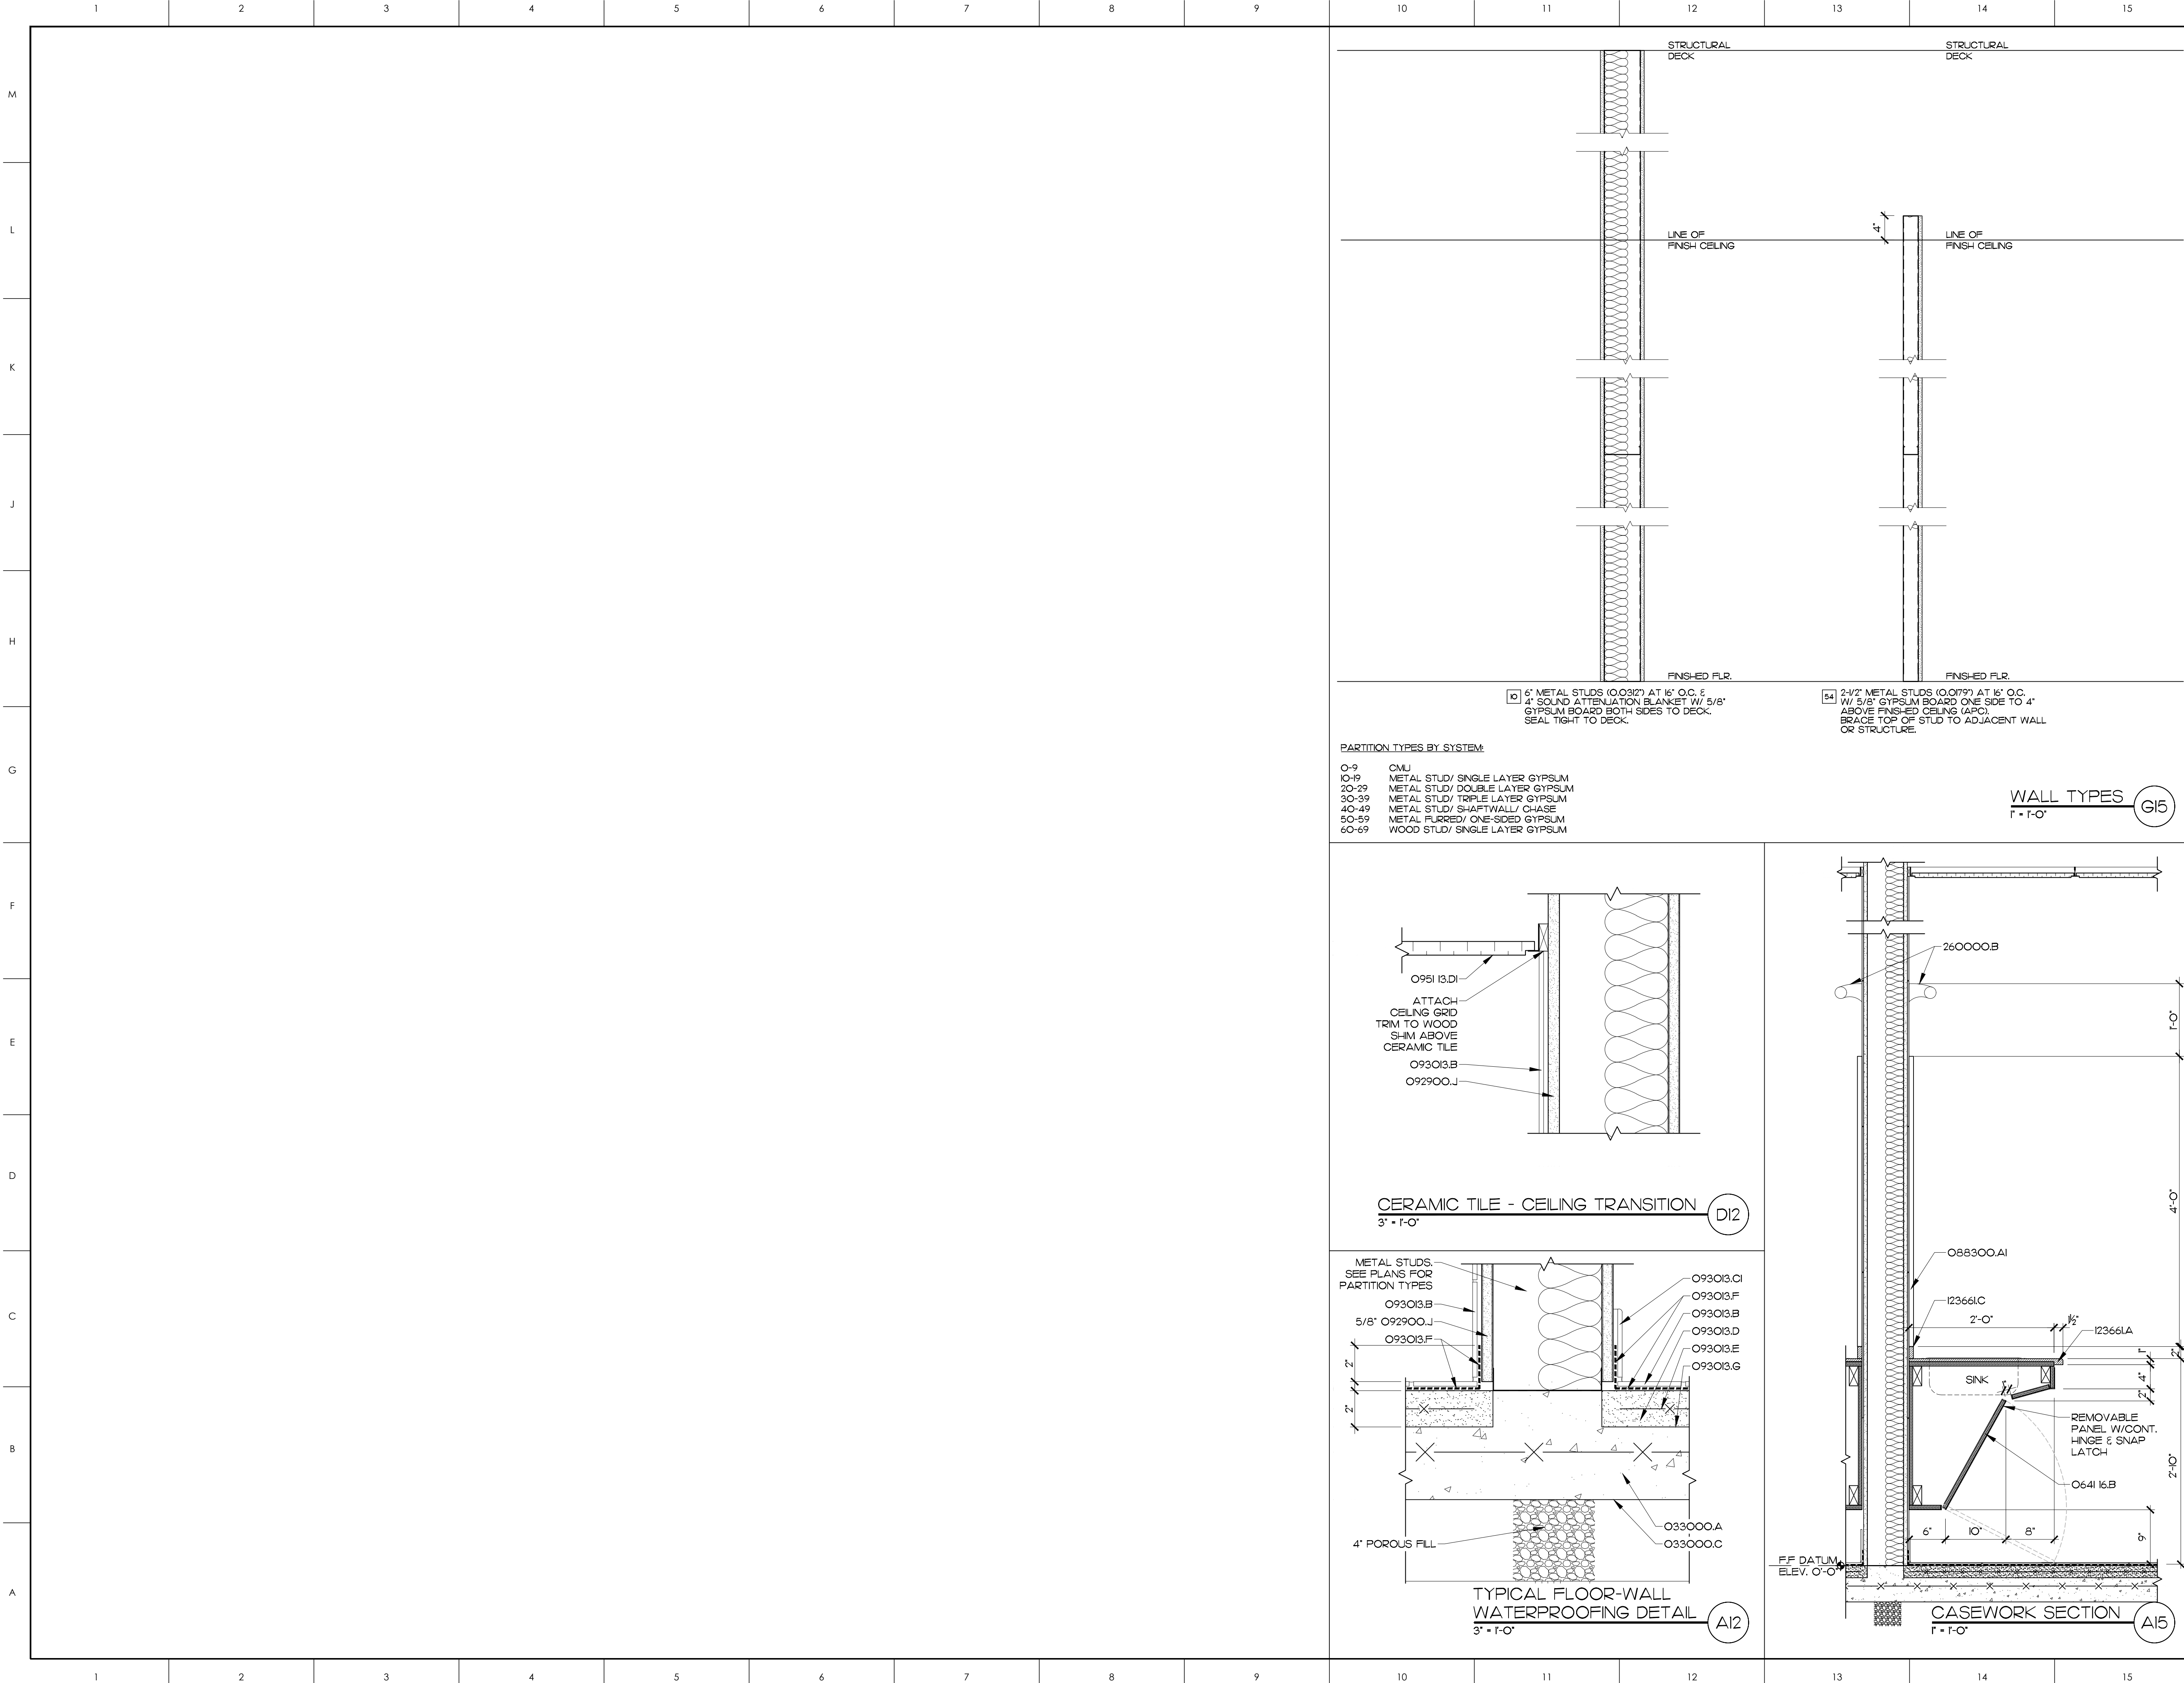

- MATERIALS KEYING LEGEND
- 033000.A - CONCRETE SLAB ON GRADE, SEE STRUCTURAL
 - 033000.C - VAPOR BARRIER
 - 064116.B - PLASTIC LAMINATE, 3/4" THICK
 - 088300.AI - 1/4" GLASS MIRROR
 - 092900.J - CEMENTITIOUS BACKER UNIT
 - 093013.B - CERAMIC TILE
 - 093013.CI - CERAMIC TILE, SPECIAL SHAPE, COVE BASE, 4" HIGH
 - 093013.D - MORTAR BED
 - 093013.E - REINFORCING MESH
 - 093013.F - WATERPROOFING MEMBRANE
 - 093013.G - CLEAVAGE MEMBRANE
 - 095113.DI - ACOUSTICAL PANEL CEILING TILE, 2X2
 - 123661A - SIMULATED STONE COUNTERTOP
 - 123661C - SIMULATED STONE BACKSPLASH
 - 260000.B - INTERIOR LIGHT FIXTURE

- GENERAL NOTES
1. PROVIDE MOISTURE-RESISTANT GYPSUM BOARD IN ALL TOILET ROOMS, JANITORS CLOSETS, MECHANICAL ROOMS & WET AREAS IN LIEU OF GYPSUM BOARD INDICATED IN PARTITION TYPES.
 2. PROVIDE CEMENTITIOUS TILE BACKING PANEL IN LIEU OF GYPSUM BOARD WHERE CERAMIC WALL TILE IS SCHEDULED.

KEY PLAN

SCO ID #23-27044-01A

NO REVISION DATE



625 LYNNDALE CT., SUITE F, GREENVILLE, NC 27838 252-355-1068

BEAUFORT COUNTY
COMMUNITY COLLEGE
INDUSTRIAL TRAINING CENTER
AURORA, NC



DRAWING TITLE
WALL TYPES, SECTIONS
& DETAILS

SCALE	AS NOTED	DRAWING NO.
DRAWN	JRH	
CHECKED	JKF	
DATE	1-6-2025	
PROJECT NO.	2024-10	


© COPYRIGHT, JKF ARCHITECTURE PC, JOHN K. FARKAS, AIA

WINDOW SCHEDULE											
WINDOW GROUP NO.	WINDOW UNIT SIZE (W X H)	WINDOW TYPE	MATERIAL	FINISH	FRAME ELEVATION	UNIT THICKNESS	DETAILS			GLASS	FIRE RATING (HRS)
							J	H	S		
WI	4'-0" X 7'-4"	FIXED	AL	AN	WI	3 1/4"	E3 A61	G10 A62	A10 A62	LOW E	-
REMARKS											

WINDOW TYPES

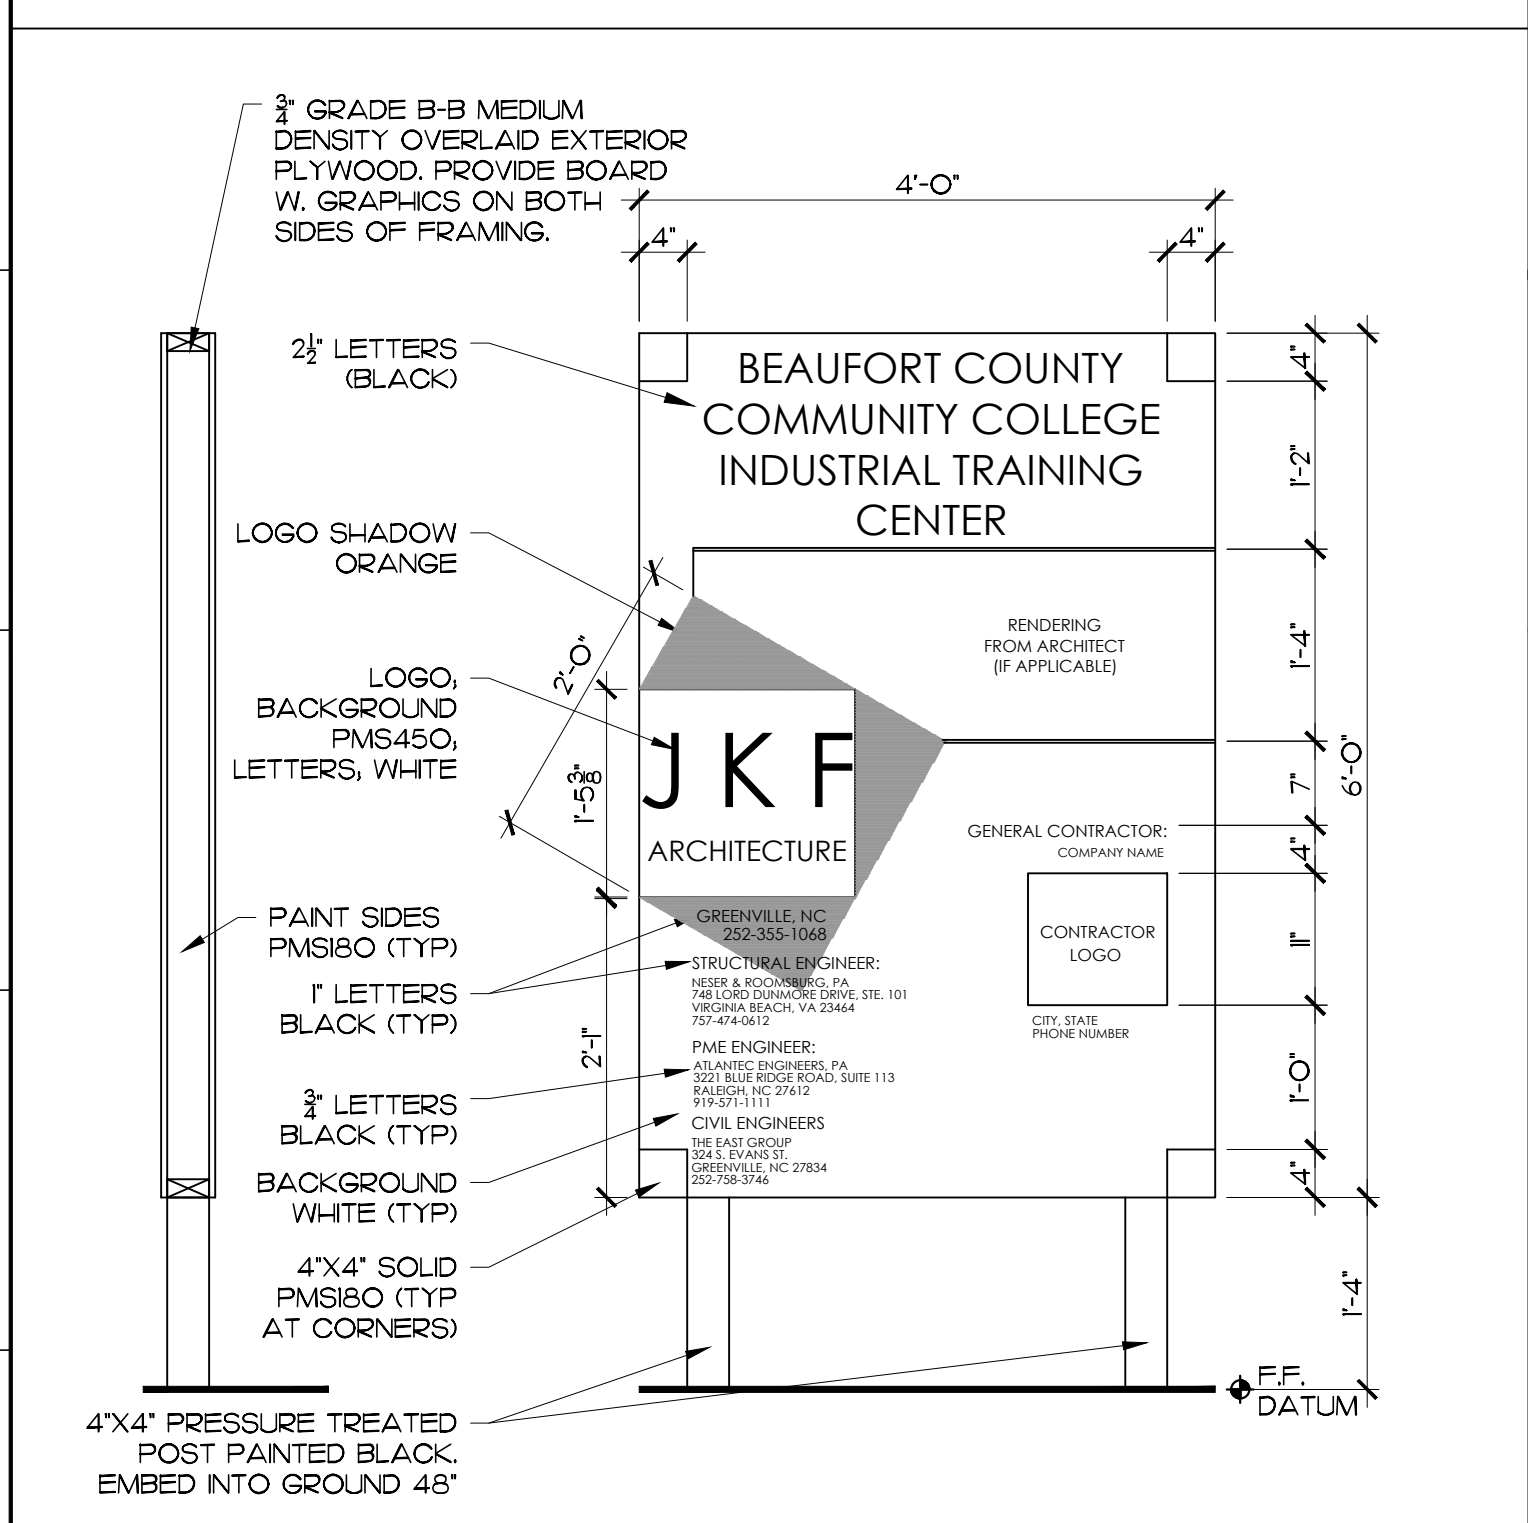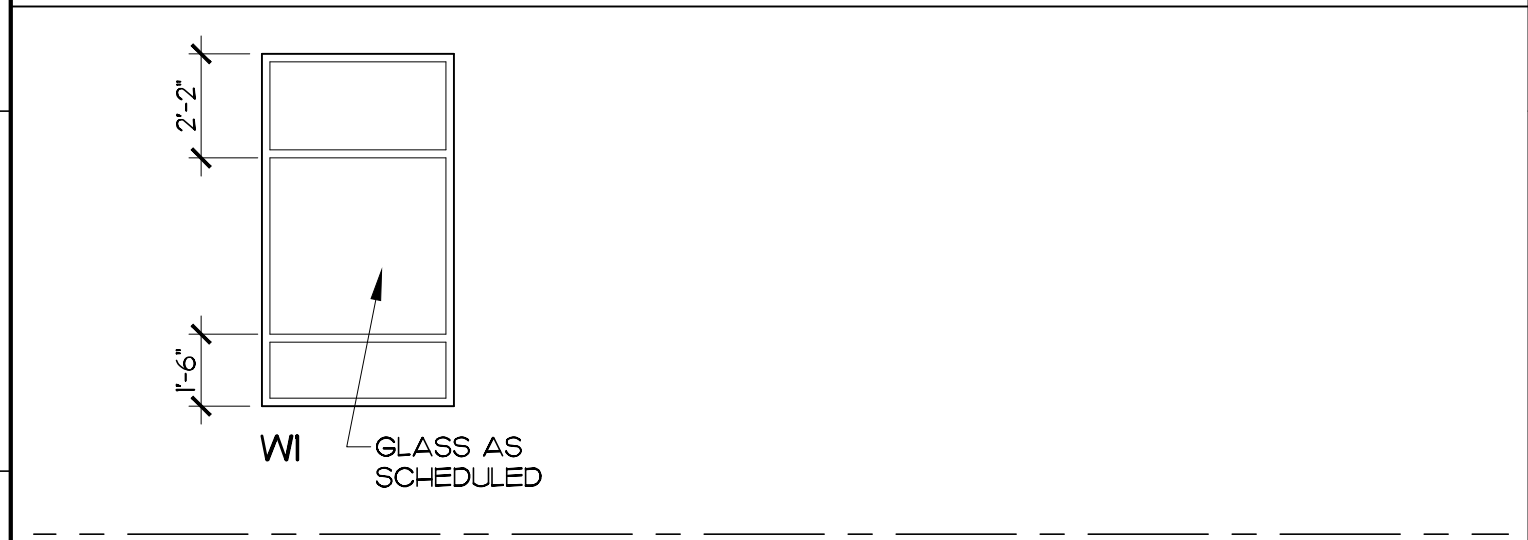




PROJECT SIGN
3/4" x 1'-0" (E4)

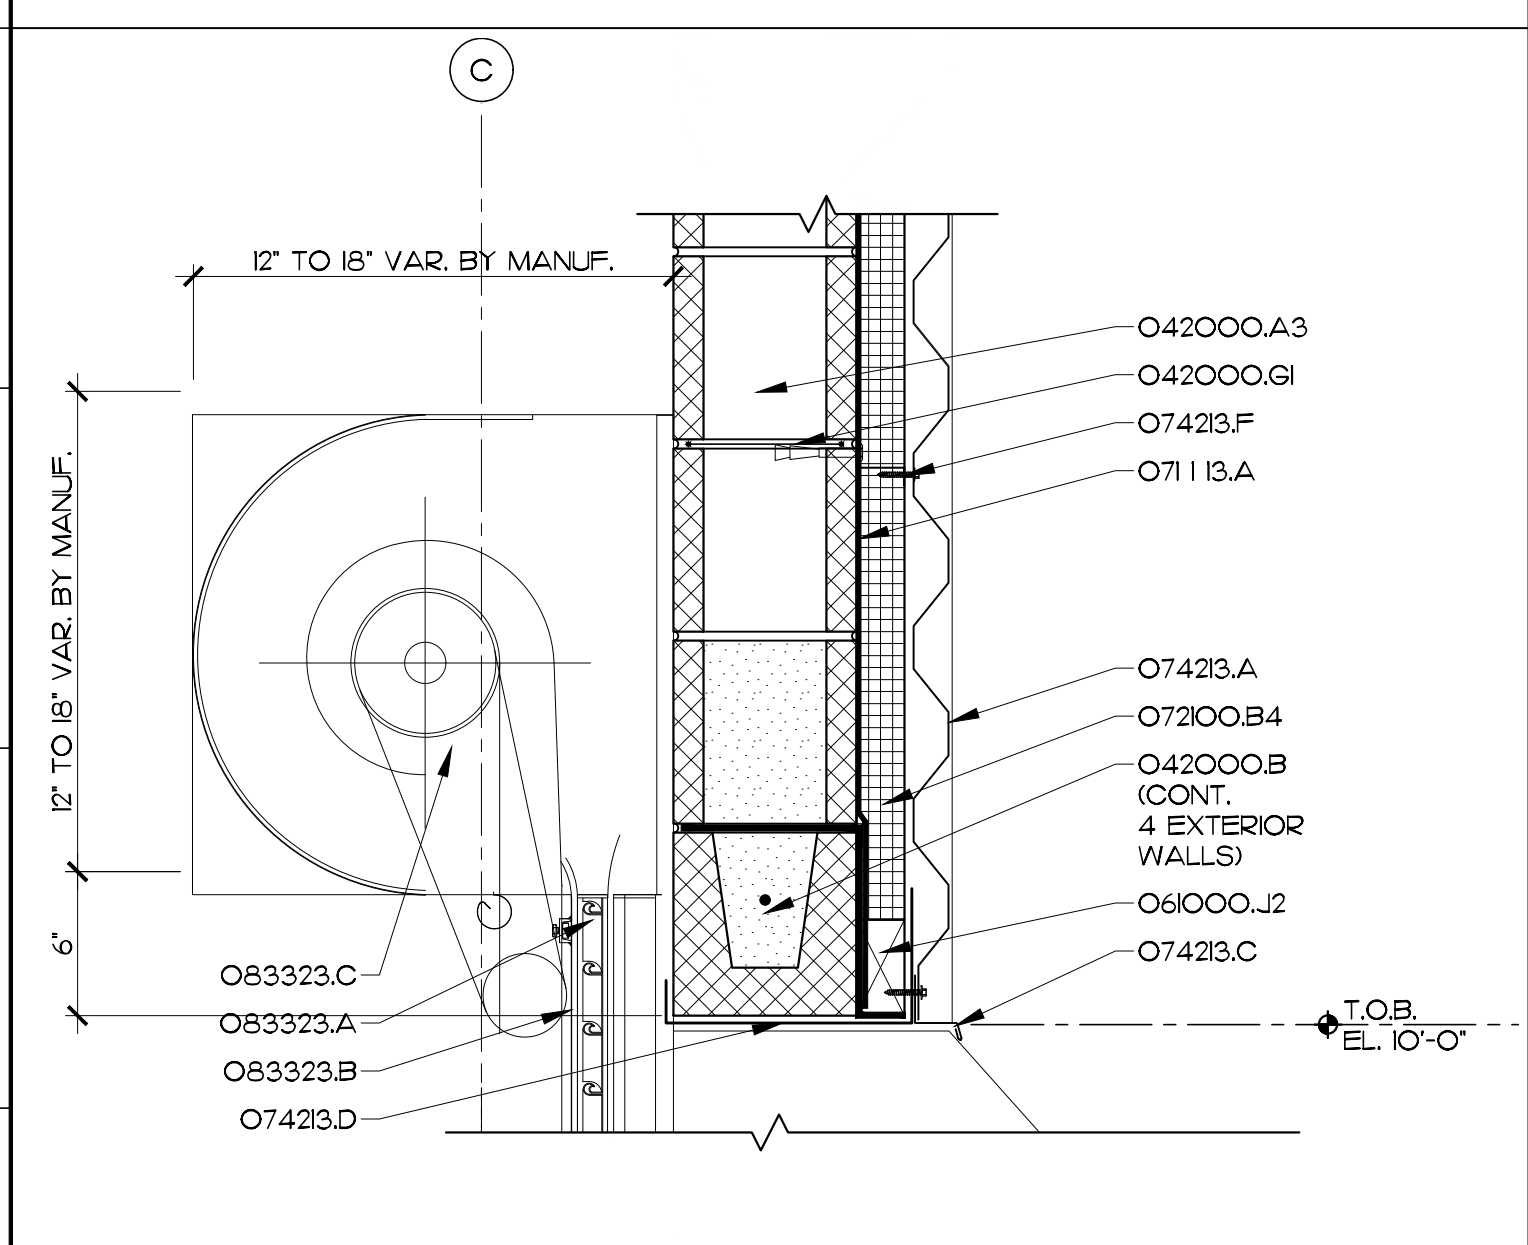


HEAD DETAIL
1 1/2" x 1'-0" (E4)

WINDOW SCHEDULE											
WINDOW GROUP NO.	WINDOW UNIT SIZE (W X H)	WINDOW TYPE	MATERIAL	FINISH	FRAME ELEVATION	UNIT THICKNESS	DETAILS			GLASS	FIRE RATING (HRS)
							J	H	S		
WI	4'-0" X 7'-4"	FIXED	AL	AN	WI	3 1/4"	E3 A61	G10 A62	A10 A62	LOW E	-
REMARKS											

WINDOW TYPES

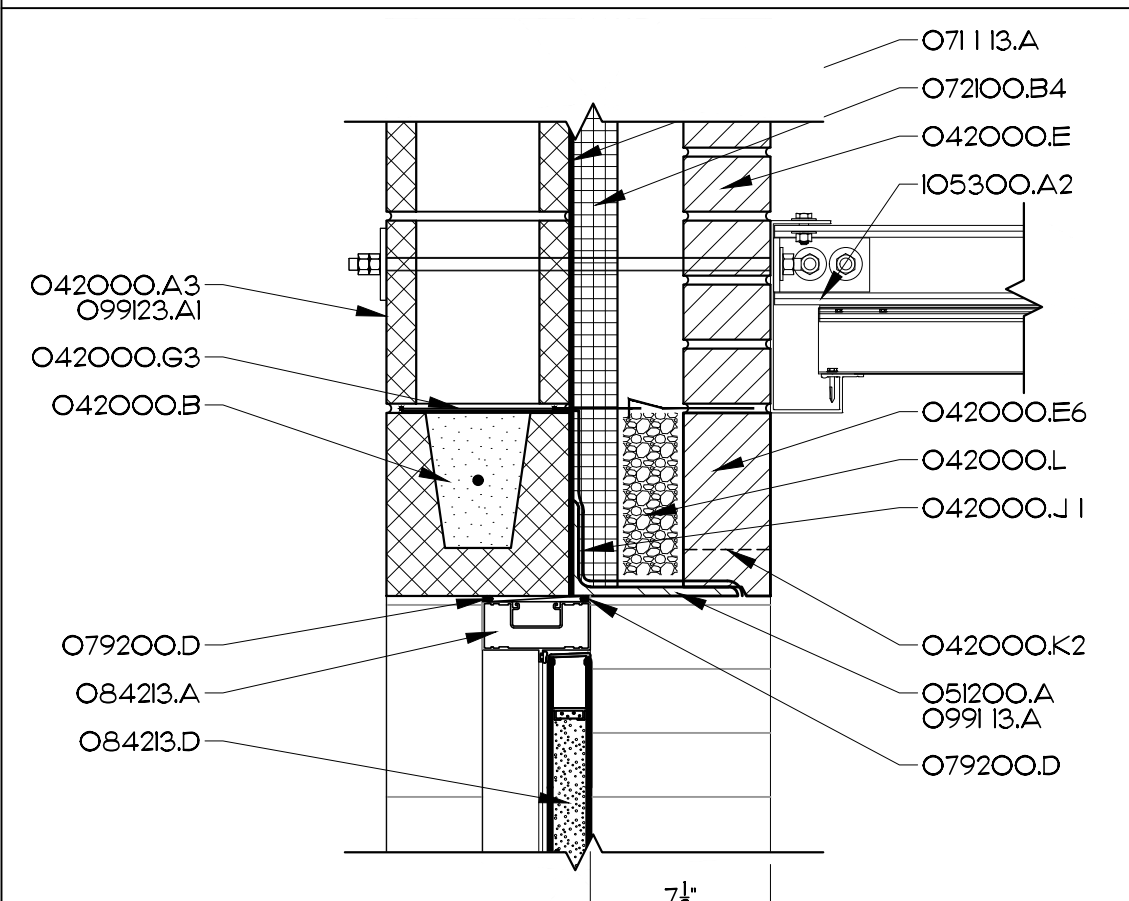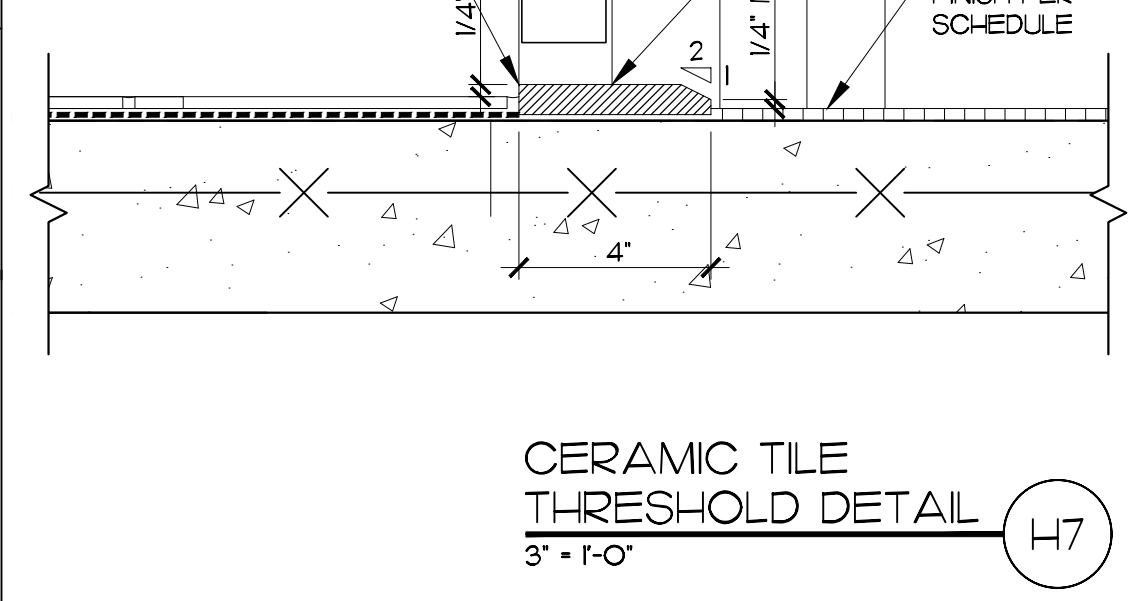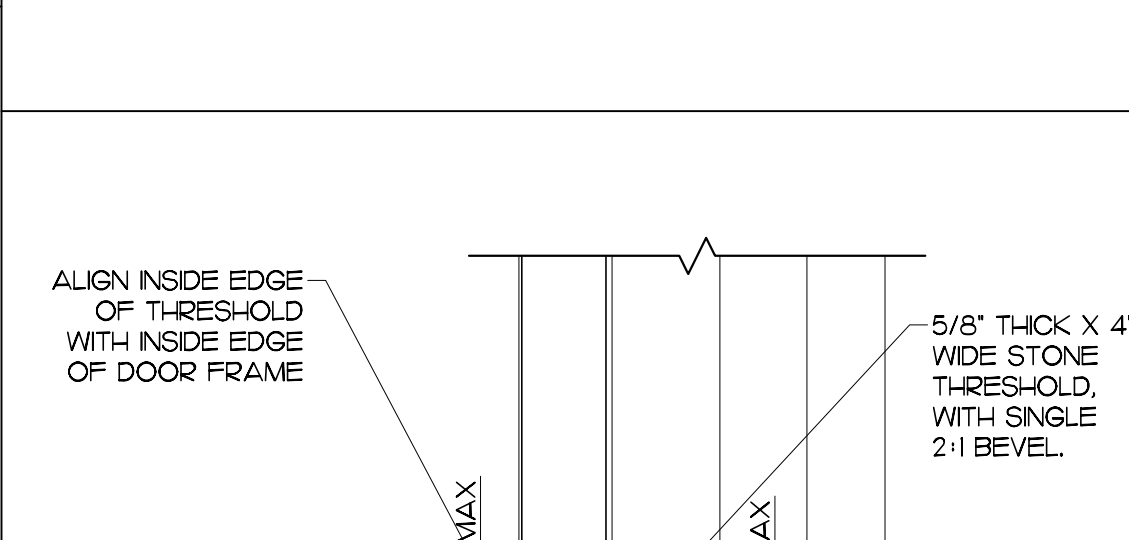




HEAD DETAIL
1 1/2" x 1'-0" (E7)

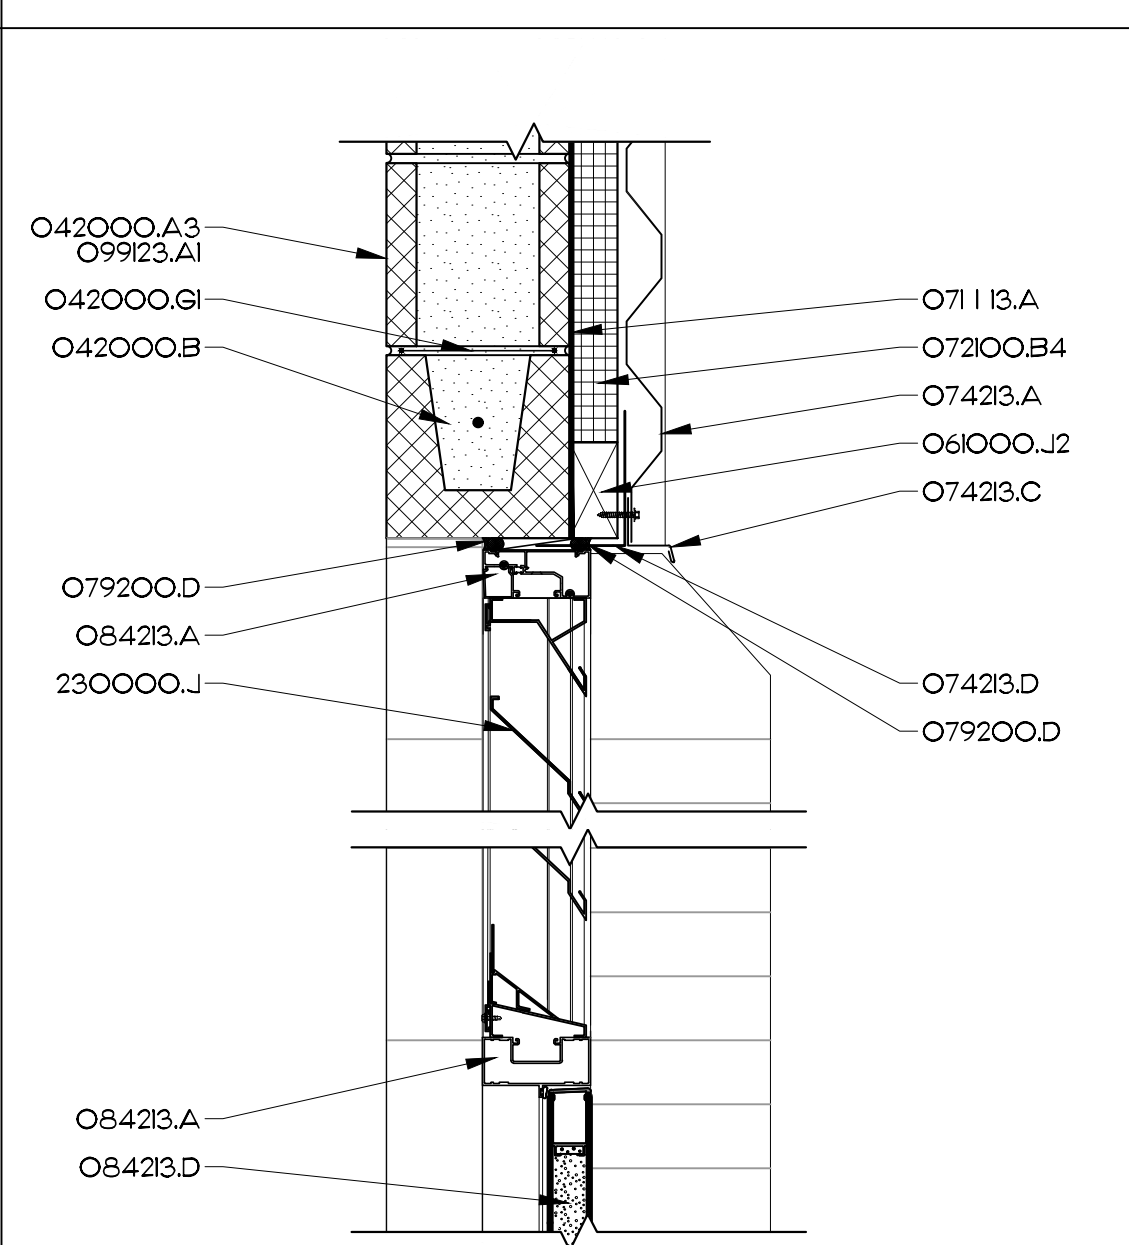


HEAD DETAIL
1 1/2" x 1'-0" (A7)

WINDOW SCHEDULE											
WINDOW GROUP NO.	WINDOW UNIT SIZE (W X H)	WINDOW TYPE	MATERIAL	FINISH	FRAME ELEVATION	UNIT THICKNESS	DETAILS			GLASS	FIRE RATING (HRS)
							J	H	S		
WI	4'-0" X 7'-4"	FIXED	AL	AN	WI	3 1/4"	E3 A61	G10 A62	A10 A62	LOW E	-
REMARKS											

WINDOW TYPES

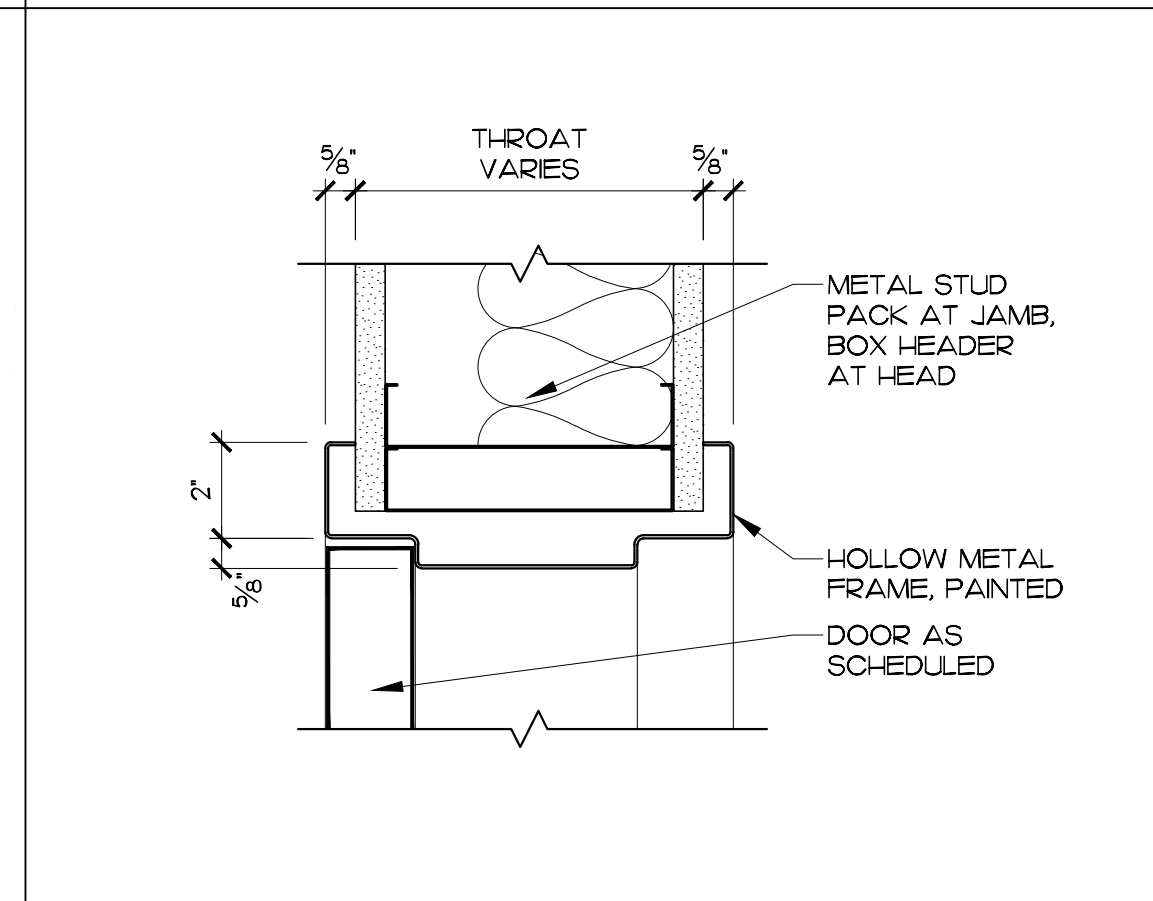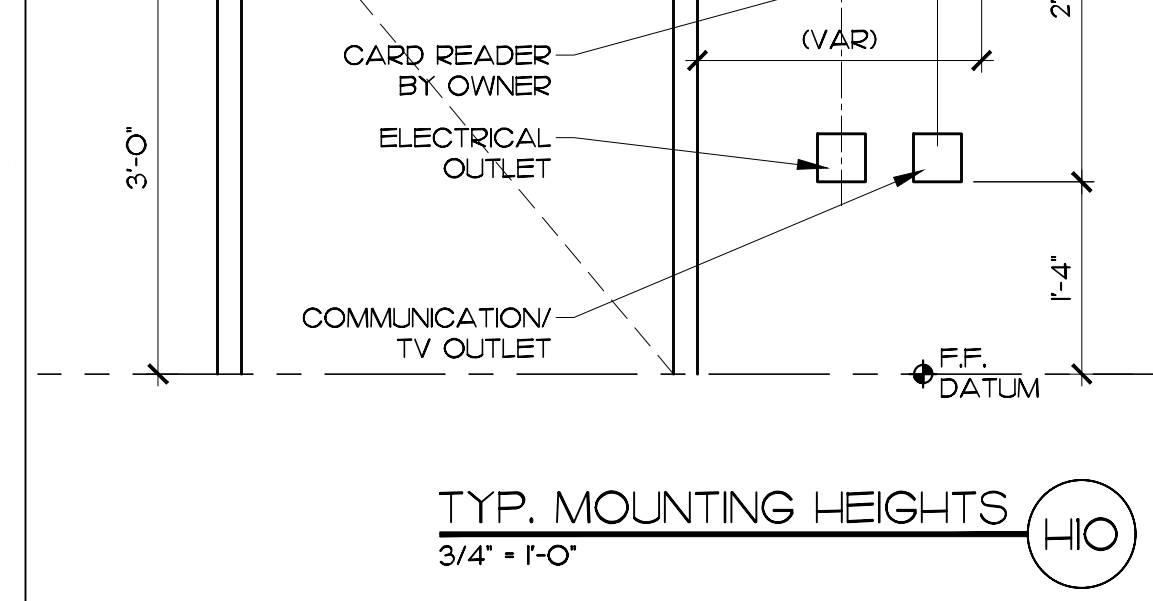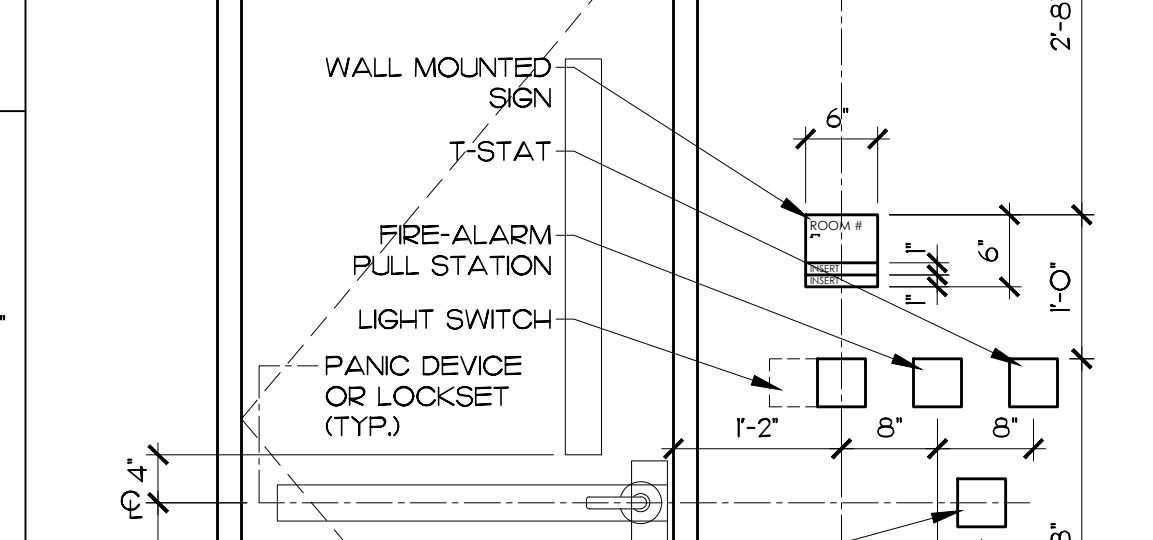




HEAD DETAIL
1 1/2" x 1'-0" (E7)

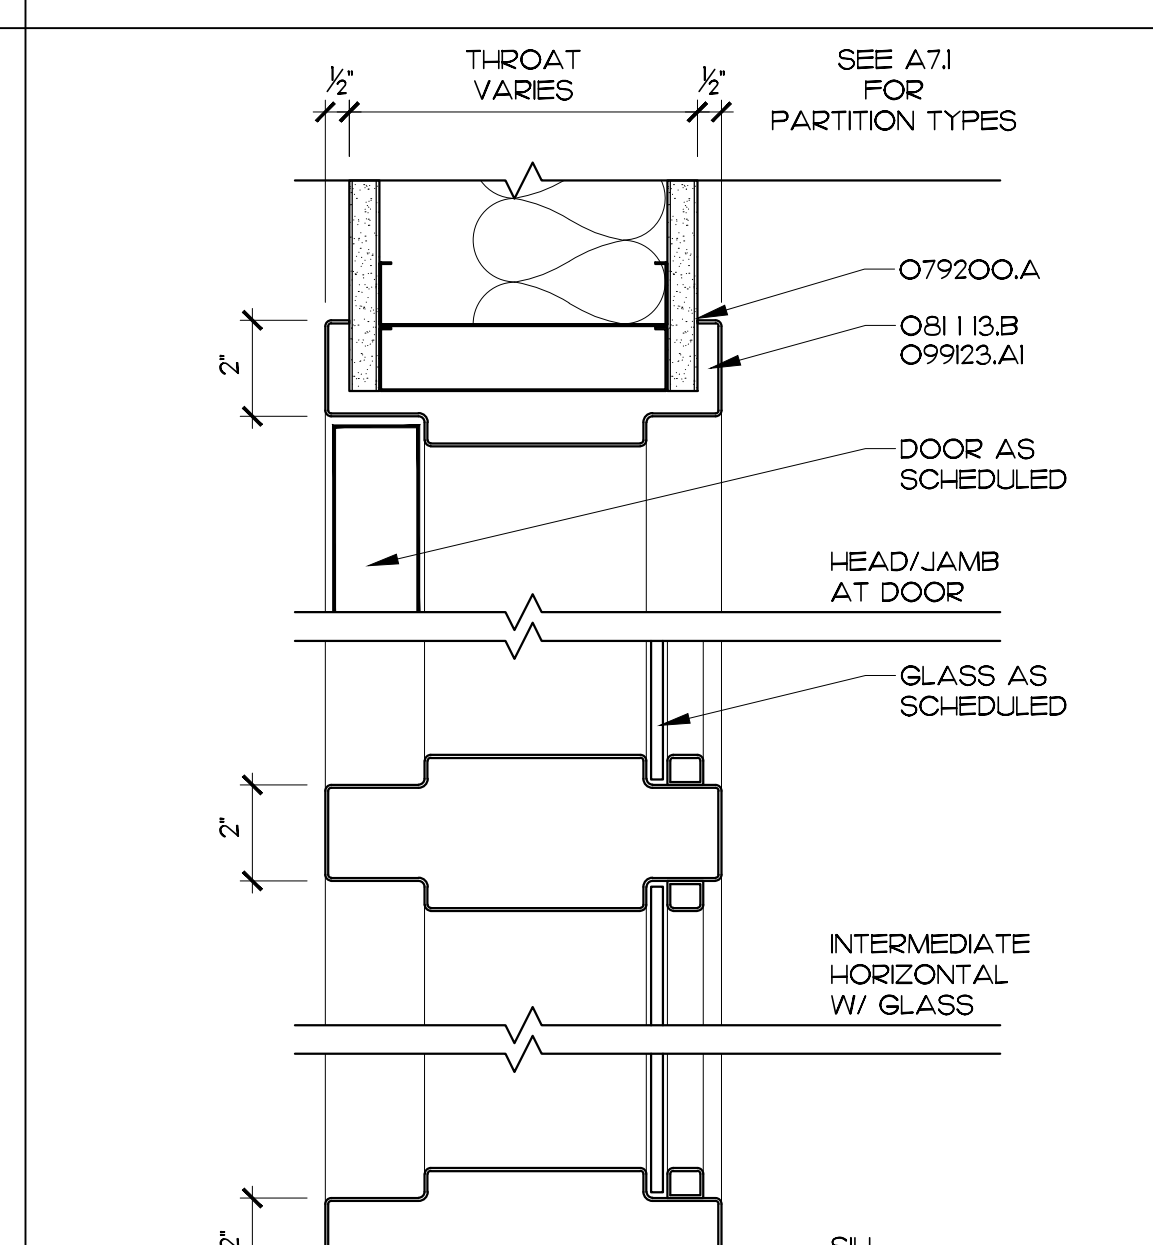


HEAD DETAIL
1 1/2" x 1'-0" (A7)

DOOR SCHEDULE											
DOOR GROUP NO.	DOOR OPENING SIZE (W X H)	DOOR TYPE	THICKNESS (1-3/4" U.N.O.)	MATERIAL	FINISH	FRAME ELEVATION	MATERIAL	FINISH	DETAILS		
									J	H	S
1	3'-0" X 7'-2"	C	1-3/4"	AL	AN	F4	AL	AN	A61 A62	D5 A62	A5 A62
2	3'-0" X 7'-2"	B	1-3/4"	AL	FRP	F1	AL	AN	A9 A61	D5 A62	A5 A62
3	3'-0" X 7'-2"	B	1-3/4"	AL	FRP	F1	AL	AN	A9 A61	D5 A62	A5 A62
4	(2) 3'-0" X 7'-2"	AA	1-3/4"	AL	FRP	F3	AL	AN	A9 A61	D5 A62	A5 A62
5	3'-0" X 7'-2"	A	1-3/4"	HM	TF	F4	HM	P	A10 A61	A10 A61	A10 A61
6	12'-0" X 10'-0"	D	1"	SS	SS	F6	SS	SS	E12 A61	E4	-
7	3'-0" X 7'-2"	A	1-3/4"	HM	TF	F5	HM	P	A10 A61	A10 A61	A10 A61
8	3'-0" X 7'-2"	A	1-3/4"	HM	TF	F1	HM	P	E10 A61	E10 A61	H7
REMARKS											

DOOR TYPES

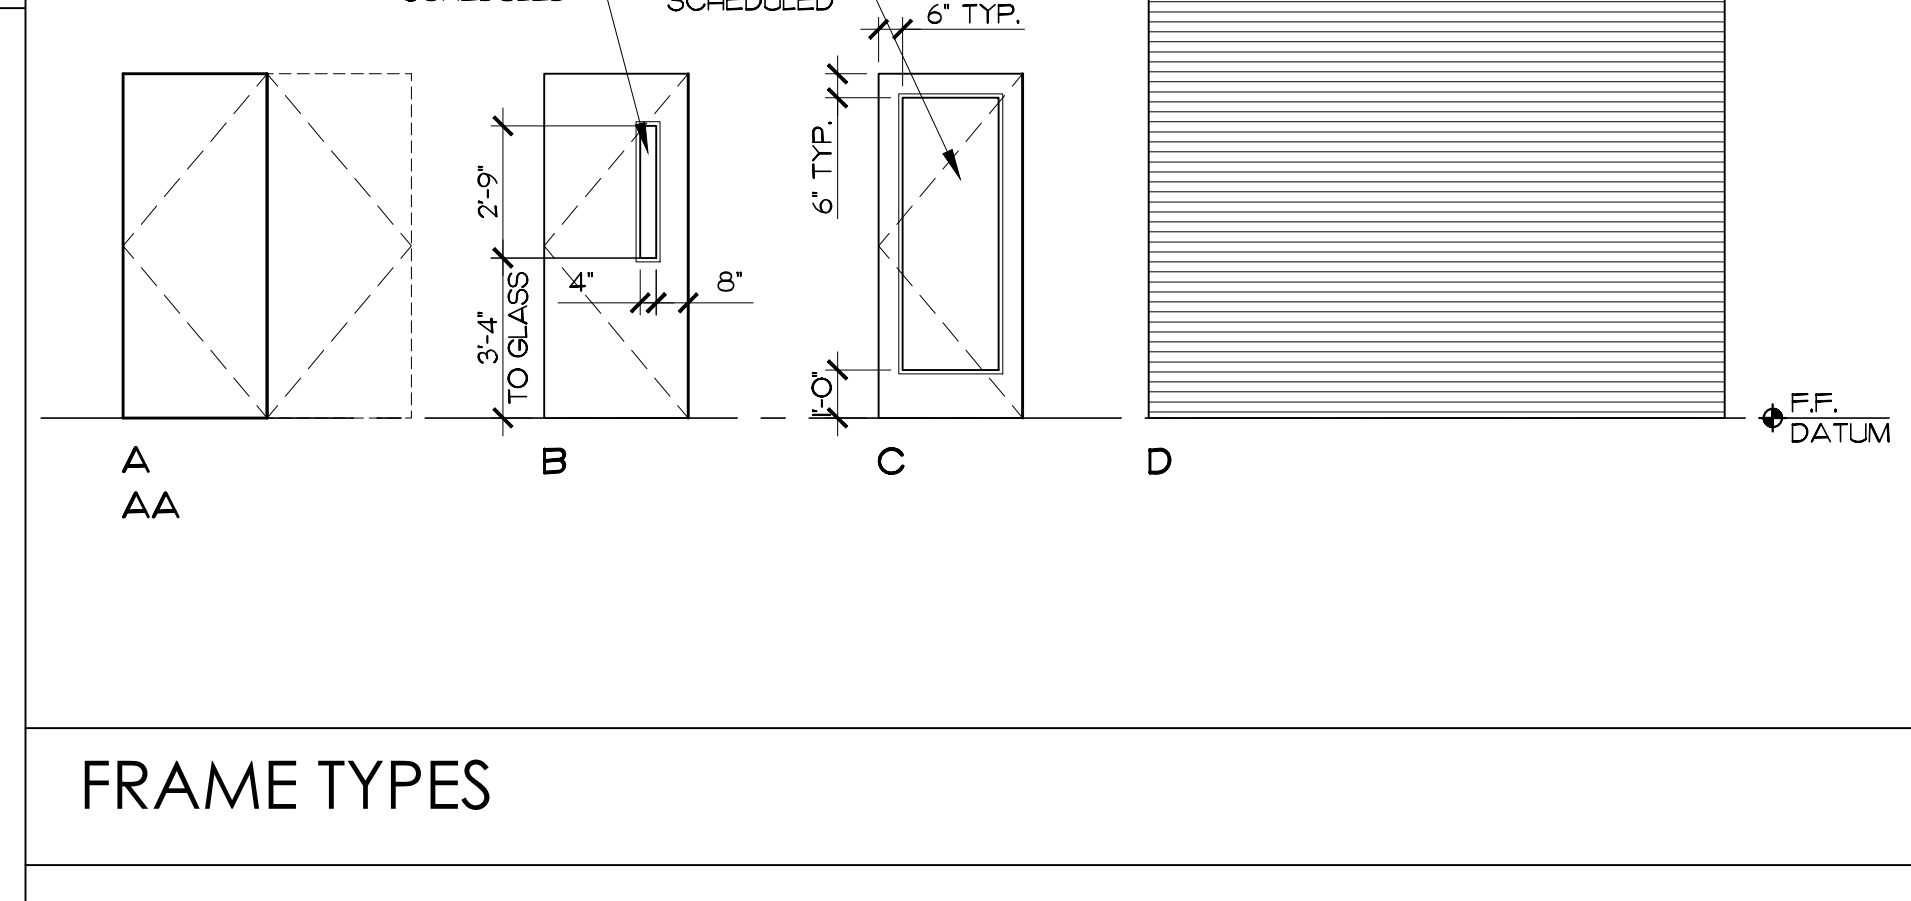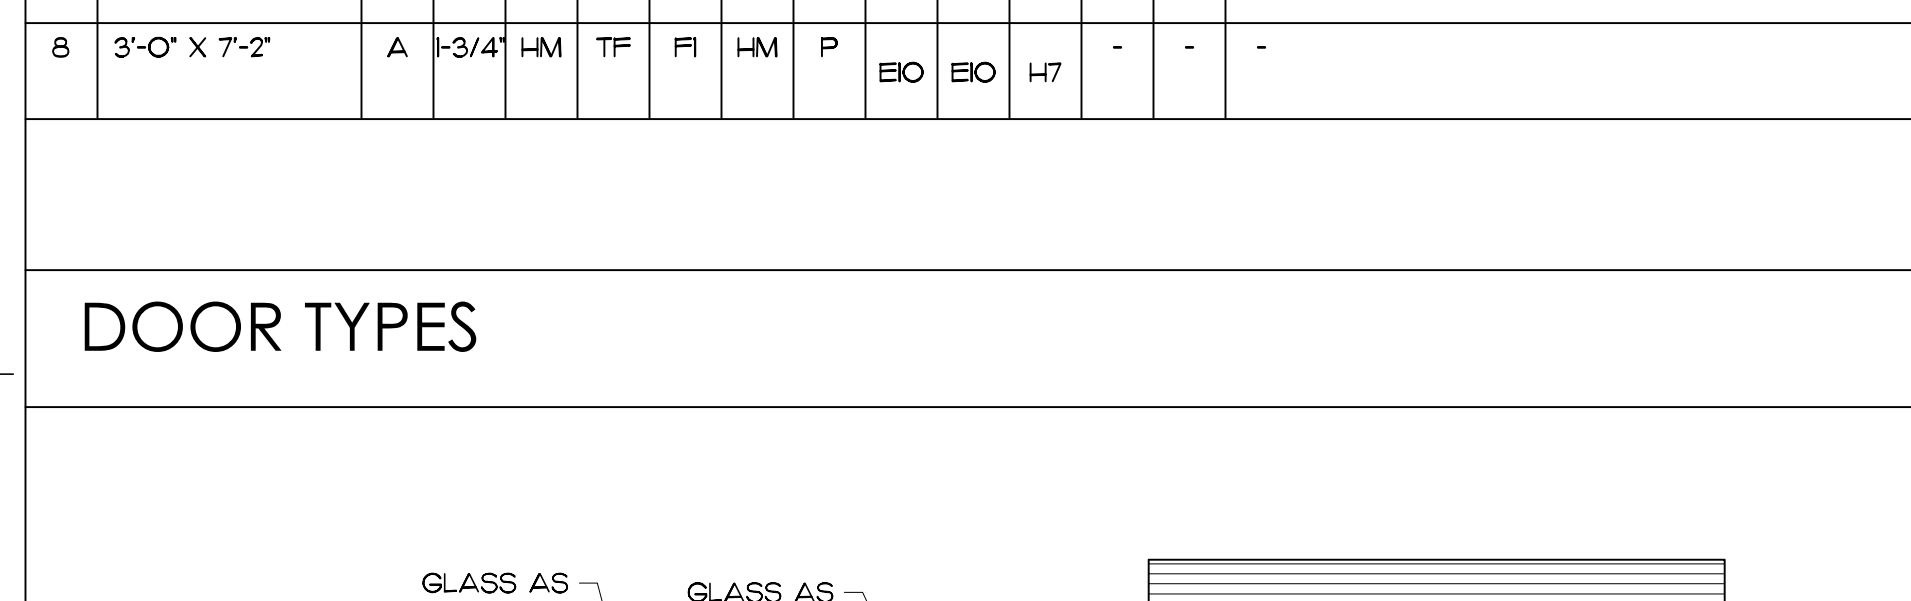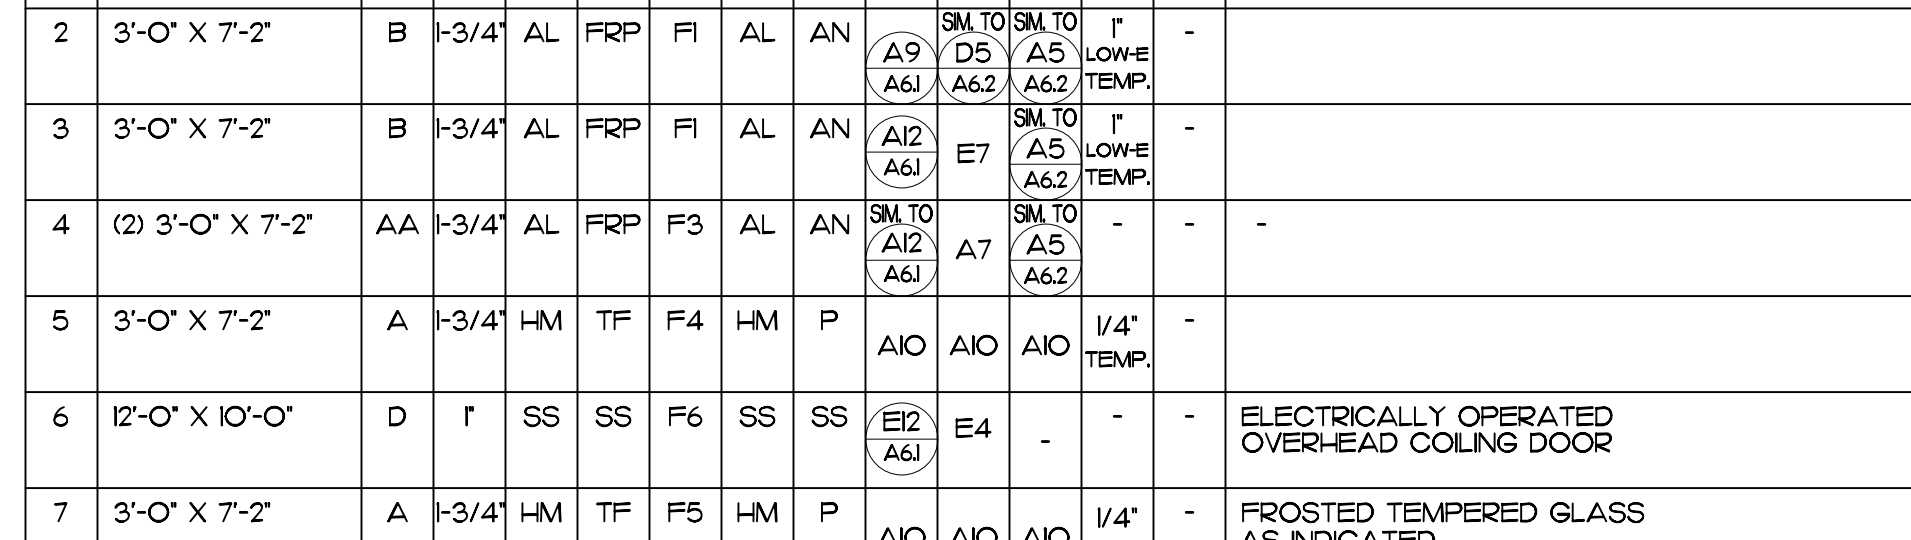



HEAD DETAIL
1 1/2" x 1'-0" (E7)

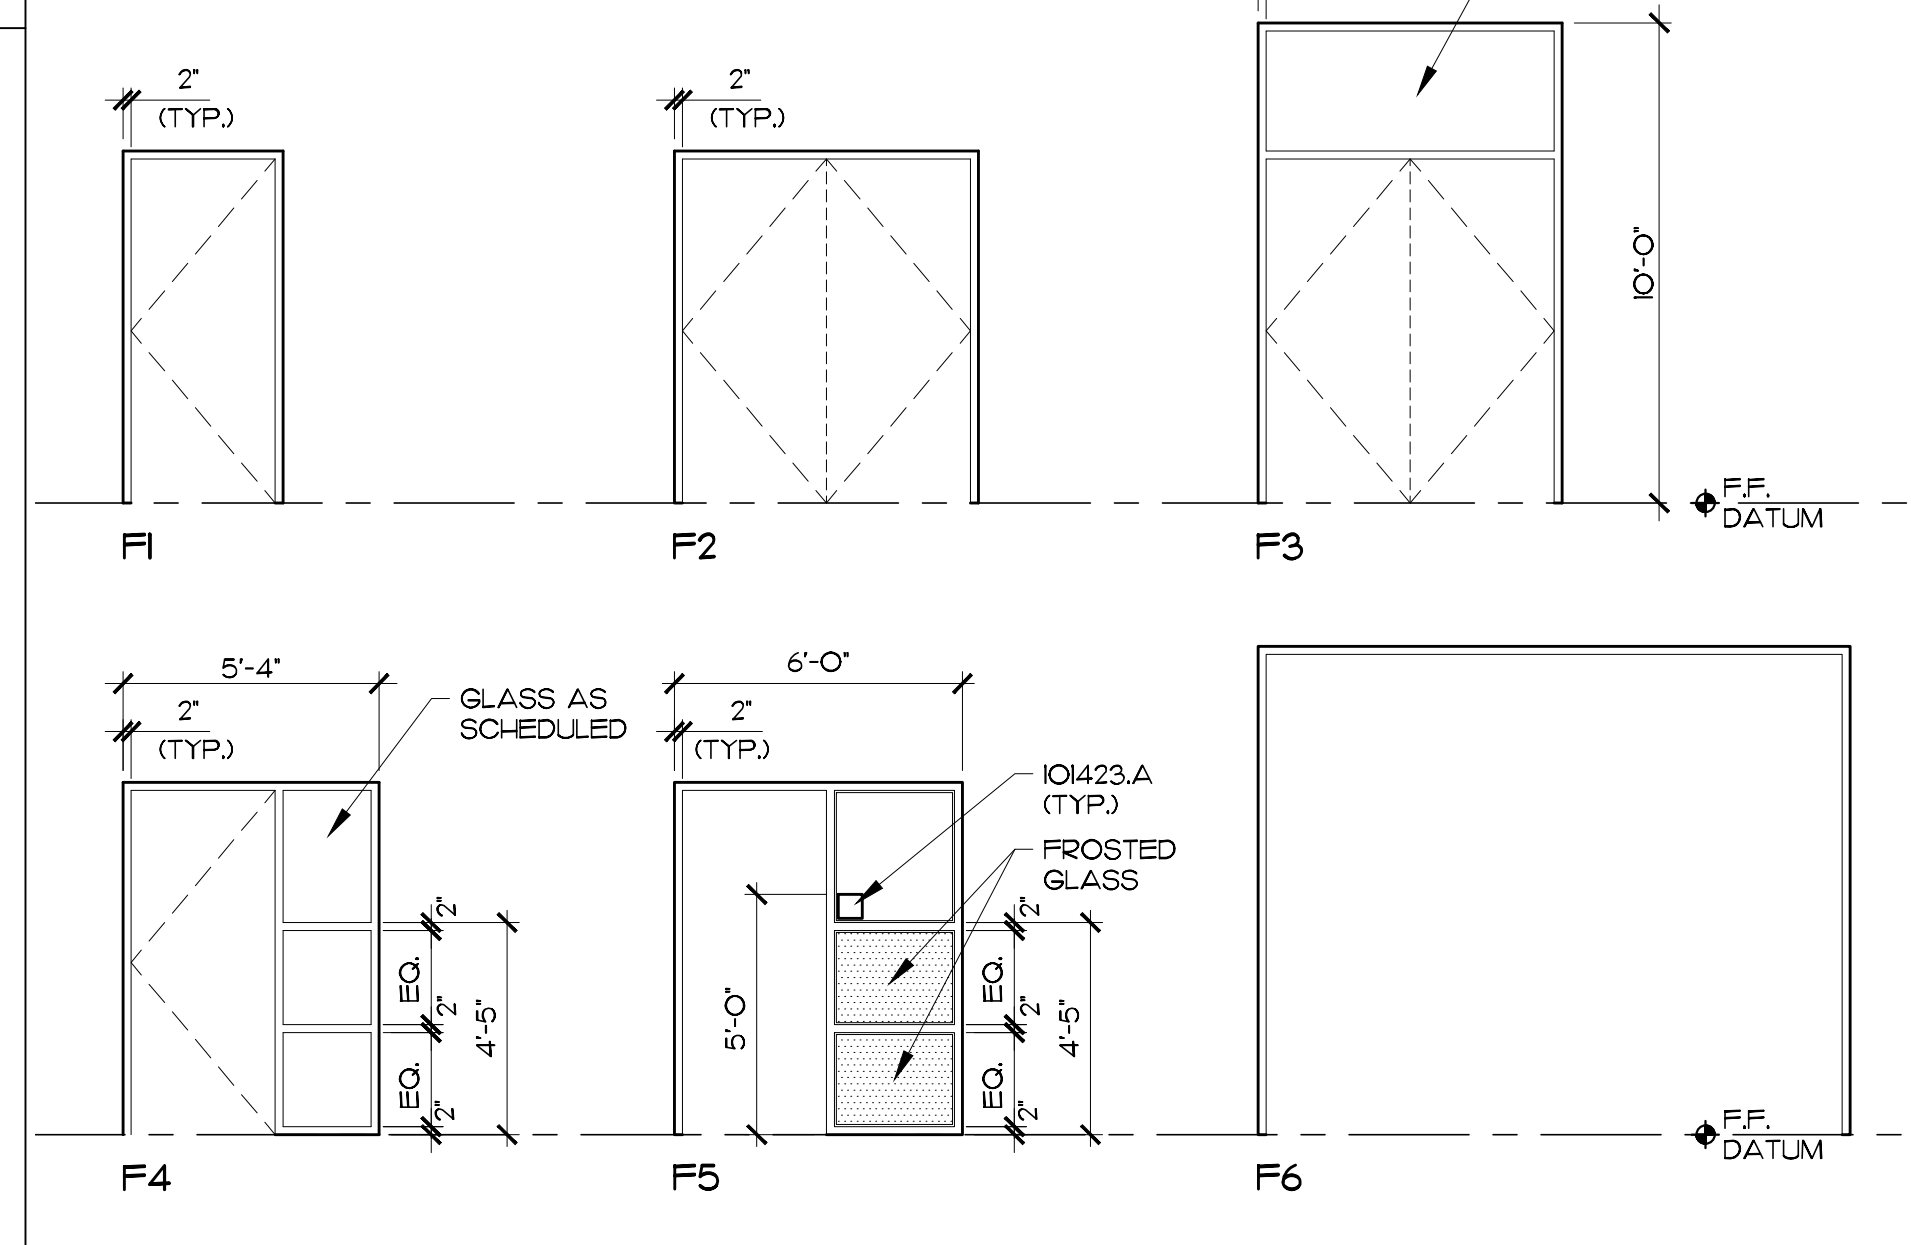


HEAD DETAIL
1 1/2" x 1'-0" (A7)

DOOR SCHEDULE											
DOOR GROUP NO.	DOOR OPENING SIZE (W X H)	DOOR TYPE	THICKNESS (1-3/4" U.N.O.)	MATERIAL	FINISH	FRAME ELEVATION	MATERIAL	FINISH	DETAILS		
									J	H	S
1	3'-0" X 7'-2"	C	1-3/4"	AL	AN	F4	AL	AN	A61 A62	D5 A62	A5 A62
2	3'-0" X 7'-2"	B	1-3/4"	AL	FRP	F1	AL	AN	A9 A61	D5 A62	A5 A62
3	3'-0" X 7'-2"	B	1-3/4"	AL	FRP	F1	AL	AN	A9 A61	D5 A62	A5 A62
4	(2) 3'-0" X 7'-2"	AA	1-3/4"	AL	FRP	F3	AL	AN	A9 A61	D5 A62	A5 A62
5	3'-0" X 7'-2"	A	1-3/4"	HM	TF	F4	HM	P	A10 A61	A10 A61	A10 A61
6	12'-0" X 10'-0"	D	1"	SS	SS	F6	SS	SS	E12 A61	E4	-
7	3'-0" X 7'-2"	A	1-3/4"	HM	TF	F5	HM	P	A10 A61	A10 A61	A10 A61
8	3'-0" X 7'-2"	A	1-3/4"	HM	TF	F1	HM	P	E10 A61	E10 A61	H7
REMARKS											

 DOOR TYPES

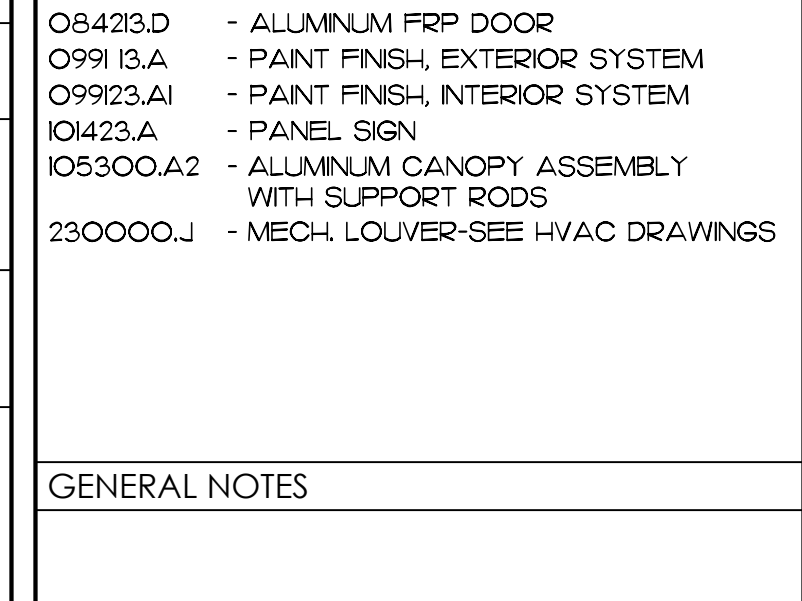

HEAD DETAIL
1 1/2" x 1'-0" (E7)

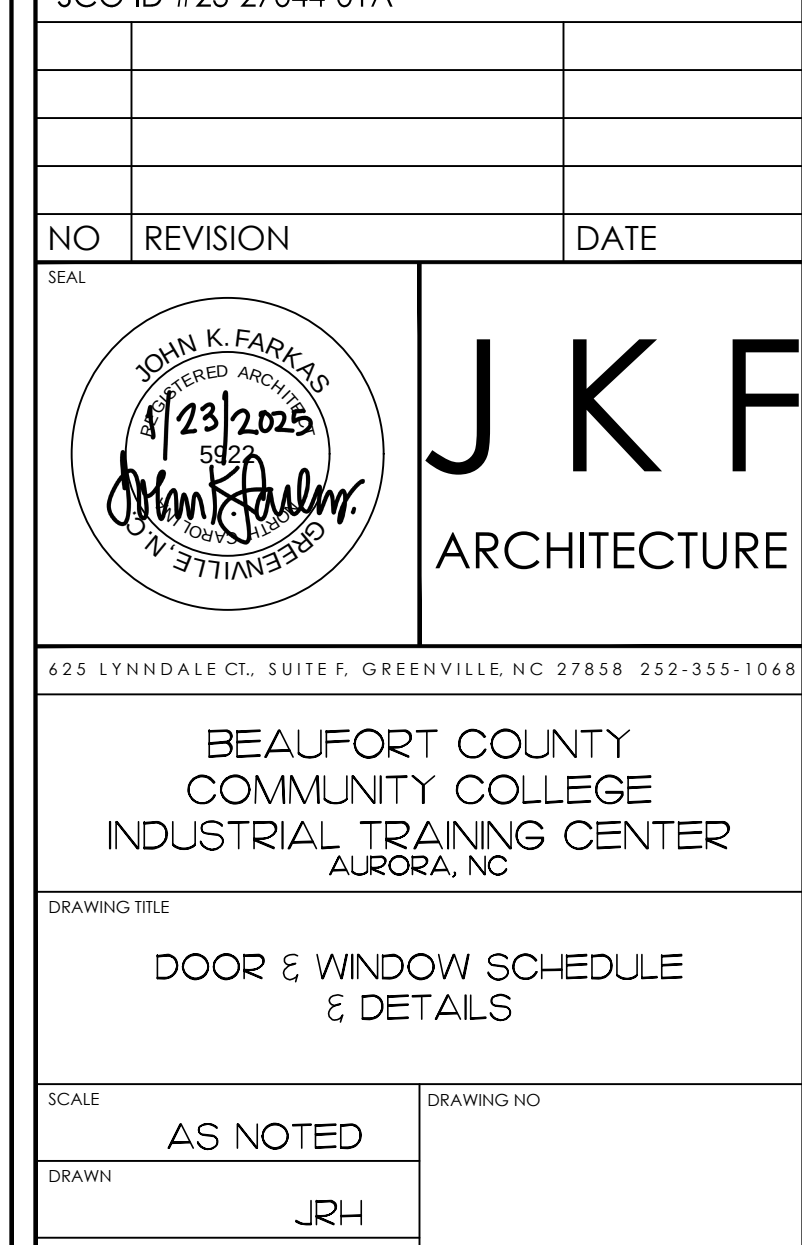

HEAD DETAIL
1 1/2" x 1'-0" (A7)

GENERAL NOTES

KEY PLAN

SCO ID #23-27044-01A

NO REVISION DATE

JOHN K. FARKAS ARCHITECTURE

BEAUFORT COUNTY COMMUNITY COLLEGE INDUSTRIAL TRAINING CENTER AURORA, NC

DOOR & WINDOW SCHEDULE & DETAILS

SCALE AS NOTED

DRAWN JKH

CHECKED JKF

DATE 1-6-2025

PROJECT NO. 2024-10

COPYRIGHT, JKF ARCHITECTURE PC, JOHN K. FARKAS, AIA

	2	3	4	5	6	7	8	9	10	11	12	13	14	15																																																																																																																																																																																																			
GENERAL NOTES: 2018 APPENDIX B BUILDING CODE SUMMARY FOR ALL COMMERCIAL PROJECTS STRUCTURAL DESIGN DESIGN LOADS: IMPORTANCE FACTORS: WIND (<i>w</i>) 1.0 SNOW (<i>s</i>) 1.0 SEISMIC (<i>e</i>) 1.0 LIVE LOADS: ROOF 20 PSF SLAB ON GRADE 150 PSF GROUND SNOW LOAD: 10 PSF WIND LOAD: ULTIMATE WIND SPEED 131 MPH (ASCE-7) EXPOSURE CATEGORY C SEISMIC DESIGN CATEGORY: B RISK CATEGORY (TABLE 1604.5)II SPECTRAL RESPONSE ACCELERATION <i>S_s</i> .113G <i>S₁</i> .058G SITE CLASSIFICATION (ASCE 7): D DATA SOURCE: GEOTECHNICAL EXPLORATION REPORT BASIC STRUCTURAL SYSTEM: ORDINARY MASONRY SHEAR WALLS ANALYSIS PROCEDURE: EQUIVALENT LATERAL FORCE ARCHITECTURAL, MECHANICAL, COMPONENTS ANCHORED: AS REQUIRED BY CHAPTER 13 OF ASCE 7-10. LATERAL DESIGN CONTROL: WIND LOADS SOIL BEARING CAPACITIES: 1,500 PSF GENERAL NOTES: 1. ALL WORK SHALL COMPLY WITH THE CODES LISTED BELOW AND IN THE SPECIFICATIONS. 2. THIS STRUCTURE HAS BEEN DESIGNED IN ACCORDANCE WITH THE PROVISIONS OF THE INTERNATIONAL BUILDING CODE, 2015 EDITION, AS ADOPTED BY THE 2018 NORTH CAROLINA STATE BUILDING CODE, EFFECTIVE JANUARY 01, 2019. 3. VERIFY ALL DRAWINGS FOR COORDINATION BETWEEN TRADES, LOCATE SLOTS, SLEEVES AND TRENCHES AS REQUIRED FOR MECHANICAL TRADES. PROVIDE AND INSTALL ANCHORS, INSERTS, HANGERS, ETC. AS REQUIRED FOR VARIOUS TRADES. 4. SUBMIT SHOP DRAWINGS FOR APPROVAL BEFORE PROCEEDING WITH THE WORK. THE CONTRACTOR MUST CHECK ALL DIMENSIONS AND ACCEPT FULL RESPONSIBILITY FOR DIMENSIONAL CORRECTNESS. 5. UNDER NO CIRCUMSTANCES CAN THE REPRODUCTION OF CONTRACT DRAWINGS BE USED AS SHOP DRAWINGS. 6. PROVIDE ALL TEMPORARY GUYING AND BRACING REQUIRED TO ERECT AND HOLD THE STRUCTURE IN PROPER ALIGNMENT UNTIL ALL STRUCTURAL WORK AND CONNECTIONS HAVE BEEN COMPLETED. 7. LOADING APPLIED TO THE STRUCTURE DURING THE PROCESS OF CONSTRUCTION MUST NOT EXCEED THE SAFE LOAD-CARRYING CAPACITY OF THE STRUCTURAL MEMBERS. THE LIVE LOADINGS USED IN THE DESIGN OF THIS STRUCTURE ARE INDICATED IN THE "DESIGN CRITERIA". DO NOT APPLY ANY CONSTRUCTION LOADS UNTIL ALL STRUCTURAL FRAMING IS PROPERLY CONNECTED TOGETHER AND UNTIL ALL TEMPORARY BRACING IS IN PLACE. 8. IN ACCORDANCE WITH GENERALLY ACCEPTED CONSTRUCTION PRACTICES, CONTRACTOR WILL BE SOLELY AND COMPLETELY RESPONSIBLE FOR CONDITION OF JOB SITE INCLUDING SAFETY OF ALL PERSONS AND PROPERTY DURING PERFORMANCE OF THE WORK. 9. THE DUTY OF THE ARCHITECT IN CONDUCTING CONSTRUCTION REVIEW OF CONTRACTOR'S PERFORMANCE IS NOT INTENDED TO INCLUDE REVIEW OF ADEQUACY OF CONTRACTOR'S SAFETY MEASURES IN, ON, OR NEAR THE CONSTRUCTION SITE. 10. TYPICAL DETAILS AND GENERAL NOTES APPLY TO ALL PARTS OF THE JOB EXCEPT WHERE SPECIFICALLY DETAILED OR NOTED OTHERWISE. 11. STRUCTURAL DRAWINGS SHOW ONLY THE BASIC STRUCTURAL FRAMING. REFER TO ARCHITECTURAL, MECHANICAL AND ELECTRICAL DRAWINGS FOR NON-STRUCTURAL ITEMS WHICH REQUIRE SPECIAL PROVISIONS DURING THE CONSTRUCTION OF THE STRUCTURAL FRAME. 12. INFORM THE PROFESSIONAL OF RECORD IN WRITING OF ANY DEVIATION FROM THE CONTRACT DOCUMENTS. THE CONTRACTOR IS NOT RELIEVED OF THE RESPONSIBILITY OF SUCH DEVIATION BY THE PROFESSIONAL OF RECORD REVIEW OF SHOP DRAWINGS, PRODUCT DATA, ETC. UNLESS THE CONTRACTOR HAS SPECIFICALLY INFORMED THE PROFESSIONAL OF RECORD OF SUCH DEVIATION AT THE TIME OF SUBMISSION, AND THE PROFESSIONAL OF RECORD HAS GIVEN WRITTEN APPROVAL TO THE SPECIFIC DEVIATION. FOUNDATION NOTES: 1. FOUNDATIONS FOR THIS STRUCTURE HAVE BEEN DESIGNED IN ACCORDANCE WITH THE RECOMMENDATIONS IN THE GEOTECHNICAL EXPLORATION REPORT, PREPARED BY TERRACON CONSULTANTS, INC DATED SEPTEMBER 3, 2024. 2. PERFORM ALL EARTHWORK IN ACCORDANCE WITH THE SPECIFICATIONS. 3. THE ENTIRE STRUCTURE SHALL BE FOUNDED ON VERY WELL COMPACTED STRUCTURAL FILL OR UNDISTURBED SOIL WITH A DESIGN BEARING PRESSURE OF 1500 P.S.F. 4. PRIOR TO PLACING FOUNDATION CONCRETE, ALL FOUNDATION EXCAVATIONS SHALL BE INSPECTED BY THE GEOTECHNICAL ENGINEER TO VERIFY THE EXTENT OF ANY LOOSE, SOFT, OR UNSATISFACTORY SOIL AND TO VERIFY THE DESIGN BEARING PRESSURE. THE GEOTECHNICAL ENGINEER WILL PROVIDE DIRECTION FOR CORRECTIVE ACTION WHERE REQUIRED. 5. DO NOT INSTALL FOUNDATION WORK UNTIL IT HAS BEEN COORDINATED WITH ADJACENT UNDERGROUND UTILITIES. FOOTINGS SHALL BE SLEEVED OR LOWERED WHERE REQUIRED. DO NOT INSTALL UTILITIES UNDER ISOLATED COLUMN FOOTINGS. INSTALL UTILITIES PERPENDICULAR TO WALL FOOTINGS. INSTALL SLEEVES TO ACCOMMODATE PLUMBING OR UTILITY LINES PRIOR TO POURING FOOTING CONCRETE OR LOWER FOOTINGS SO PLUMBING OR UTILITY LINES OCCUR OVER THE TOP OF THE FOOTINGS. REFER TO TYPICAL DETAILS. 6. DO NOT PUT IN UNBALANCED BACKFILL AGAINST FOUNDATION WALLS UNLESS WALLS ARE SECURELY BRACED AGAINST OVERTURNING. 7. FROST LINE DEPTH IS 12"BELOW GRADE. BOTTOM OF EXTERIOR FOUNDATIONS SHALL BEAR A MINIMUM OF 12" BELOW FINAL GRADE. LOWER FOOTINGS AS REQUIRED TO MAINTAIN COVERAGE. CAST IN PLACE CONCRETE NOTES: 1. CAST IN PLACE CONCRETE MUST COMPLY WITH THE AMERICAN CONCRETE INSTITUTE (ACI- 318-14), COMMENTARY, (ACI-318R-14), AND THE SPECIFICATIONS FOR STRUCTURAL CONCRETE (ACI 301). 2. DETAILING OF ALL CONCRETE STEEL REINFORCEMENT MUST BE IN ACCORDANCE WITH THE MANUAL OF STANDARD PRACTICE FOR DETAILING REINFORCED CONCRETE STRUCTURES (ACI-315). 3. ALL CONCRETE MUST BE NORMAL WEIGHT, UNLESS OTHERWISE NOTED, CONCRETE HAVING A MINIMUM COMPRESSIVE STRENGTH AT 28 DAYS AS FOLLOWS: A) INTERIOR SLAB ON GRADE 4,000 PSI B) FOUNDATIONS 3,000 PSI C) CONCRETE NOT OTHERWISE NOTED 4,500 PSI D) CONCRETE EXPOSED TO WEATHER MUST BE AIR ENTRAINED. 4. ALL REINFORCING MUST BE AS FOLLOWS: A) REINFORCING BARS – ASTM A-615, GRADE 60 B) WELDED REINFORCING BARS – ASTM A706, GRADE 60 C) WELDED WIRE REINFORCEMENT – ASTM A-1064 FLAT SHEET TYPE, ROLL TYPE NOT ACCEPTABLE. 5. WELDED WIRE REINFORCEMENT MUST BE PROPERLY SUPPORTED PRIOR TO PLACING CONCRETE. HOOKING OF FABRIC IS NOT PERMITTED. 6. UNLESS OTHERWISE NOTED, REINFORCING STEEL MARKED CONTINUOUS (CONT.) MUST BE LAPPED PER THE REINFORCING LAP SCHEDULE. 7. HOLD ALL REINFORCING STEEL SECURELY IN PLACE TO PREVENT DISLOCATION DURING THE POURING OPERATION. SUPPORT SLAB REINFORCING BARS ON HIGH CHAIRS AND BAR SPACERS OF SUITABLE DESIGN, OR CONCRETE BLOCKS HAVING THE SAME MINIMUM COMPRESSIVE STRENGTH OF THE CONCRETE SLAB. 8. DO NOT PLACE CONCRETE UNTIL ALL EMBEDDED WORK HAS BEEN INSTALLED, TESTED AND INSPECTED. 9. EXCEPT AS OTHERWISE SHOWN MINIMUM PROTECTION (CONCRETE COVER) FOR REINFORCING STEEL MUST BE AS FOLLOWS: CONCRETE SURFACES CAST AGAINST SOIL: 3" CONCRETE SURFACES EXPOSED TO EARTH OR WEATHER: 2" INTERIOR CONCRETE SURFACES: 1" FOR SLABS OPEN WEB STEEL JOIST NOTES: 1. OPEN-WEB STEEL JOIST MUST COMPLY WITH THE STANDARD SPECIFICATION FOR OPEN WEB JOISTS OF THE STEEL JOIST INSTITUTE (SJI), LATEST EDITION. 2. OPEN-WEB STEEL JOIST MUST HAVE A MINIMUM BEARING LENGTH AS FOLLOWS: ON STEEL – 'K' SERIES = 4" ON MASONRY – AS DETAILED 3. WELD ALL STEEL JOISTS WHEREVER THEY BEAR ON STRUCTURAL STEEL MEMBERS, IN ACCORDANCE WITH THE S.J.I AND THE A.I.S.C SPECIFICATIONS 4. PREPARE AND SUBMIT SHOP DRAWINGS INDICATING THE JOIST LAYOUT, SPECIAL CONNECTIONS, AND ACCESSORIES. INCLUDE MARK, NUMBER, TYPE, LOCATION, AND SPACING OF JOISTS AND BRIDGING. 5. THE JOIST MANUFACTURER IS RESPONSIBLE FOR CONTINUOUS JOIST BRIDGING LINES SATISFYING THE REQUIREMENTS OF THE SJI SPECIFICATION FOR THE TOP AND BOTTOM CHORDS OF ALL STEEL JOISTS, AS WELL AS ANY ADDITIONAL BRIDGING / BRACING SHOWN ON THE DRAWINGS OR REQUIRED FOR JOISTS SUBJECTED TO NET UPLIFT OF OTHER SPECIAL LOADS. PROVIDE JOIST BRIDGING REQUIRED AT CHANGES OF JOIST DEPTHS AND AT ENDS OF ALL BRIDGING LINES UNLESS SUCH ENDS ARE PROPERLY ANCHORED INTO THE INTERSECTING INTERIOR OR END WALLS. 6. REFER TO DESIGN CRITERIA NOTES FOR NET UPLIFT LOAD ON ROOF JOISTS. A SINGLE LINE OF BOTTOM CHORD BRIDGING MUST BE PROVIDED NEAR THE FIRST BOTTOM CHORD PANEL POINTS WHENEVER UPLIFT LOADS OCCUR. 7. INSTALL JOIST BRIDGING AND CONNECTIONS COMPLETELY PRIOR TO PLACING ANY CONSTRUCTION LOADS ON THE JOISTS. CONSTRUCTION LOADING MUST NOT EXCEED THE JOIST DESIGN LOAD. 8. REINFORCE CONCENTRATED LOADS EXCEEDING 100 POUNDS AND NOT LOCATED AT JOIST PANEL POINTS PER THE TYPICAL DETAIL. 9. DO NOT APPLY PAINT OR PRIMER ON STEEL JOISTS OR ACCESSORIES RECEIVING SPRAYED FIRE- RECEIVING MATERIALS. SEE THE ARCHITECTURAL DRAWINGS FOR EXTENTS OF SPRAYED FIRE RESISTIVE MATERIALS. STRUCTURAL STEEL NOTES: 1. STRUCTURAL STEEL MUST COMPLY WITH THE FOURTEENTH EDITION OF THE AMERICAN INSTITUTE OF STEEL CONSTRUCTION (AISC 360-10) "SPECIFICATION FOR STRUCTURAL STEEL BUILDINGS". 2. STRUCTURAL STEEL MUST BE NEW, CLEAN, AND STRAIGHT, AND CONFORM TO THE FOLLOWING: A)STEEL W- AND WT SHAPES – ASTM A992, GRADE 50 B)RECTANGULAR AND SQUARE HSS SHAPES – ASTM A500, GRADE C C)ANCHOR RODS – ASTM F1554, GRADE 36 D)HIGH STRENGTH BOLTS – ASTM A325 E)ALL OTHER STEEL SHAPES – ASTM A36, UNLESS OTHERWISE NOTED 3. UNLESS OTHERWISE NOTED, ALL CONNECTIONS MUST BE STANDARD SHEAR BEAM CONNECTIONS. THE FABRICATOR IS RESPONSIBLE FOR DESIGNING ALL CONNECTIONS. WHERE REACTIONS ARE NOT INDICATED ON PLAN, CONNECTIONS MUST BE DESIGNED FOR ½ OF THE TOTAL ALLOWABLE UNIFORM LOAD FOR LATERALLY SUPPORTED BEAMS GIVEN IN PART 3 OF THE "STEEL CONSTRUCTION MANUAL" 14TH EDITION. CONNECTION DETAILS MUST BE IN ACCORDANCE WITH AISC STANDARDS. 4. UNLESS OTHERWISE NOTED WELD ALL SHOP CONNECTIONS AND BOLT ALL FIELD CONNECTIONS. THE FABRICATOR IS RESPONSIBLE FOR THE DESIGN OF ALL CONNECTIONS. REFER TO SPECIFICATIONS. 5. SHOW ALL HOLES REQUIRED IN STRUCTURAL STEEL MEMBERS FOR PIPING ON THE SHOP DRAWINGS AND MAKE THEM IN THE SHOP. DO NOT CUT HOLES IN THE FIELD WITHOUT THE APPROVAL OF THE REGISTERED DESIGN PROFESSIONAL OF RECORD. 6. WELDING MUST COMPLY WITH THE "STRUCTURAL WELDING CODE – STEEL" (AWS D1.1). WELD ELECTRODES MUST BE E70XX.UNLESS OTHERWISE NOTED, MINIMUM WELD SIZE MUST BE 3/16" CONTINUOUS FILLET WELDS 7. REFER TO THE ARCHITECTURAL, CIVIL, MECHANICAL, PLUMBING, AND ELECTRICAL DRAWINGS FOR ADDITIONAL STEEL (IF ANY) NOT SHOWN ON THE STRUCTURAL DRAWINGS. 8. UNLESS OTHERWISE NOTED, THE TOP OF ALL STEEL COLUMNS MUST HAVE A STEEL CAP PLATE. UNLESS OTHERWISE NOTED, MINIMUM CAP PLATE DIMENSIONS MUST MATCH COLUMN WIDTH AND DEPTH, AND MINIMUM THICKNESS MUST EQUAL COLUMN WEB THICKNESS, OR ½" MINIMUM. 9. ALL SHELF ANGLES, LINTEL ANGLES, AND OTHER ITEMS MARKED "GALVANIZED" MUST BE GALVANIZED IN ACCORDANCE TO ASTM A123 OR ASTM A153. GALVANIZE AFTER FABRICATION WHERE PRACTICAL. REPAIR DAMAGED GALVANIZED COATING USING ASTM A780 ZINC-RICH PAINT. 10. DO NOT APPLY PAINT OR PRIMER ON STRUCTURAL STEEL SURFACES RECEIVING SPRAYED FIRE-RESISTIVE MATERIALS. SEE THE ARCHITECTURAL DRAWINGS FOR EXTENTS OF SPRAYED FIRE RESISTIVE MATERIALS. CONCRETE MASONRY NOTES: 1. MASONRY CONSTRUCTION MUST COMPLY WITH THE MASONRY SOCIETY "BUILDING CODE FOR MASONRY STRUCTURES"(TMS 402-2013) AND "SPECIFICATION FOR MASONRY STRUCTURES"(TMS 602-2013). 2. CONCRETE MASONRY UNITS MUST CONFORM TO ASTM C90 AND BE MADE WITH LIGHTWEIGHT AGGREGATE. THE COMPRESSIVE STRENGTH OF MASONRY, F'm, EXPRESSED AS FORCE PER UNIT OF NET CROSS-SECTIONAL AREA, MUST BE 2,000 PSI AT 28 DAYS. 3. MORTAR MUST CONFORM TO ASTM C270, TYPE S. AGGREGATE FOR MORTAR MUST COMPLY WITH ASTM C144. 4. GROUT MUST CONFORM TO ASTM C476 AND MUST HAVE A MINIMUM 28 DAY COMPRESSIVE STRENGTH OF 2,500 PSI. SLUMP AT POINT OF PLACEMENT MUST BE BETWEEN 8 AND 11 INCHES. 5. ALL REINFORCING BARS MUST CONFORM TO ASTM A615, GRADE 60. SHOP FABRICATED BARS SHOWN TO BE BENT OR HOOKED. BARS MUST BE LAPPED AS FOLLOWS: #4-20", #5-30", #6-54", #7-63", #8-72", #9-81". 6. REBAR DOWELS MUST BE THE SAME SIZE AND SPACING AS VERTICAL REINFORCING FROM FOUNDATION. DOWELS MUST HAVE STANDARD ACI HOOKS. 7. PROVIDE BAR POSITIONERS FOR VERTICAL REINFORCING AT A MAXIMUM SPACING OF 200 BAR DIAMETERS, AT GROUT LIFT HEIGHTS, OR BAR SPLICE LOCATIONS, WHICHEVER IS LESS. 8. GROUTING MUST BE STOPPED 1-1/2" BELOW THE TOP OF A COURSE SO AS TO FORM A KEY AT THE POUR JOINT. 9. ALL BOLTS, ANCHORS, ETC. PLACED IN THE WALL, MUST BE GROUTED SOLID INTO POSITION. 10. GROUT ALL CELLS SOLID BELOW FINISHED FIRST FLOOR. 11. HORIZONTAL JOINT REINFORCING MUST BE STANDARD 9 GAGE LADDER TYPE IN CMU WALLS AT 16"ON-CENTER. JOINT REINFORCING MUST COMPLY WITH ASTM A951. 12. DISCONTINUE ALL HORIZONTAL REINFORCING AT CONTROL JOINTS EXCEPT FOR BOND BEAMS AT JOIST BEARING ELEVATIONS. HORIZONTAL BOND BEAMS MUST HAVE CONTINUOUS REINFORCING AS SHOWN IN THE SECTIONS AND DETAILS. NRW ENGINEERING Structural Consultants 748 Lord Dunmore Drive, Suite 101 Virginia Beach, VA 23464 Phone 757-474-0812 Fax 757-474-0910 NC license C-1393 <tr><td colspan="15"> MATERIALS KEYING LEGEND </td></tr><tr><td colspan="15"> GENERAL NOTES </td></tr><tr><td colspan="15"> KEY PLAN </td></tr><tr><td colspan="15"> SCO ID #23-27044-01A </td></tr><tr><td colspan="15"> NO REVISION DATE </td></tr><tr><td colspan="15"> SEAL NORTH CAROLINA PROFESSIONAL 027530 1-23-2025 ENGINEER KEVIN M. ROEBERSING John K. Farkas JKF ARCHITECTURE </td></tr><tr><td colspan="15"> 425 LYNDALE CT, SUITE F, GREENVILLE NC 27658 252-355-1048 </td></tr><tr><td colspan="15"> BEAUFORT COUNTY COMMUNITY COLLEGE INDUSTRIAL TRAINING CENTER AURORA, NC </td></tr><tr><td colspan="15"> DRAWING TITLE </td></tr><tr><td colspan="15"> GENERAL NOTES </td></tr><tr><td colspan="15"> SCALE 1/8" = 1'-0" DRAWN JSS CHECKED KMR DATE 1-6-2025 PROJECT NO. 2024-10 </td></tr><tr><td colspan="15"> DRAWING NO SO.1 </td></tr><tr><td colspan="15"> © COPYRIGHT, JKF ARCHITECTURE PC. JOHN K. FARKAS, AIA </td></tr>															MATERIALS KEYING LEGEND															GENERAL NOTES															KEY PLAN															SCO ID #23-27044-01A															NO REVISION DATE															SEAL NORTH CAROLINA PROFESSIONAL 027530 1-23-2025 ENGINEER KEVIN M. ROEBERSING John K. Farkas JKF ARCHITECTURE															425 LYNDALE CT, SUITE F, GREENVILLE NC 27658 252-355-1048															BEAUFORT COUNTY COMMUNITY COLLEGE INDUSTRIAL TRAINING CENTER AURORA, NC															DRAWING TITLE															GENERAL NOTES															SCALE 1/8" = 1'-0" DRAWN JSS CHECKED KMR DATE 1-6-2025 PROJECT NO. 2024-10															DRAWING NO SO.1															© COPYRIGHT, JKF ARCHITECTURE PC. JOHN K. FARKAS, AIA														
MATERIALS KEYING LEGEND																																																																																																																																																																																																																	
GENERAL NOTES																																																																																																																																																																																																																	
KEY PLAN																																																																																																																																																																																																																	
SCO ID #23-27044-01A																																																																																																																																																																																																																	
NO REVISION DATE																																																																																																																																																																																																																	
SEAL NORTH CAROLINA PROFESSIONAL 027530 1-23-2025 ENGINEER KEVIN M. ROEBERSING John K. Farkas JKF ARCHITECTURE																																																																																																																																																																																																																	
425 LYNDALE CT, SUITE F, GREENVILLE NC 27658 252-355-1048																																																																																																																																																																																																																	
BEAUFORT COUNTY COMMUNITY COLLEGE INDUSTRIAL TRAINING CENTER AURORA, NC																																																																																																																																																																																																																	
DRAWING TITLE																																																																																																																																																																																																																	
GENERAL NOTES																																																																																																																																																																																																																	
SCALE 1/8" = 1'-0" DRAWN JSS CHECKED KMR DATE 1-6-2025 PROJECT NO. 2024-10																																																																																																																																																																																																																	
DRAWING NO SO.1																																																																																																																																																																																																																	
© COPYRIGHT, JKF ARCHITECTURE PC. JOHN K. FARKAS, AIA																																																																																																																																																																																																																	

FOUNDATION NOTES:

- FOUNDATIONS FOR THIS STRUCTURE HAVE BEEN DESIGNED IN ACCORDANCE WITH THE RECOMMENDATIONS IN THE GEOTECHNICAL EXPLORATION REPORT, PREPARED BY TERRACON CONSULTANTS, INC DATED SEPTEMBER 3, 2024.
- PERFORM ALL EARTHWORK IN ACCORDANCE WITH THE SPECIFICATIONS.
- THE ENTIRE STRUCTURE SHALL BE FOUNDED ON VERY WELL COMPACTED STRUCTURAL FILL OR UNDISTURBED SOIL WITH A DESIGN BEARING PRESSURE OF 1500 P.S.F.
- PRIOR TO PLACING FOUNDATION CONCRETE, ALL FOUNDATION EXCAVATIONS SHALL BE INSPECTED BY THE GEOTECHNICAL ENGINEER TO VERIFY THE EXTENT OF ANY LOOSE, SOFT, OR UNSATISFACTORY SOIL AND TO VERIFY THE DESIGN BEARING PRESSURE. THE GEOTECHNICAL ENGINEER WILL PROVIDE DIRECTION FOR CORRECTIVE ACTION WHERE REQUIRED.
- DO NOT INSTALL FOUNDATION WORK UNTIL IT HAS BEEN COORDINATED WITH ADJACENT UNDERGROUND UTILITIES. FOOTINGS SHALL BE SLEEVED OR LOWERED WHERE REQUIRED. DO NOT INSTALL UTILITIES UNDER ISOLATED COLUMN FOOTINGS. INSTALL UTILITIES PERPENDICULAR TO WALL FOOTINGS. INSTALL SLEEVES TO ACCOMMODATE PLUMBING OR UTILITY LINES PRIOR TO POURING FOOTING CONCRETE OR LOWER FOOTINGS SO PLUMBING OR UTILITY LINES OCCUR OVER THE TOP OF THE FOOTINGS. REFER TO TYPICAL DETAILS.
- DO NOT PUT IN UNBALANCED BACKFILL AGAINST FOUNDATION WALLS UNLESS WALLS ARE SECURELY BRACED AGAINST OVERTURNING.
- FROST LINE DEPTH IS 12" BELOW GRADE. BOTTOM OF EXTERIOR FOUNDATIONS SHALL BEAR A MINIMUM OF 12" BELOW FINAL GRADE. LOWER FOOTINGS AS REQUIRED TO MAINTAIN COVERAGE.

CAST IN PLACE CONCRETE NOTES:

- CAST IN PLACE CONCRETE MUST COMPLY WITH THE AMERICAN CONCRETE INSTITUTE (ACI- 318-14), COMMENTARY, (ACI-318R-14), AND THE SPECIFICATIONS FOR STRUCTURAL CONCRETE (ACI 301).
- DETAILING OF ALL CONCRETE STEEL REINFORCEMENT MUST BE IN ACCORDANCE WITH THE MANUAL OF STANDARD PRACTICE FOR DETAILING REINFORCED CONCRETE STRUCTURES (ACI-315).
- ALL CONCRETE MUST BE NORMAL WEIGHT, UNLESS OTHERWISE NOTED, CONCRETE HAVING A MINIMUM COMPRESSIVE STRENGTH AT 28 DAYS AS FOLLOWS:

A) INTERIOR SLAB ON GRADE 4,000 PSI

B) FOUNDATIONS 3,000 PSI

C) CONCRETE NOT OTHERWISE NOTED 4,500 PSI

D) CONCRETE EXPOSED TO WEATHER MUST BE AIR ENTRAINED.
- ALL REINFORCING MUST BE AS FOLLOWS:

A) REINFORCING BARS – ASTM A-615, GRADE 60

B) WELDED REINFORCING BARS – ASTM A706, GRADE 60

C) WELDED WIRE REINFORCEMENT – ASTM A-1064 FLAT SHEET TYPE, ROLL TYPE NOT ACCEPTABLE.
- WELDED WIRE REINFORCEMENT MUST BE PROPERLY SUPPORTED PRIOR TO PLACING CONCRETE. HOOKING OF FABRIC IS NOT PERMITTED.
- UNLESS OTHERWISE NOTED, REINFORCING STEEL MARKED CONTINUOUS (CONT.) MUST BE LAPPED PER THE REINFORCING LAP SCHEDULE.
- HOLD ALL REINFORCING STEEL SECURELY IN PLACE TO PREVENT DISLOCATION DURING THE POURING OPERATION. SUPPORT SLAB REINFORCING BARS ON HIGH CHAIRS AND BAR SPACERS OF SUITABLE DESIGN, OR CONCRETE BLOCKS HAVING THE SAME MINIMUM COMPRESSIVE STRENGTH OF THE CONCRETE SLAB.
- DO NOT PLACE CONCRETE UNTIL ALL EMBEDDED WORK HAS BEEN INSTALLED, TESTED AND INSPECTED.
- EXCEPT AS OTHERWISE SHOWN MINIMUM PROTECTION (CONCRETE COVER) FOR REINFORCING STEEL MUST BE AS FOLLOWS:

CONCRETE SURFACES CAST AGAINST SOIL: 3"

CONCRETE SURFACES EXPOSED TO EARTH OR WEATHER: 2"

INTERIOR CONCRETE SURFACES: 1" FOR SLABS

OPEN WEB STEEL JOIST NOTES:

- OPEN-WEB STEEL JOIST MUST COMPLY WITH THE STANDARD SPECIFICATION FOR OPEN WEB JOISTS OF THE STEEL JOIST INSTITUTE (SJI), LATEST EDITION.
- OPEN-WEB STEEL JOIST MUST HAVE A MINIMUM BEARING LENGTH AS FOLLOWS:

ON STEEL – "k" SERIES – 4"

ON MASONRY – AS DETAILED
- WELD ALL STEEL JOISTS WHEREVER THEY BEAR ON STRUCTURAL STEEL MEMBERS, IN ACCORDANCE WITH THE S.J.I AND THE A.I.S.C SPECIFICATIONS
- PREPARE AND SUBMIT SHOP DRAWINGS INDICATING THE JOIST LAYOUT, SPECIAL CONNECTIONS, AND ACCESSORIES. INCLUDE MARK, NUMBER, TYPE, LOCATION, AND SPACING OF JOISTS AND BRIDGING.
- THE JOIST MANUFACTURER IS RESPONSIBLE FOR CONTINUOUS JOIST BRIDGING LINES SATISFYING THE REQUIREMENTS OF THE SJI SPECIFICATION FOR THE TOP AND BOTTOM CHORDS OF ALL STEEL JOISTS, AS WELL AS ANY ADDITIONAL BRIDGING / BRACING SHOWN ON THE DRAWINGS OR REQUIRED FOR JOISTS SUBJECTED TO NET UPLIFT OF OTHER SPECIAL LOADS. PROVIDE JOIST BRIDGING REQUIRED AT CHANGES OF JOIST DEPTHS AND AT ENDS OF ALL BRIDGING LINES UNLESS SUCH ENDS ARE PROPERLY ANCHORED INTO THE INTERSECTING INTERIOR OR END WALLS.
- REFER TO DESIGN CRITERIA NOTES FOR NET UPLIFT LOAD ON ROOF JOISTS. A SINGLE LINE OF BOTTOM CHORD BRIDGING MUST BE PROVIDED NEAR THE FIRST BOTTOM CHORD PANEL POINTS WHENEVER UPLIFT LOADS OCCUR.
- INSTALL JOIST BRIDGING AND CONNECTIONS COMPLETELY PRIOR TO PLACING ANY CONSTRUCTION LOADS ON THE JOISTS. CONSTRUCTION LOADING MUST NOT EXCEED THE JOIST DESIGN LOAD.
- REINFORCE CONCENTRATED LOADS EXCEEDING 100 POUNDS AND NOT LOCATED AT JOIST PANEL POINTS PER THE TYPICAL DETAIL.
- DO NOT APPLY PAINT OR PRIMER ON STEEL JOISTS OR ACCESSORIES RECEIVING SPRAYED FIRE- RECEIVING MATERIALS. SEE THE ARCHITECTURAL DRAWINGS FOR EXTENTS OF SPRAYED FIRE RESISTIVE MATERIALS.

STRUCTURAL STEEL NOTES:

- STRUCTURAL STEEL MUST COMPLY WITH THE FOURTEENTH EDITION OF THE AMERICAN INSTITUTE OF STEEL CONSTRUCTION (AISC 360-10) "SPECIFICATION FOR STRUCTURAL STEEL BUILDINGS".
- STRUCTURAL STEEL MUST BE NEW, CLEAN, AND STRAIGHT, AND CONFORM TO THE FOLLOWING:

A)STEEL W- AND WT SHAPES – ASTM A992, GRADE 50

B)RECTANGULAR AND SQUARE HSS SHAPES – ASTM A500, GRADE C

C)ANCHOR RODS – ASTM F1554, GRADE 36

D)HIGH STRENGTH BOLTS – ASTM A325

E)ALL OTHER STEEL SHAPES – ASTM A36, UNLESS OTHERWISE NOTED
- UNLESS OTHERWISE NOTED, ALL CONNECTIONS MUST BE STANDARD SHEAR BEAM CONNECTIONS. THE FABRICATOR IS RESPONSIBLE FOR DESIGNING ALL CONNECTIONS. WHERE REACTIONS ARE NOT INDICATED ON PLAN, CONNECTIONS MUST BE DESIGNED FOR ½ OF THE TOTAL ALLOWABLE UNIFORM LOAD FOR Laterally Supported Beams Given in Part 3 of the "STEEL CONSTRUCTION MANUAL" 14TH EDITION. CONNECTION DETAILS MUST BE IN ACCORDANCE WITH AISC STANDARDS.
- UNLESS OTHERWISE NOTED WELD ALL SHOP CONNECTIONS AND BOLT ALL FIELD CONNECTIONS. THE FABRICATOR IS RESPONSIBLE FOR THE DESIGN OF ALL CONNECTIONS. REFER TO SPECIFICATIONS.
- SHOW ALL HOLES REQUIRED IN STRUCTURAL STEEL MEMBERS FOR PIPING ON THE SHOP DRAWINGS AND MAKE THEM IN THE SHOP. DO NOT CUT HOLES IN THE FIELD WITHOUT THE APPROVAL OF THE REGISTERED DESIGN PROFESSIONAL OF RECORD.
- WELDING MUST COMPLY WITH THE "STRUCTURAL WELDING CODE – STEEL" (AWS D1.1). WELD ELECTRODES MUST BE E70XX.UNLESS OTHERWISE NOTED, MINIMUM WELD SIZE MUST BE 3/16" CONTINUOUS FILLET WELDS
- REFER TO THE ARCHITECTURAL, CIVIL, MECHANICAL, PLUMBING, AND ELECTRICAL DRAWINGS FOR ADDITIONAL STEEL (IF ANY) NOT SHOWN ON THE STRUCTURAL DRAWINGS.
- UNLESS OTHERWISE NOTED, THE TOP OF ALL STEEL COLUMNS MUST HAVE A STEEL CAP PLATE. UNLESS OTHERWISE NOTED, MINIMUM CAP PLATE DIMENSIONS MUST MATCH COLUMN WIDTH AND DEPTH, AND MINIMUM THICKNESS MUST EQUAL COLUMN WEB THICKNESS, OR ½" MINIMUM.
- ALL SHELF ANGLES, LINTEL ANGLES, AND OTHER ITEMS MARKED "GALVANIZED" MUST BE GALVANIZED IN ACCORDANCE TO ASTM A123 OR ASTM A153. GALVANIZE AFTER FABRICATION WHERE PRACTICAL. REPAIR DAMAGED GALVANIZED COATING USING ASTM A780 ZINC-RICH PAINT.
- DO NOT APPLY PAINT OR PRIMER ON STRUCTURAL STEEL SURFACES RECEIVING SPRAYED FIRE-RESISTIVE MATERIALS. SEE THE ARCHITECTURAL DRAWINGS FOR EXTENTS OF SPRAYED FIRE RESISTIVE MATERIALS.

CONCRETE MASONRY NOTES:

- MASONRY CONSTRUCTION MUST COMPLY WITH THE MASONRY SOCIETY "BUILDING CODE FOR MASONRY STRUCTURES" (TMS 402-2013) AND "SPECIFICATION FOR MASONRY STRUCTURES"(TMS 602-2013).
- CONCRETE MASONRY UNITS MUST CONFORM TO ASTM C90 AND BE MADE WITH LIGHTWEIGHT AGGREGATE. THE COMPRESSIVE STRENGTH OF MASONRY, F'm, EXPRESSED AS FORCE PER UNIT OF NET CROSS-SECTIONAL AREA, MUST BE 2,000 PSI AT 28 DAYS.
- MORTAR MUST CONFORM TO ASTM C270, TYPE S. AGGREGATE FOR MORTAR MUST COMPLY WITH ASTM C144.
- GROUT MUST CONFORM TO ASTM C476 AND MUST HAVE A MINIMUM 28 DAY COMPRESSIVE STRENGTH OF 2,500 PSI. SLUMP AT POINT OF PLACEMENT MUST BE BETWEEN 8 AND 11 INCHES.
- ALL REINFORCING BARS MUST CONFORM TO ASTM A615, GRADE 60. SHOP FABRICATED BARS SHOWN TO BE BENT OR HOOKED. BARS MUST BE LAPPED AS FOLLOWS: #4-20", #5-30", #6-54", #7-63", #8-72", #9-81".
- REBAR DOWELS MUST BE THE SAME SIZE AND SPACING AS VERTICAL REINFORCING FROM FOUNDATION. DOWELS MUST HAVE STANDARD ACI HOOKS.
- PROVIDE BAR POSITIONERS FOR VERTICAL REINFORCING AT A MAXIMUM SPACING OF 200 BAR DIAMETERS, AT GROUT LIFT HEIGHTS, OR BAR SPLICE LOCATIONS, WHICHEVER IS LESS.
- GROUTING MUST BE STOPPED 1-1/2" BELOW THE TOP OF A COURSE SO AS TO FORM A KEY AT THE POUR JOINT.
- ALL BOLTS, ANCHORS, ETC. PLACED IN THE WALL, MUST BE GROUTED SOLID INTO POSITION.
- GROUT ALL CELLS SOLID BELOW FINISHED FIRST FLOOR.
- HORIZONTAL JOINT REINFORCING MUST BE STANDARD 9 GAGE LADDER TYPE IN CMU WALLS AT 16" ON-CENTER. JOINT REINFORCING MUST COMPLY WITH ASTM A951.
- DISCONTINUE ALL HORIZONTAL REINFORCING AT CONTROL JOINTS EXCEPT FOR BOND BEAMS AT JOIST BEARING ELEVATIONS. HORIZONTAL BOND BEAMS MUST HAVE CONTINUOUS REINFORCING AS SHOWN IN THE SECTIONS AND DETAILS.

MATERIALS KEYING LEGEND

GENERAL NOTES

KEY PLAN

SCO ID #23-27044-01A

NO

REVISION

DATE

SEAL

NORTH CAROLINA
PROFESSIONAL
ENGINEER
1-23-2025
022830
KEVIN M. ROOMS
ENGINEERING

J K F

ARCHITECTURE

623 LYND DALE CT., SUITE F, GREENVILLE, NC 27858 252-355-1048

BEAUFORT COUNTY
COMMUNITY COLLEGE
INDUSTRIAL TRAINING CENTER
AURORA, NC

GENERAL NOTES

SCALE	DRAWING NO
DRAWN	SOI
CHECKED	
DATE	
PROJECT NO.	

GENERAL NOTES:

STEEL DECK NOTES:

1. STEEL DECK MUST CONFORM TO THE LATEST EDITION OF THE AMERICAN IRON AND STEEL INSTITUTE (AISI), "SPECIFICATION FOR THE DESIGN OF COLD-FORMED STEEL STRUCTURAL STEEL MEMBERS" AND THE STEEL DECK INSTITUTE (SDI) "DESIGN MANUAL FOR COMPOSITE DECKS, FORM DECKS AND ROOF DECKS".
2. ATTACH ROOF DECK TO SUPPORTS WITH 5/8" DIAMETER ARC SPOT WELDS IN ALL RIBS WHERE SIDELAPS OCCUR AND AT 12 INCHES ON CENTER ALONG SUPPORTS. FASTEN ADJACENT DECK UNITS ALONG SIDELAPS WITH #10 SELF TAPPING HEX HEAD SCREWS AT 1/3 POINTS BETWEEN SUPPORTS. FASTEN EDGESTMOST DECK PANEL TO SUPPORTS WITH 5/8" DIAMETER ARC SPOT WELDS AT SAME SPACING AS SIDELAP FASTENERS.
3. AS AN ALTERNATIVE TO ARC SPOT WELDS, MECHANICAL FASTENERS MAY BE USED. INSTALL POWDER-ACTUATED FASTENERS OR SCREW FASTENERS IN ACCORDANCE WITH THE MANUFACTURER'S RECOMMENDATIONS. PROVIDE EQUIVALENT LOAD VALUES SHOWING THE MECHANICAL FASTENERS MEET OR EXCEED THE PROVIDED LOAD CRITERIA. FASTENERS MUST BE SDI LISTED FOR DIAPHRAGM DESIGN AND WIND UPLIFT, AND FM LISTED FOR FIRE RESISTANCE AND WIND UPLIFT. FASTENERS MUST BE RECOGNIZED BY ICC-ES FOR DIAPHRAGM SHEAR STRENGTH IN ACCORDANCE WITH THE LATEST VERSION OF ICC-ES AC43.
4. SPAN DECK PERPENDICULAR TO SUPPORTS, CONTINUOUS OVER A MINIMUM OF THREE SPANS. PROVIDE FULL SHEETS ON EDGES OF DIAPHRAGMS.
5. WELDING MUST BE IN ACCORDANCE WITH AWS D1.3, "STRUCTURAL WELDING CODE - SHEET STEEL". FIELD WELDS MUST BE WIRE BRUSHED AND PAINTED WITH RICH ZINC PAINT.
6. PROVIDE SUPPORTS ON ALL SIDES OF DECK OPENINGS MEASURING GREATER THAN 12" ON ANY SIDE OF OPENING. SPAN SUPPORTS BETWEEN ADJACENT BEAMS OR JOISTS ON TWO SIDES. UNLESS OTHERWISE NOTED USE L4X4X1/4. COORDINATE OPENING SIZES, LOCATIONS, AND DETAILS WITH ARCHITECTURAL, MECHANICAL, PLUMBING, AND ELECTRICAL DRAWINGS.
7. DO NOT HANG OR SUPPORT ANY PERMANENT LOADS FROM METAL ROOF DECK.
8. DURING STEEL DECK ERECTION DISTRIBUTE CONSTRUCTION LOADS TO PREVENT DAMAGE TO DECK. CONCENTRATED CONSTRUCTION LOADS OF 150 POUNDS OR LESS DISTRIBUTED OVER A 1'-0" WIDE SECTION OF DECK MUST NOT REQUIRE ANY FURTHER DISTRIBUTION. USE WORKING PLATFORMS FOR CONCENTRATED LOADS OF OVER 150 POUNDS, SUCH THAT THE RESULTING UNIFORM CONSTRUCTION LOAD ON THE DECK DOES NOT EXDEED 50 PSF.

STRUCTURAL DELEGATED DESIGNS AND DEFERRED SUBMITTALS NOTES:

1. STRUCTURAL DELEGATED DESIGNS AND SUBSEQUENT DEFERRED SUBMITTALS ARE FOR ELEMENTS, PARTS, OR PORTIONS OF THE OVERALL STRUCTURAL SYSTEM THAT ARE INDICATED OR REFERRED TO ON THESE DRAWINGS AND THAT ARE CRITICAL TO THE PERFORMANCE OF THE OVERALL STRUCTURAL SYSTEMS. DESIGN CRITERIA HAS BEEN PROVIDED FOR THESES ITEMS IN THE STRUCTURAL NOTES, PLANS, AND DETAILS.
2. STRUCTURAL DEFERRED SUBMITTALS ARE COMPLETE PACKAGES MUST BE SUBMITTED FOR REVIEW THAT INCLUDE DRAWINGS AND CALCULATIONS WITH SIGNED SEALS FOR ALL DELEGATED DESIGN ITEMS AND THEIR CONNECTIONS. DEFERRED SUBMITTALS SHALL BEAR THE STAMP AND SIGNATURE OF THE DESIGN PROFESSIONAL RESPONSIBLE FOR THEIR DESIGN.
3. THE STRUCTURAL ENGINEER OF RECORD WILL REVIEW STRUCTURAL DEFERRED SUBMITTALS TO VERIFY DESIGN CRITERIA IS COMPLIANT WITH THE APPROVED CONSTRUCTIONS DOCUMENTS.
4. DESIGN RESPONSIBILITY FOR THE FOLLOWING ENGINEERED SYSTEMS AND COMPONENT PARTS IS DELEGATED TO A QUALIFIED DELEGATED PROFESSIONAL ENGINEER REGISTERED IN THE STATE OF NORTH CAROLINA SELECTED BY THE CONTRACTOR. STRUCTURAL DELEGATED DESIGN ITEMS REQUIRING DEFERRED SUBMITTALS INCLUDE, BUT ARE NOT LIMITED TO:

4.1. STRUCTURAL STEEL CONNECTIONS EXCEPT FOR PRIMARY LATERAL FORCE RESISTING SYSTEM CONNECTIONS, COLUMN BASE PLATE CONNECTIONS AND CONNECTIONS WHERE SPECIFIC WELD SIZES AND LENGTHS, BOLT SIZES AND QUANTITY, PLATE SIZES AND OTHER CONNECTION COMPONENTS ARE NOTED. WHERE SECTIONS AND DETAILS DO NOT SHOW SPECIFIC CONNECTION COMPONENT INFORMATION, CONNECTIONS SHOWN ARE SCHEMATIC REPRESENTATIONS AND REQUIRE DESIGN BY THE CONTRACTOR. DESIGN AND DETAIL DELEGATED ENGINEERED SYSTEM CONNECTIONS TO RESIST THE LOADS INDICATED.

4.2. OPEN WEB STEEL JOISTS, BRIDGING, BRACING CONNECTIONS AND RELATED COMPONENTS.

4.3. ALUMINUM CANOPY STRUCTURE.

DESIGN CRITERIA NOTES:

1. LOADS USED IN THE DESIGN OF THIS STRUCTURE ARE AS FOLLOWS:
2. BUILDING RISK CATEGORY: II
3. UNIFORM LIVE LOADS:

SLAB ON GRADE150 PSF

ROOF20 PSF
4. ROOF SNOW LOADS:

GROUND SNOW LOAD Pg = 10 PSF

SNOW EXPOSURE FACTOR Ce = 1.0

SNOW LOAD IMPORTANCE FACTOR I =1.0

THERMAL FACTOR Ct=1.0

MINIMUM UNIFORM ROOF DESIGN SNOW LOAD: Pm = 10 PS
5. WIND LOADS:

ULTIMATE WIND SPEED = 131 MPH

NOMINAL WIND SPEED (ASD) = 101.5 MPH

EXPOSURE CATEGORY (MAIN WINDFORCE-RESISTING SYSTEM): C

EXPOSURE CATEGORY (COMPONENTS AND CLADDING): C

INTERNAL PRESSURE COEFFICIENT: +/- 0.18 (ENCLOSED)
6. SEISMIC LOADS:

RISK CATEGORY II

IMPORTANCE FACTOR I = 1.0

Ss = .113g

S1 = .058g

SOIL SITE CLASS D

Sds = 0.12

Sd1 = 0.093

SEISMIC DESIGN CATEGORY B

BASIC SEISMIC STRUCTURAL SYSTEM: ORDINARY MASONRY SHEAR WALLS

RESPONSE MODIFICATION FACTOR, R=2.0

SEISMIC RESPONSE COEFFICIENT, Cs = 0.060


DESIGN BASE SHEAR: 0.060W

ANALYSIS PROCEDURE USED: EQUIVALENT LATERAL FORCE

NOTE: WIND LOADS CONTROL LATERAL DESIGN.

COMPONENTS AND CLADDING ULTIMATE WIND PRESSURES														
AREA (SF)	ROOF ZONES										WALL ZONES			
	1		2		2'		3		3'		4		5	
A<10	+16.3	-43.6	+16.3	-50.4	+16.3	-60.6	+16.3	-67.4	+16.3	-94.6	+36.7	-39.8	+36.7	-49.0
A>100	+16.0	-43.6	+16.0	-47.0	+16.0	-57.2	+16.0	-47.0	+16.0	-60.6	+31.3	-34.4	+31.3	-38.2

FOR ASD LOADING, MULTIPLY BY 0.60
INTERPOLATE BETWEEN AREAS INDICATED.
END ZONE A = 6.0 FEET.
REFER TO SKETCH BELOW FOR ZONE DEFINITIONS.
FOR OVERHANG PRESSURES MULTIPLY ZONES 1 & 2 BY 1.0 AND ZONE 3 BY 1.15.

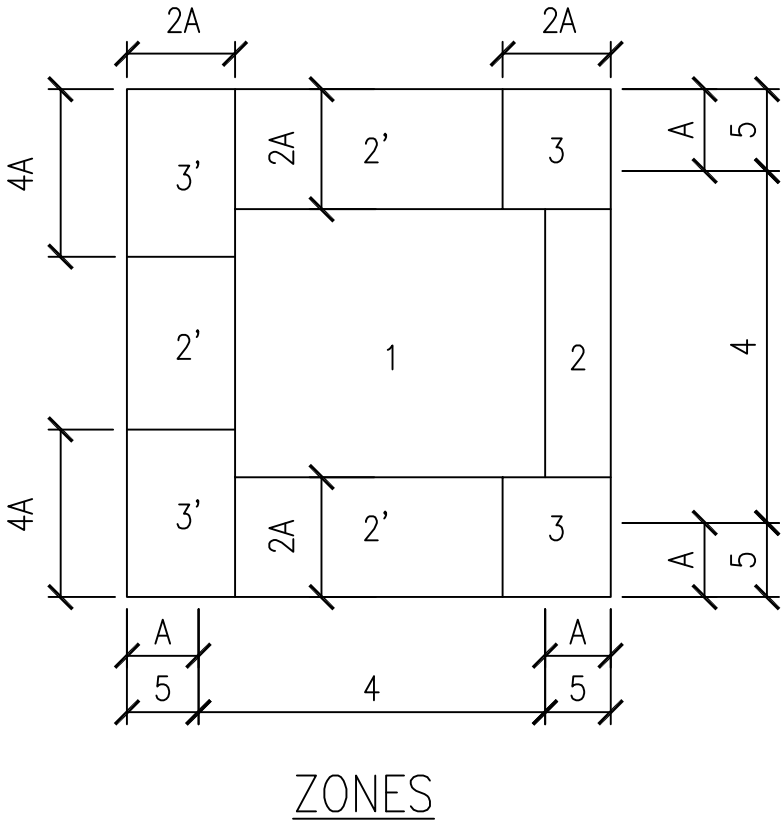

ABBREVIATIONS LIST

ARCH.	ARCHITECT
BLDG.	BUILDING
BOTT.	BOTTOM
C.M.U.	CONCRETE MASONRY UNIT
COL.	COLUMN
CONC.	CONCRETE
CONN.	CONNECTION
CONT.	CONTINUOUS
DIAG.	DIAGONAL
DIAM.	DIAMETER
DWGS.	DRAWINGS
E.F.	EACH FACE
ELEV.	ELEVATION
EXP.	EXPANSION
FOUND.	FOUNDATION
F.O.B.	FACE OF BRICK
EXIST.	FOOTING
GALV.	GALVANIZED
HORIZ.	HORIZONTAL
H.S.	HIGH STRENGTH
INSUL.	INSULATION
JT.	JOINT
L.L.V.	LONG LEG VERTICAL
MECH.	MECHANICAL
OPP.	OPPOSITE
PEMB	PRE-ENGINEERED METAL BLDG
P.J.F	PREMOLDED JOINT FILLER
P./I.	POUNDS PER SQUARE INCH
P./F.	POUNDS PER SQUARE FOOT
REF.	REFERENCE
REINF.	REINFORCING
REQ'D.	REQUIRED
SCHED.	SCHEDULE
SECT.	SECTION
SHT.	SHEET
SPECS.	SPECIFICATIONS
STL.	STEEL
T.O.	TOP OF
TYP.	TYPICAL
U./N.	UNLESS OTHERWISE NOTED
VERT.	VERTICAL
W.W.F.	WELDED WIRE FABRIC
W/O	WITH OUT
C.L.	CENTER LINE
PL.	PLATE
O.C.	ON CENTER
Ø	DIAMETER
L	ANGLE

CONCRETE REINFORCEMENT
LAP SPICE SCHEDULE

BAR SIZE	LAP LENGTH	
	TOP BARS	BOTTOM BARS
#4	38"	29"
#5	47"	36"
#6	56"	43"
#7	81"	63"
#8	93"	72"
#9	105"	81"

NRW ENGINEERING
Structural Consultants
748 Lord Dumore Drive, Suite 101
Virginia Beach, VA 23464
Phone 757-474-0812
Fax 757-474-0910
NC license C-13993

MATERIALS KEYING LEGEND

GENERAL NOTES

KEY PLAN

SCO ID #23-27044-01A

NO	REVISION	DATE
----	----------	------

SEAL

NORTH CAROLINA
PROFESSIONAL
ENGINEER
2023-2025
TEVIN M. ROOMSDING

J K F

ARCHITECTURE


623 LYNNDALE CT., SUITE F, GREENVILLE, NC 27858 252-355-1048

BEAUFORT COUNTY
COMMUNITY COLLEGE
INDUSTRIAL TRAINING CENTER
AURORA, NC

GENERAL NOTES AND
ABBREVIATIONS

SCALE	1/8" = 1'-0"	SO.2
DRAWN	JSS	
CHECKED	KMR	
DATE	1-6-2025	
PROJECT NO.	2024-10	

© COPYRIGHT, JKF ARCHITECTURE PC, JOHN K. FARKAS, AIA

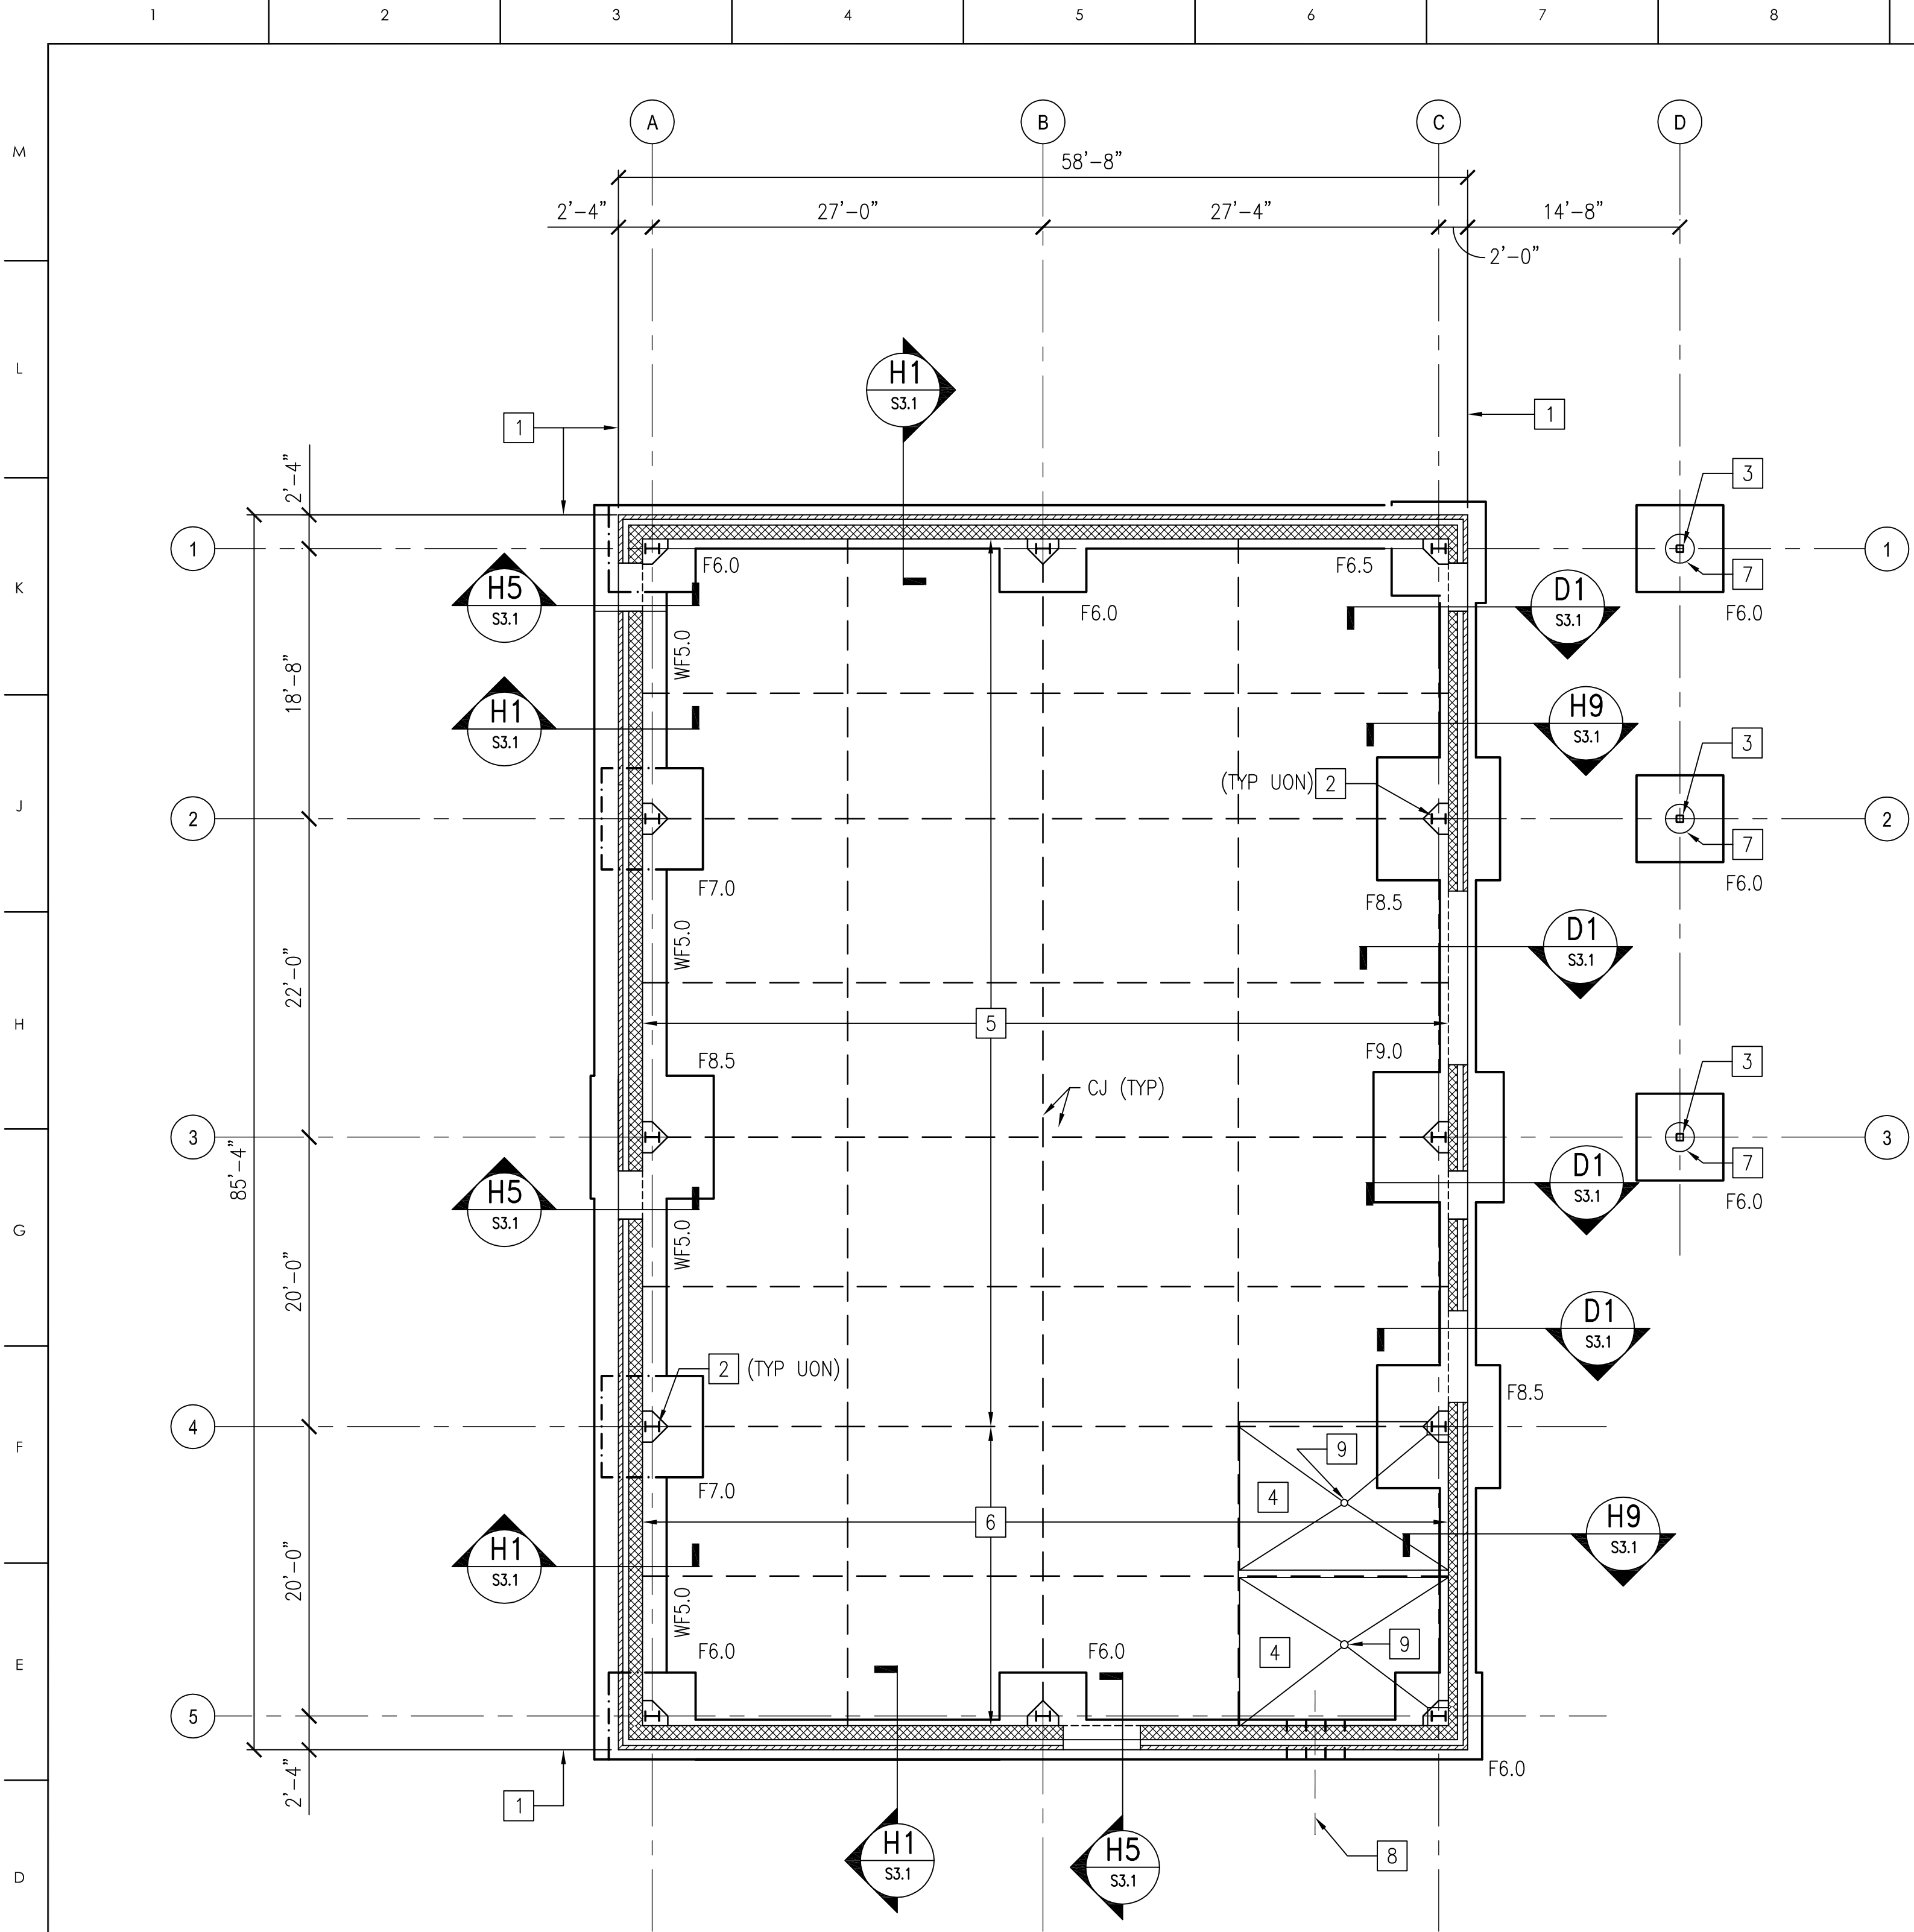

FOUNDATION PLAN

SCALE: 1/8" = 1'-0"

COLUMN FOOTING SCHEDULE						
MARK	DIMENSIONS			REINFORCING		NOTES
	W	L	T	TOP BARS	BOTTOM BARS	
F6.0	6'-0"	6'-0"	1'-4"	(7) #5	(7) #5	EACH WAY
F6.5	6'-6"	6'-6"	1'-4"	(8) #5	(8) #5	EACH WAY
F7.0	7'-0"	7'-0"	1'-4"	(8) #5	(8) #5	EACH WAY
F8.5	8'-6"	8'-6"	1'-4"	(10) #5	(10) #5	EACH WAY
F9.0	9'-0"	9'-0"	1'-4"	(11) #5	(11) #5	EACH WAY

WALL FOOTING SCHEDULE							
MARK	DIMENSIONS		TOP AND BOTTOM REINFORCING				NOTES
	WIDTH	DEPTH	LONGITUDINAL		TRANSVERSE		
			QUANTITY	SIZE	SIZE	SPACING	
WF3.0	3'-0"	1'-0"	3	#5	5	1'-4"	
WF5.0	5'-0"	1'-0"	5	#5	5	1'-4"	

 
PLAN NOTES

- DATUM FOR ALL ELEVATIONS GIVEN ON THIS PLAN IS FINISHED FIRST FLOOR = 0'-0". REFER TO ARCHITECTURAL SITE PLAN FOR ACTUAL ELEVATION.
- TOP OF CONCRETE SLAB IS AT +0'-0" UNLESS OTHERWISE INDICATED THUS: X'-X" ON PLAN.
- REFER TO SECTIONS FOR WALL FOOTING SIZES. REFER TO COLUMN FOOTING SCHEDULE FOR FOOTING SIZE AND REINFORCING.
- UNLESS OTHERWISE NOTED PROVIDE A CONCRETE SLAB ON GRADE ON 15 MIL VAPOR RETARDER OVER 4" NCDOT NO. 57 STONE MATERIAL. REFER TO SLAB KEY NOTES FOR SLAB THICKNESS AND REINFORCING.
- UNLESS OTHERWISE NOTED THUS (-X'-X") ON PLAN, TOP OF ALL WALL AND COLUMN FOOTINGS SHALL BE AT ELEVATION (-1'-4"), INDICATING DISTANCE BELOW DATUM.
- WALL FOOTINGS ARE WF3.0 UNLESS OTHERWISE NOTED. FOR COLUMN FOOTING SCHEDULE AND WALL FOOTING SCHEDULE, REFER TO SHEET S1.1. WALL FOOTINGS ARE INDICATED (WFX.X) AND COLUMN FOOTINGS ARE INDICATED (FX.X).
- STEP FOOTING AS NECESSARY AT PLUMBING AND BELOW GRADE UTILITY LINES. REFER TO TYPICAL STEPPED FOOTING DETAIL ON SHEET S5.1. REFER TO MECHANICAL/PLUMBING DRAWINGS FOR EXACT LOCATIONS.
- THE SYMBOL CJ INDICATES SLAB CONTROL JOINT, AND MAY BE A CONSTRUCTION JOINT OR SAWED JOINT. REFER TO TYPICAL SLAB CONTROL JOINT DETAILS ON SHEET S5.1.
- GENERAL NOTES ARE LOCATED ON SHEET S0.1 & S0.2 AND TYPICAL DETAILS ARE LOCATED ON SHEETS S5.1 AND S5.2.

KEY PLAN NOTES

- EXTERIOR FACE OF BRICK VENEER.
- W12x40 COLUMN. PROVIDE BASE PLATE TYPE BP1. REFER TO BASE PLATE DETAILS ON SHEET S5.1
- HSS 6x6x⁵/₁₆ COLUMN. PROVIDE BASE PLATE TYPE BP2. REFER TO BASE PLATE DETAILS ON SHEET S5.1.
- 2" RECESSED SLAB. COORDINATE EXACT LOCATION WITH ARCHITECTURAL DRAWINGS.
- PROVIDE 6" CONCRETE SLAB ON GRADE REINFORCED W/ 6x6-W2.9xW2.9 WELDED WIRE FABRIC LOCATED 1¹/₂" FROM TOP OF SLAB.
- PROVIDE 4" CONCRETE SLAB ON GRADE REINFORCED W/ 6x6-W2.9xW2.9 WELDED WIRE FABRIC LOCATED 1" FROM TOP OF SLAB.
- CONCRETE COLUMN WRAP, REFER TO DETAIL C6/S3.1
- FOR PLUMBING LINE REFER TO PLUMBING DRAWINGS. STEP FOOTING BELOW PLUMBING LINE. REFER TO DETAIL ON S5.1.
- FLOOR DRAIN, REFER TO PLUMBING DRAWINGS.

GRAPHIC SCALES:



NRW ENGINEERING
Structural Consultants
748 Lord Dumfries Drive, Suite 101
Virginia Beach, VA 23464
Phone 757-474-0812
Fax 757-474-0910
NC license C-1393

MATERIALS KEYING LEGEND

GENERAL NOTES

KEY PLAN

SCO ID #23-27044-01A

NO REVISION DATE

SEAL



JKF
ARCHITECTURE

623 LYNDALE CT., SUITE F, GREENVILLE, NC 27858 252-355-1048

BEAUFORT COUNTY
COMMUNITY COLLEGE
INDUSTRIAL TRAINING CENTER
AURORA, NC

DRAWING TITLE

FOUNDATION PLAN

SCALE

1/8" = 1'-0"

DRAWN

JSS

CHECKED

KMR


DATE

1-6-2025

PROJECT NO.


2024-10

© COPYRIGHT, JKF ARCHITECTURE PC, JOHN K. FARKAS, AIA

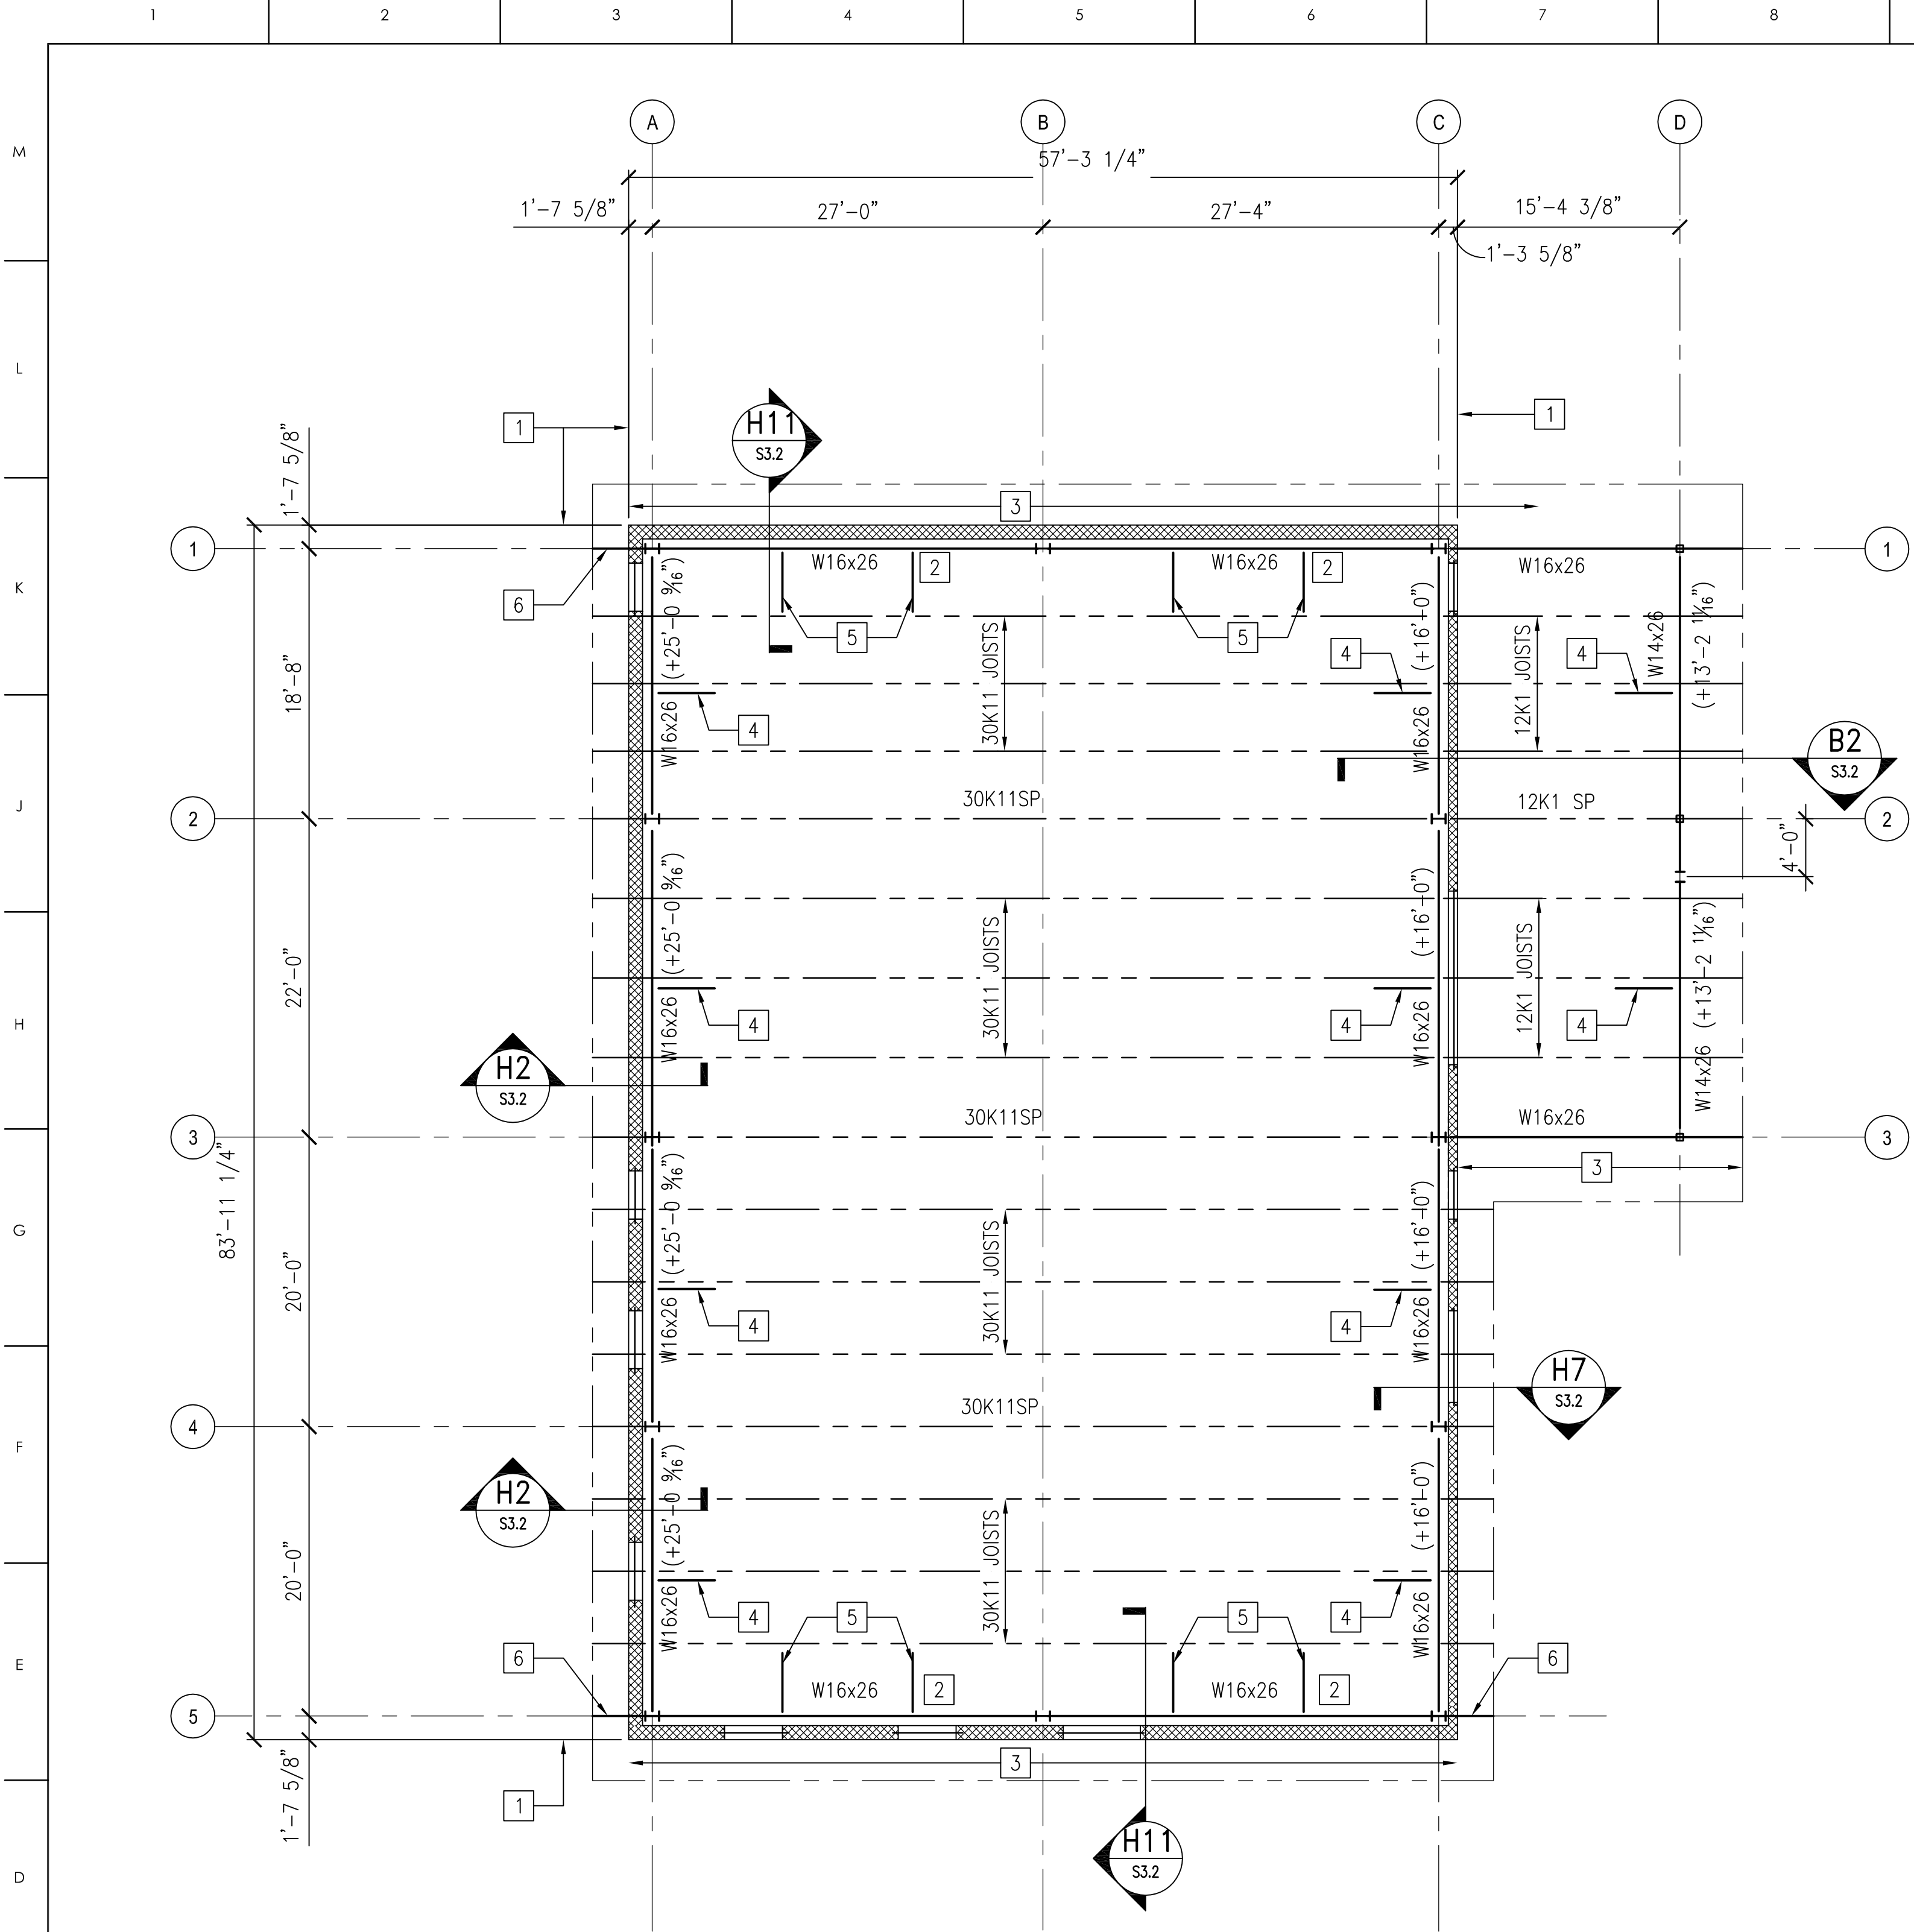


ROOF FRAMING PLAN

SCALE: 1/8" = 1'-0"

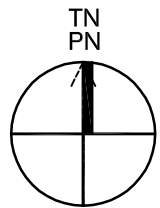


PLAN NOTES

 - DATUM FOR ALL ELEVATIONS GIVEN ON THIS PLAN IS FINISHED FIRST FLOOR ELEVATION = 0'-0". REFER TO ARCHITECTURAL SITE PLAN FOR ACTUAL ELEVATION.
- TOP OF STEEL BEAM ELEVATIONS INDICATED THUS (+_____) ON PLAN.
- UNLESS OTHERWISE NOTED, THE ROOF CONSTRUCTION IS 1-1/2" DEEP, 20 GA. TYPE 'B' GALVANIZED STEEL ROOF DECK SUPPORTED ON OPEN WEB STEEL JOISTS BEARING ON STEEL BEAMS.
- GENERAL NOTES ARE LOCATED ON SHEET S0.1 & S0.2 AND TYPICAL DETAILS ARE LOCATED ON SHEETS S5.1 AND S5.2.
- LINTELS ARE SHOWN THUS () ON PLAN. REFER TO LINTELS DETAILS ON SHEET S5.2.
- JOIST EXTENDED ENDS MUST BE DESIGNED TO SAFELY SUPPORT A UNIFORM LOAD OF 300 PLF OR 200 LB LOAD LOCATED AT THE END OF JOIST EXTENSION.

KEY PLAN NOTES

- EXTERIOR FACE OF CMU WALL.
- SLOPE OF OF BEAM TO MATCH TOP OF ADJACENT JOIST.
- OUTLOOKERS HSS 3 1/2 X 1 1/2 X 1/4 (LSH) SPACED AT 12" O/C (MAX) WITHIN 12 FEET OF BUILDING CORNERS AND 18" O/C (MAX) AT ALL OTHER LOCATIONS. REFER SECTION H11/S3.2.
- L2"x2"x3/8" BOTTOM FLANGE BEAM BRACING, REFER TO TYPICAL BOTTOM FLANGE BRACING DETAIL ON S5.2 FOR ADDITIONAL INFORMATION.
- L2"x2"x3/8" BOTTOM FLANGE BEAM BRACING, REFER TO SECTION H11/S3.2 FOR ADDITIONAL INFORMATION.
- FOR BEAM EXTENSION REFER TO DETAIL ON SHEET S5.2.

 GRAPHIC SCALES:



NRW ENGINEERING
Structural Consultants
748 Lord Dumfries Drive, Suite 101
Virginia Beach, VA 23464
Phone 757-474-0812
Fax 757-474-0910
NC license C-13993

MATERIALS KEYING LEGEND

GENERAL NOTES

KEY PLAN

SCO ID #23-27044-01A

NO	REVISION	DATE
----	----------	------

SEAL



JKF
ARCHITECTURE

625 LYNDALE CT., SUITE F, GREENVILLE, NC 27858 252-355-1048

BEAUFORT COUNTY
COMMUNITY COLLEGE
INDUSTRIAL TRAINING CENTER
AURORA, NC

DRAWING TITLE

ROOF FRAMING PLAN

SCALE

1/8" = 1'-0"

DRAWN

JSS

CHECKED

KMR

DATE


1-6-2025

PROJECT NO.

2024-10

SI.2

© COPYRIGHT, JKF ARCHITECTURE PC, JOHN K. FARKAS, AIA

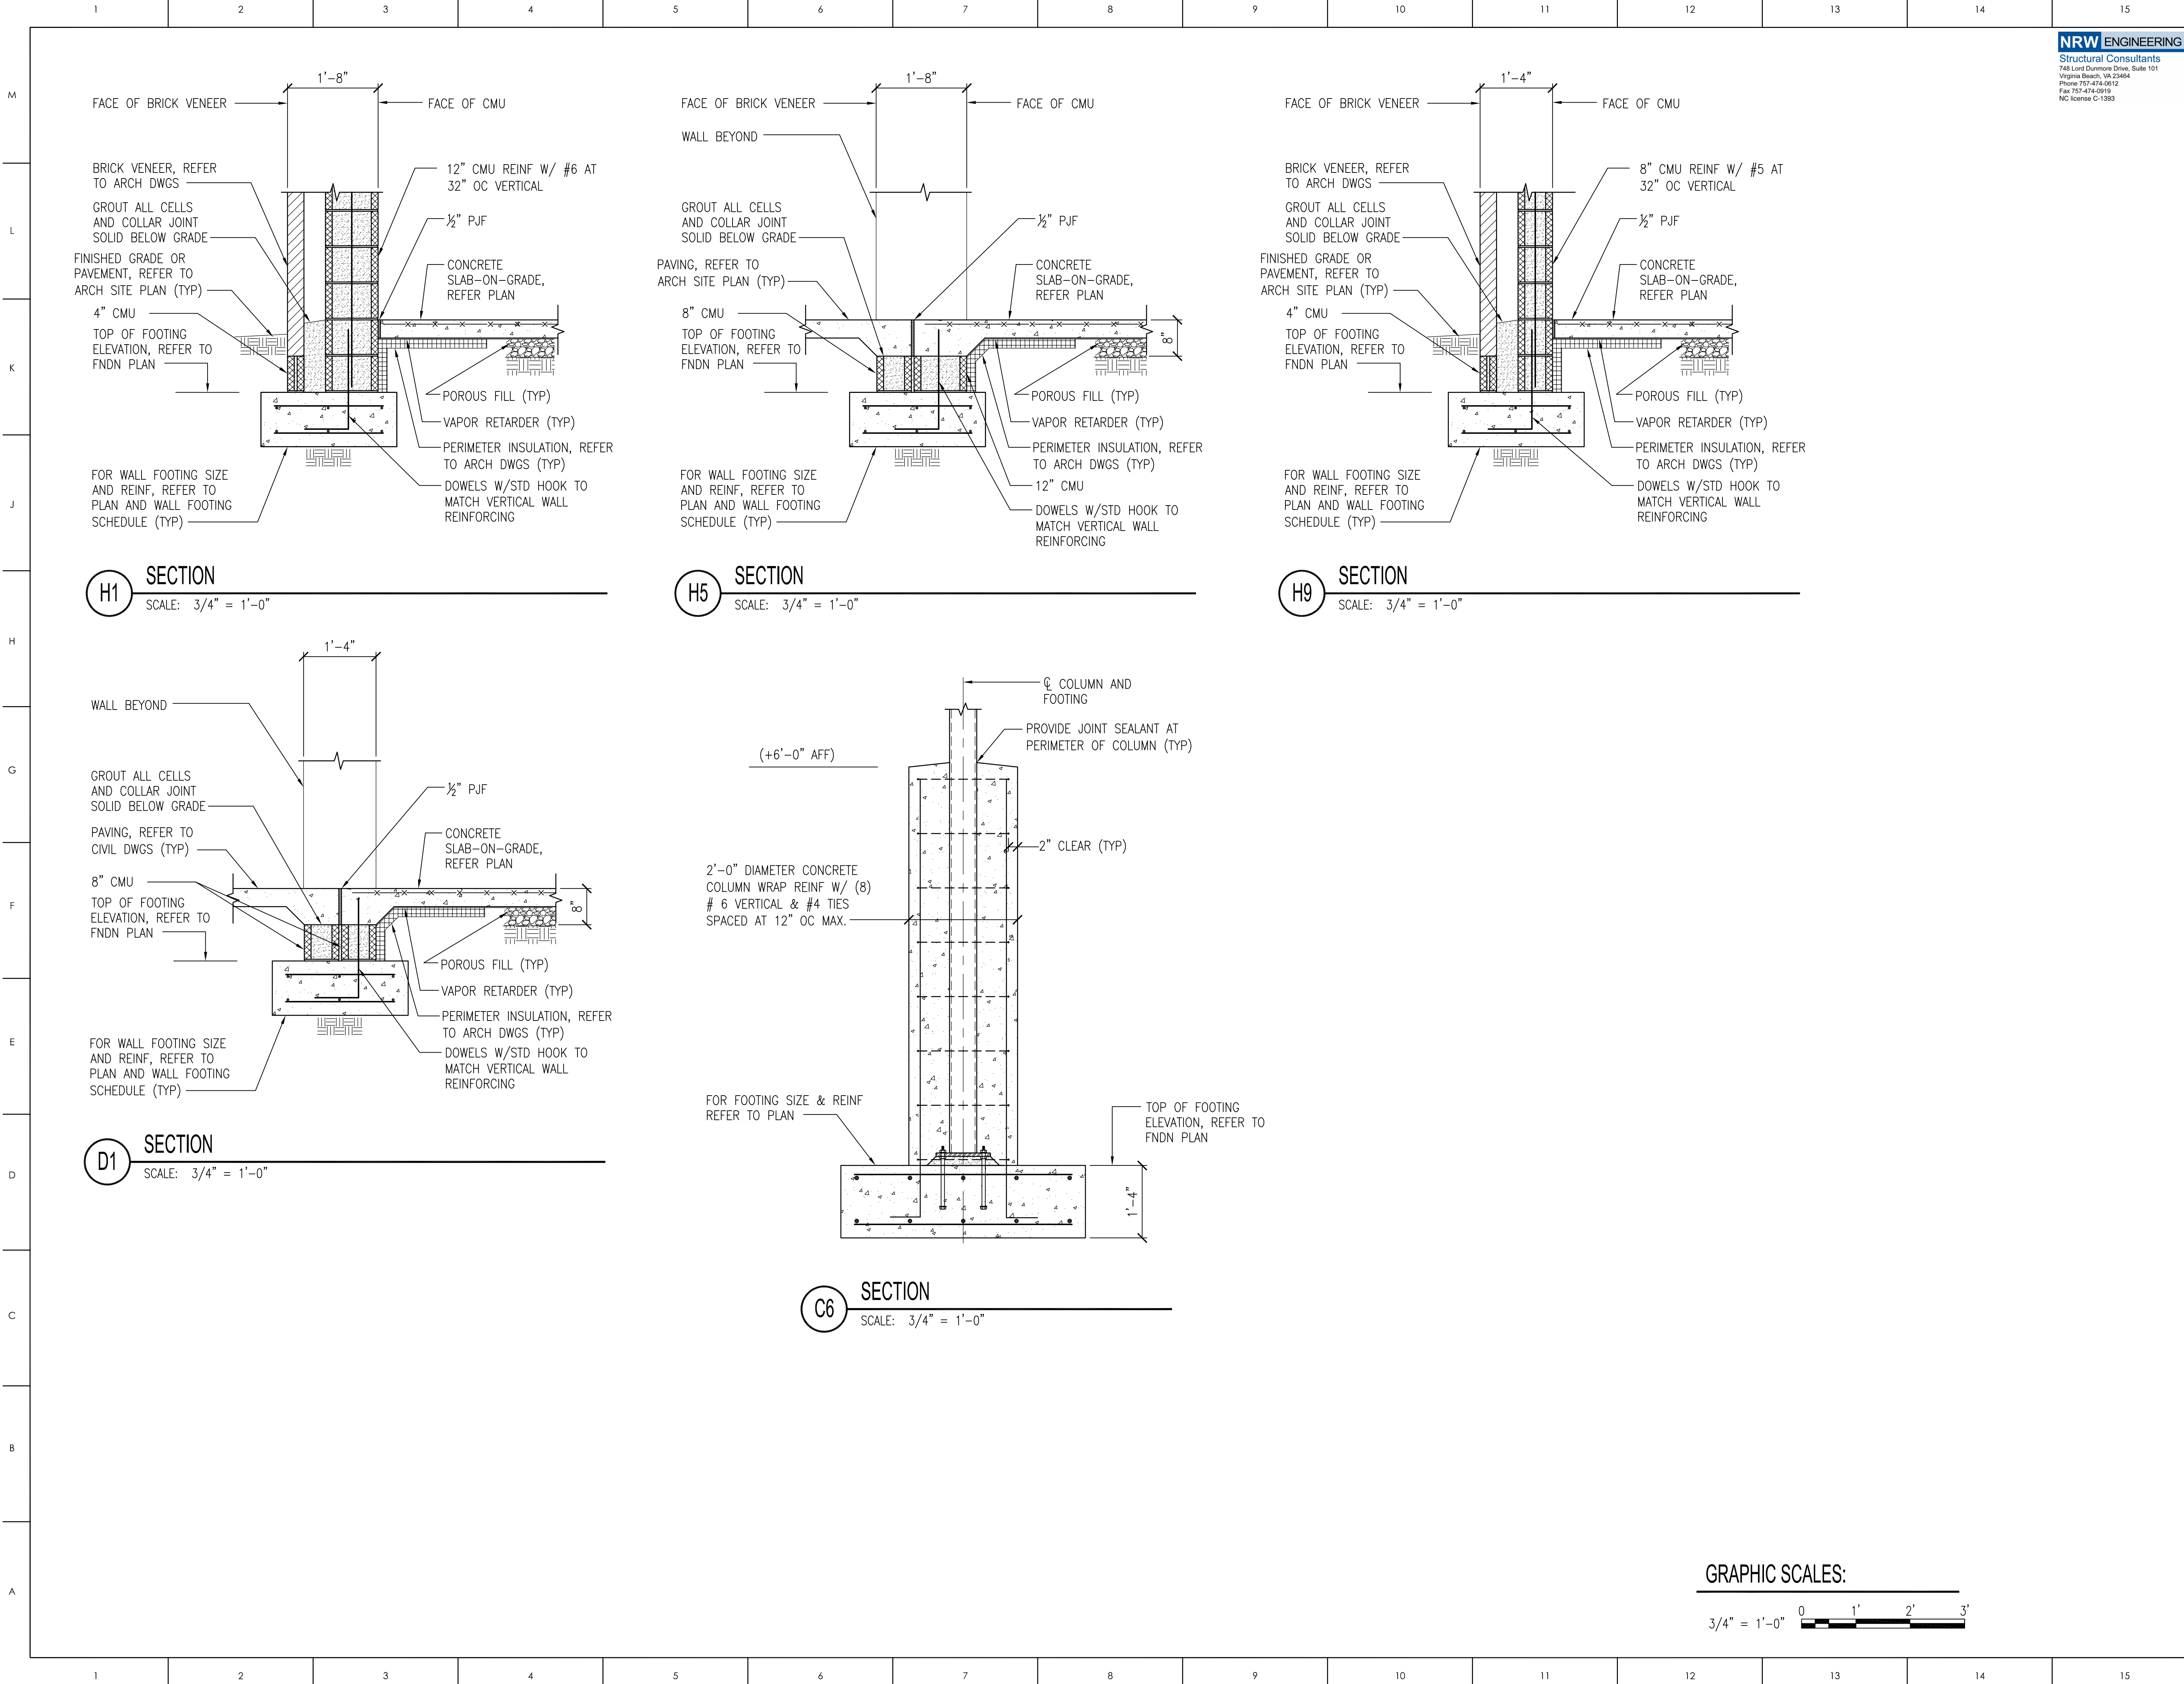

NRW ENGINEERING
Structural Consultants
748 Lord Dismore Drive, Suite 101
Virginia Beach, VA 23464
Phone 757-474-0812
Fax 757-474-0910
NC license C-13993

MATERIALS KEYING LEGEND


GENERAL NOTES

KEY PLAN

SCO ID #23-27044-01A

NO	REVISION	DATE

SCAL

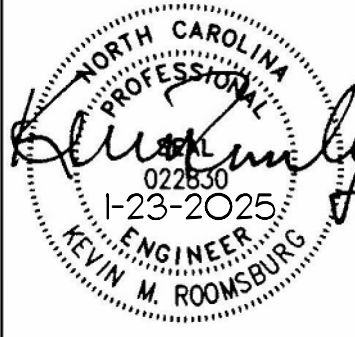

J K F
ARCHITECTURE

625 LYNDALE CT., SUITE F, GREENVILLE, NC 27858 252-355-1048

BEAUFORT COUNTY
COMMUNITY COLLEGE
INDUSTRIAL TRAINING CENTER
AURORA, NC

DRAWING TITLE

SECTIONS

SCALE 1/8" = 1'-0"

DRAWN JSS

CHECKED KMR


DATE 1-6-2025

PROJECT NO. 2024-10

S3.1

GRAPHIC SCALES:



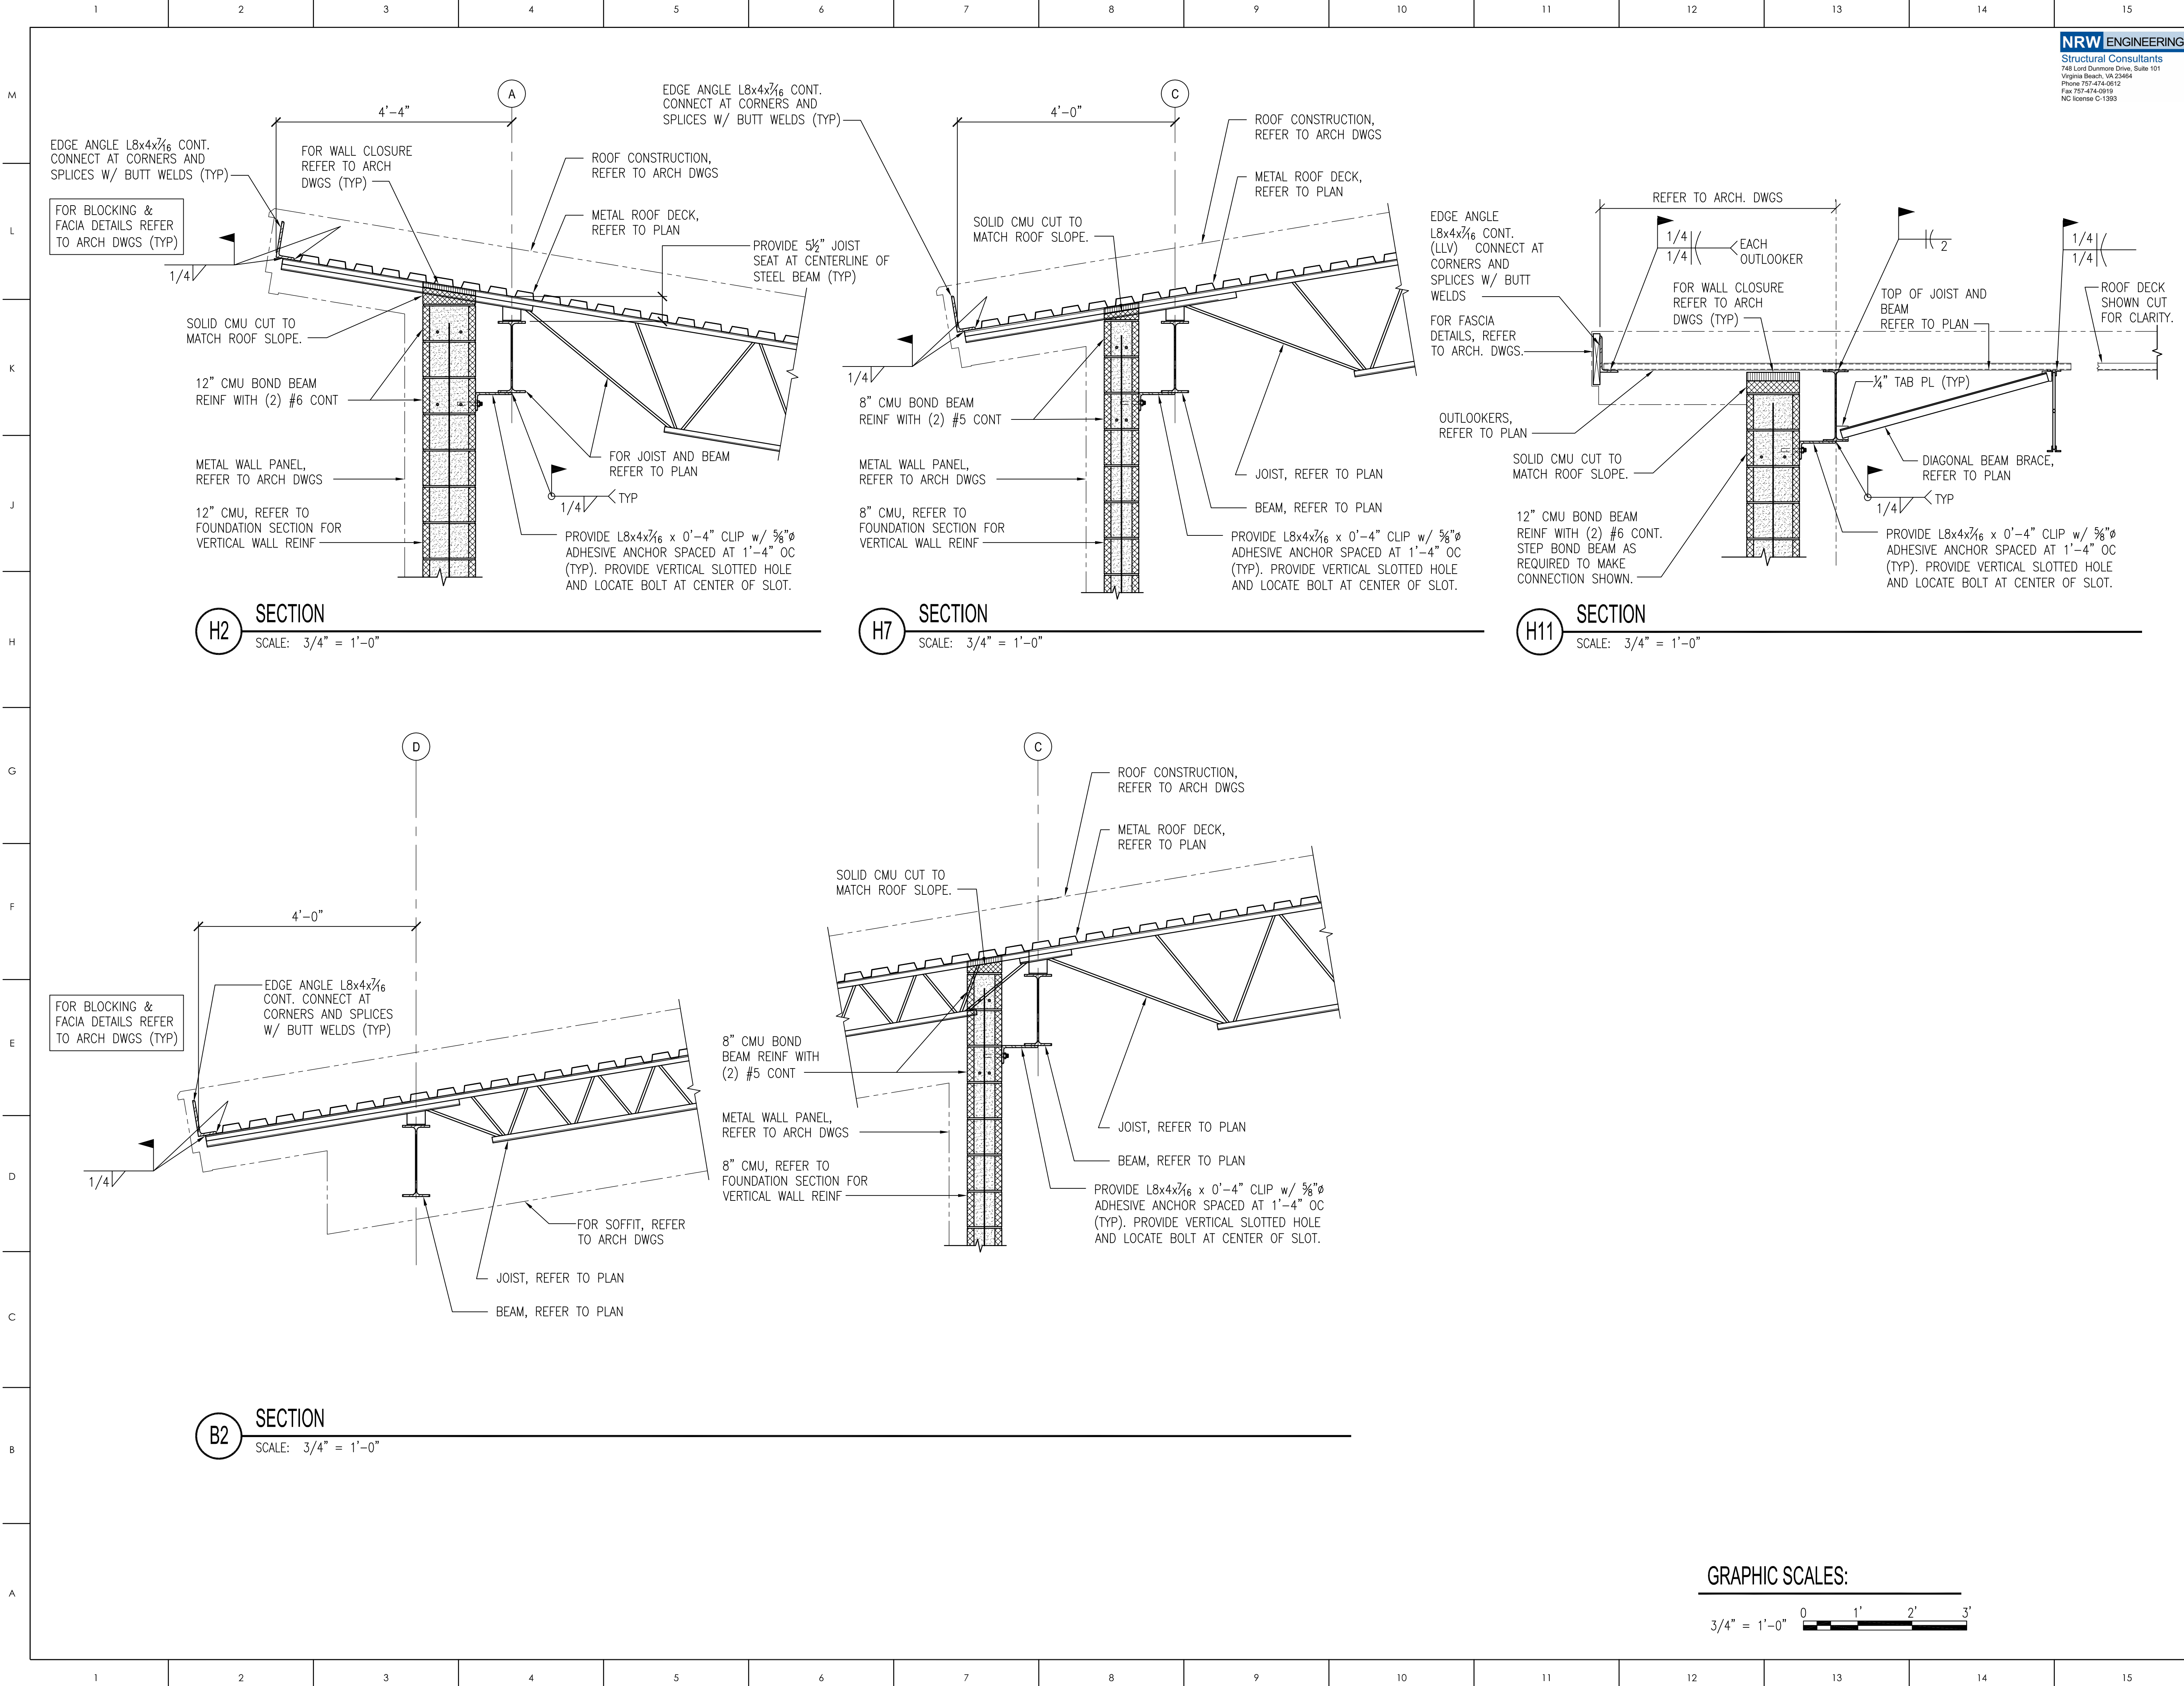

NRW ENGINEERING

Structural Consultants

748 Lord Dumfries Drive, Suite 101

Virginia Beach, VA 23464

Phone 757-474-0812

Fax 757-474-0910

NC license C-1393

MATERIALS KEYING LEGEND

GENERAL NOTES

KEY PLAN

SCO ID #23-27044-01A

NO

REVISION

DATE

SEAL

NORTH CAROLINA

PROFESSIONAL

022830

1-23-2025

ENGINEER

JOHN M. ROOMSBURG

J K F

ARCHITECTURE

625 LYNDALE CT., SUITE F, GREENVILLE, NC 27858 252-355-1048

BEAUFORT COUNTY

COMMUNITY COLLEGE

INDUSTRIAL TRAINING CENTER

AURORA, NC

DRAWING TITLE

SECTIONS

SCALE

1/8" = 1'-0"

DRAWN

JSS

CHECKED

KMR

DATE

1-6-2025


PROJECT NO.

2024-10

DRAWING NO.

S3.2

© COPYRIGHT, JKF ARCHITECTURE PC, JOHN K. FARKAS, AIA

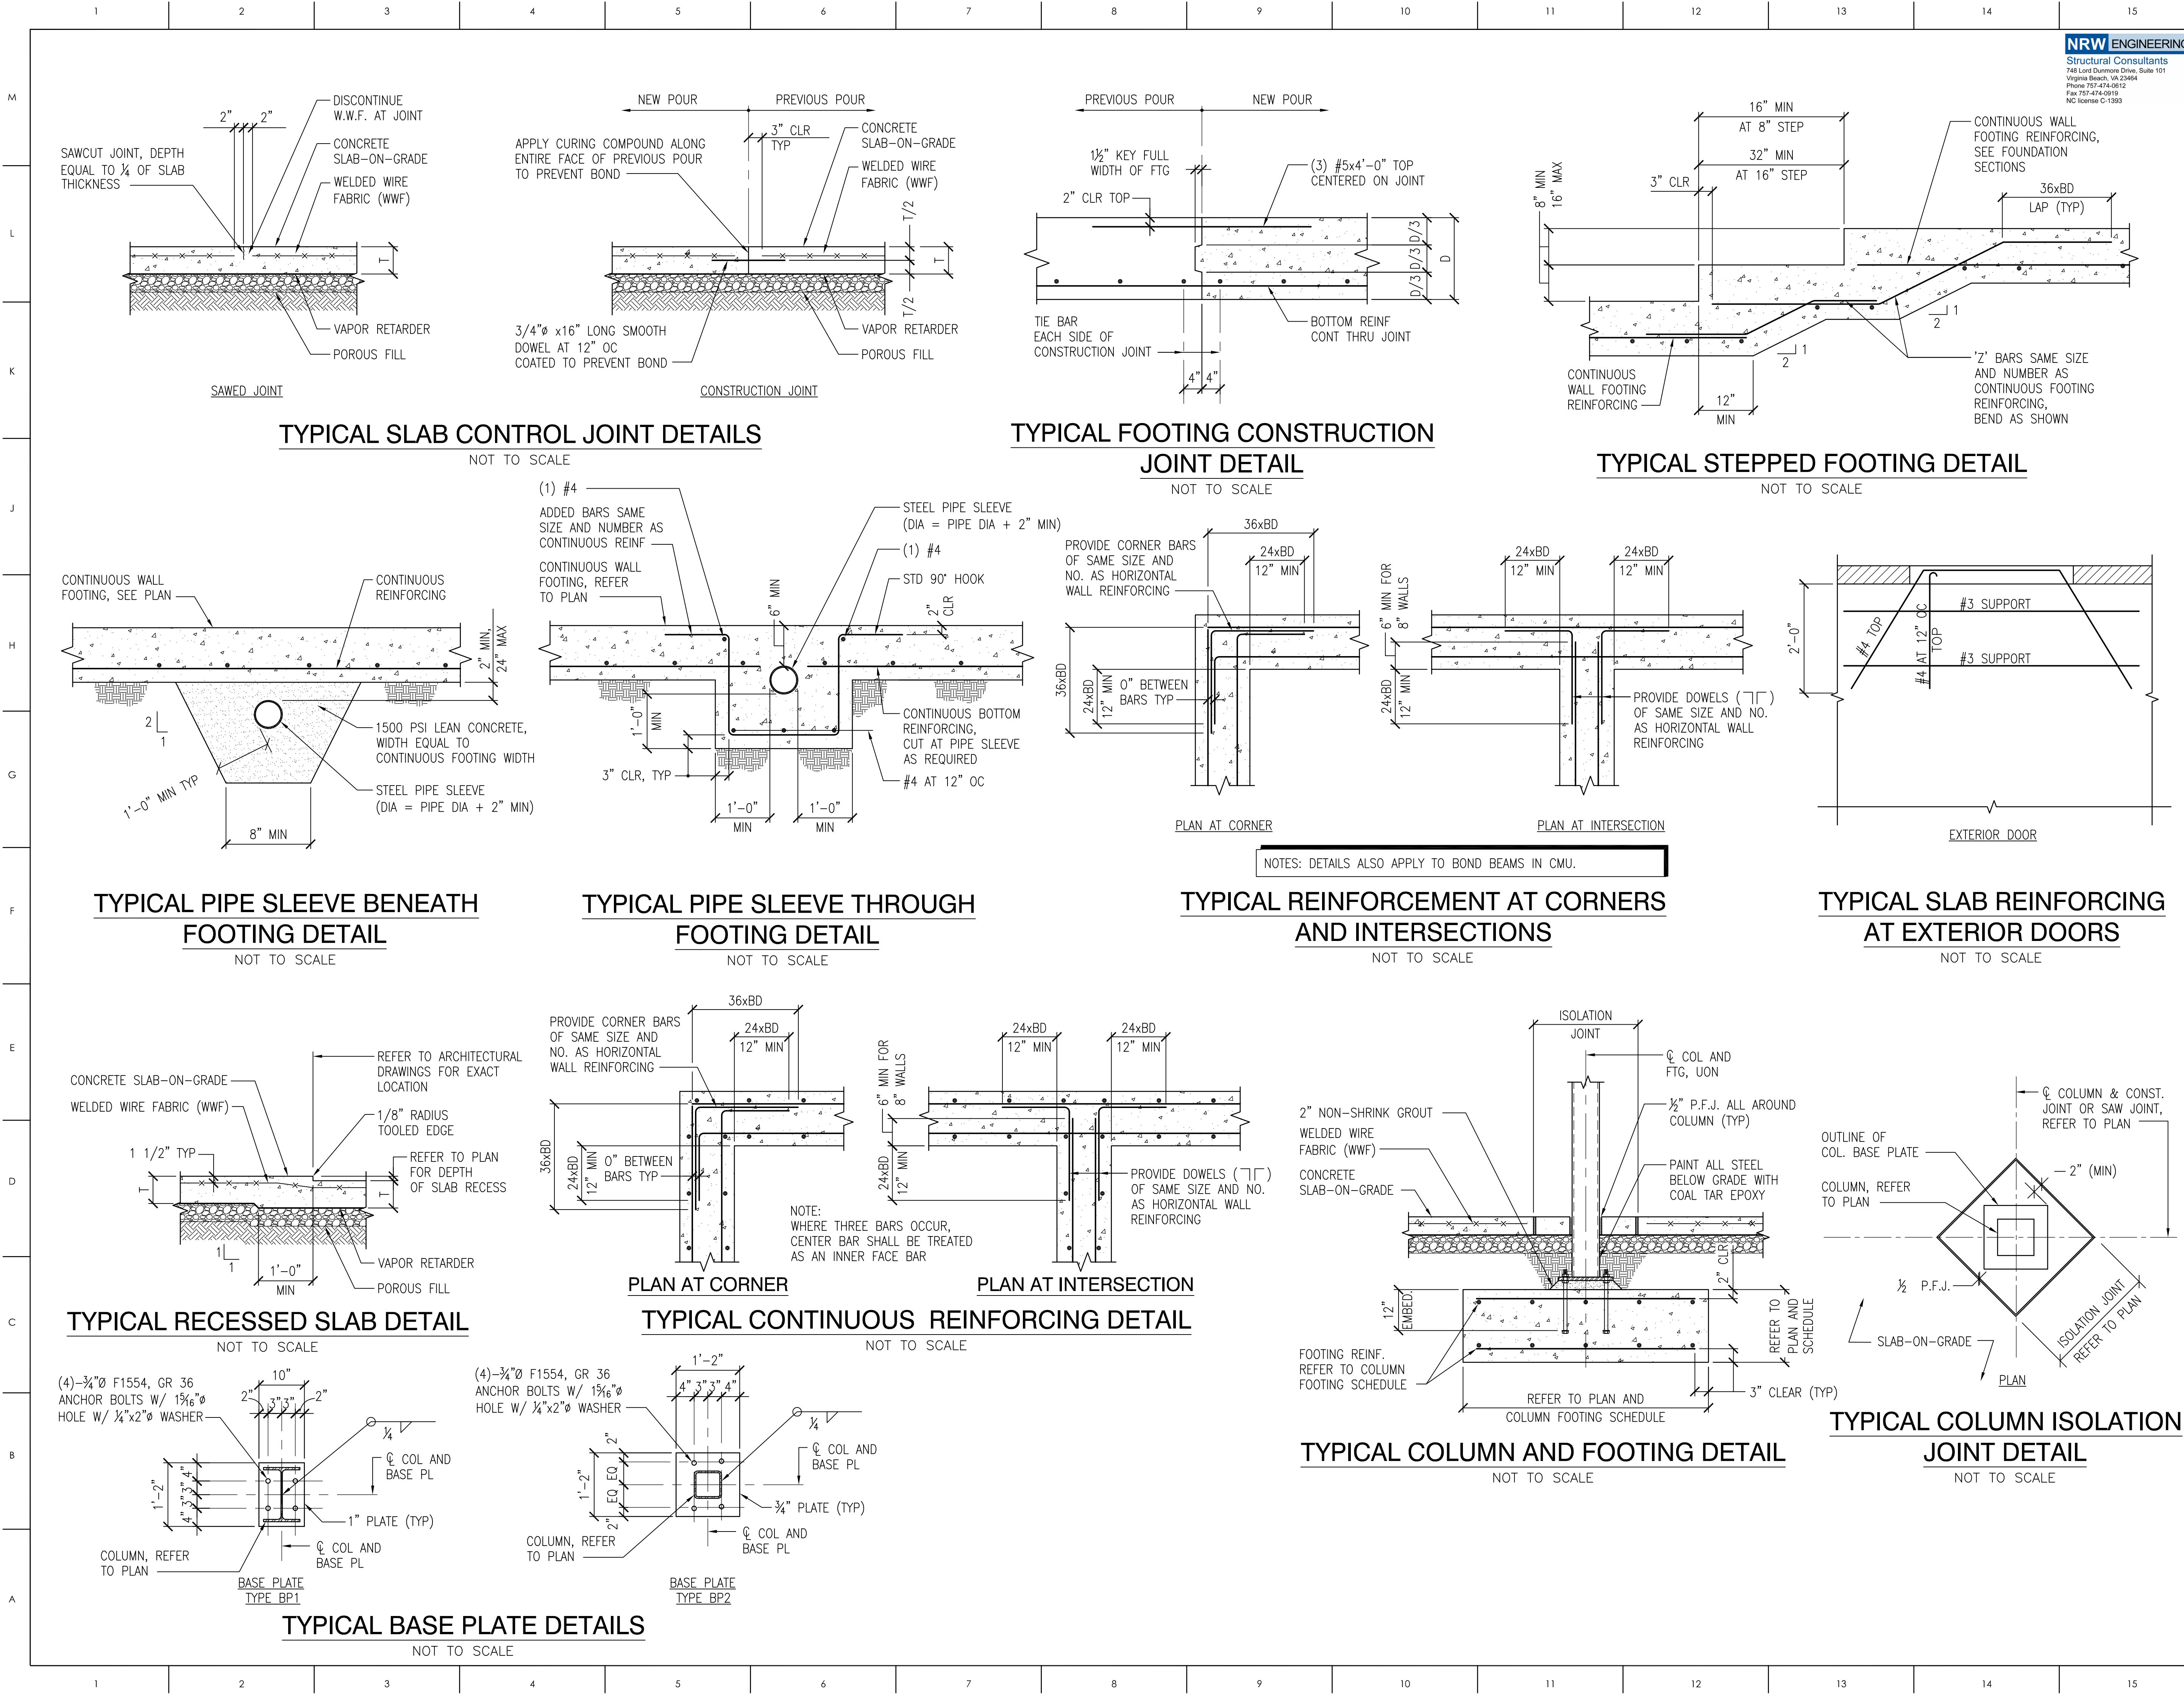

NRW ENGINEERING

Structural Consultants
748 Lord Dumore Drive, Suite 101
Virginia Beach, VA 23464
Phone 757-474-0812
Fax 757-474-0910
NC license C-1393

MATERIALS KEYING LEGEND

GENERAL NOTES

KEY PLAN

SCO ID #23-27044-01A

NO	REVISION	DATE

NORTH CAROLINA

PROFESSIONAL

022830

1-23-2025

ENGINEER

KEVIN M. ROOMSBURG

J K F

ARCHITECTURE

623 LYNDALE CT, SUITE F, GREENVILLE, NC 27858 252-355-1048

BEAUFORT COUNTY
COMMUNITY COLLEGE
INDUSTRIAL TRAINING CENTER
AURORA, NC

DRAWING TITLE

TYPICAL DETAILS

SCALE
1/8" = 1'-0"

DRAWN
JSS

CHECKED
KMR


DATE
1-6-2025

PROJECT NO.
2024-10

DRAWING NO

S5.1

© COPYRIGHT, JKF ARCHITECTURE PC, JOHN K. FARKAS, AIA

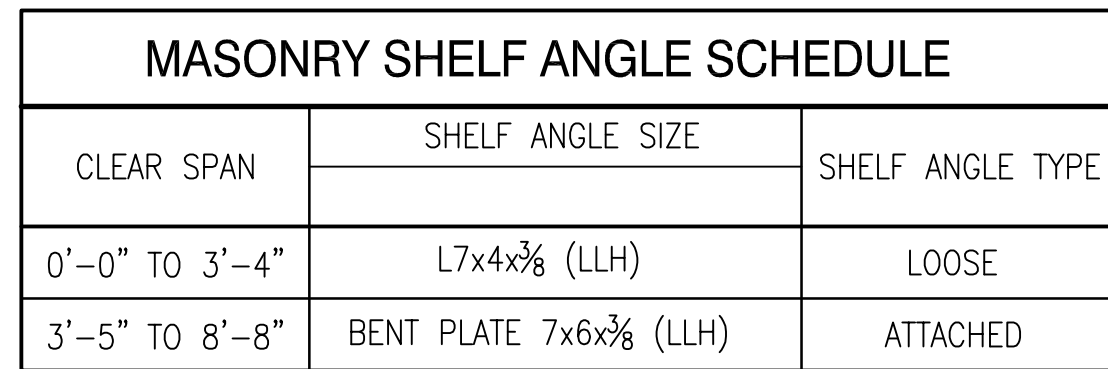


1. PROVIDE 8" MINIMUM BEARING AT EACH END OF ANGLE.
2. FOR EXACT SIZE AND LOCATION OF ALL WALL OPENINGS, COORDINATE WITH ARCHITECTURAL, MECHANICAL, PLUMBING AND ELECTRICAL DRAWINGS.
3. GALVANIZED SHELF ANGLES IN EXTERIOR WALLS.




NOT TO SCALE

NOT TO SCALE

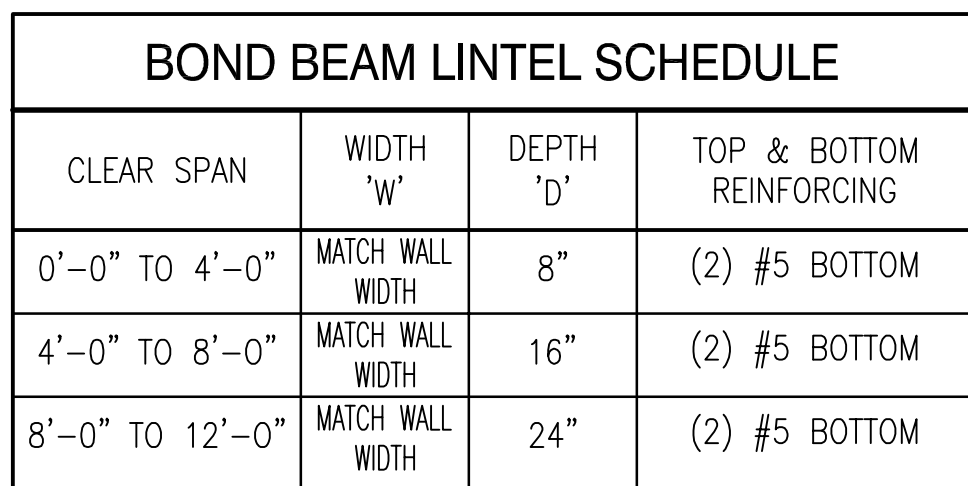

NOT TO SCALE

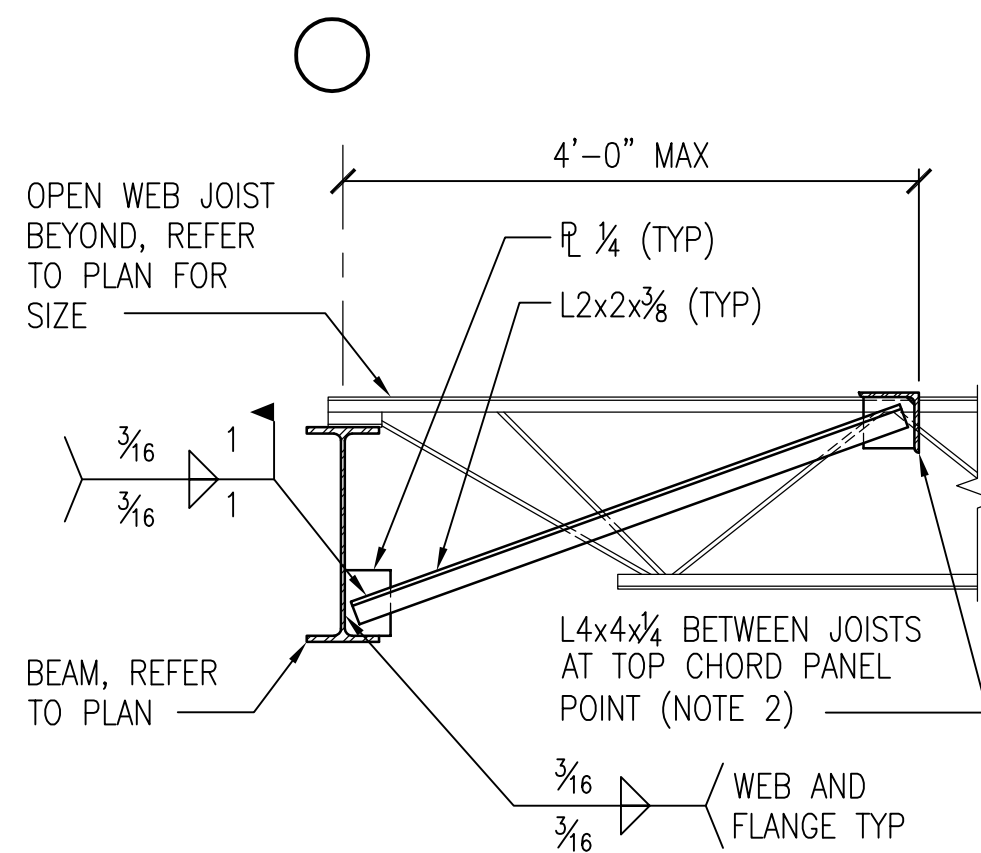


1. STEEL ROOF DECK IS OMITTED FOR CLARITY.
2. HORIZONTAL ANGLE SPANNING BETWEEN JOISTS TO BE LOCATED AT A PANEL POINT. IF THIS CONDITION CAN NOT BE SATISFIED, REFER TO TYPICAL JOIST REINFORCEMENT DETAIL.

NOT TO SCALE




























































NOT TO SCALE









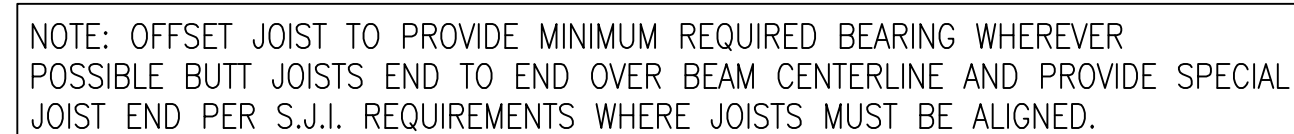



NOT TO SCALE



                        NOT TO SCALE

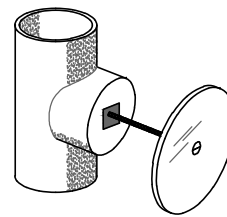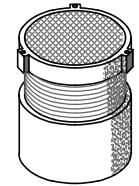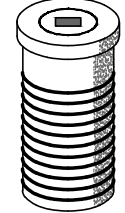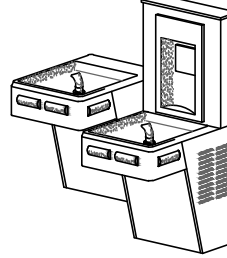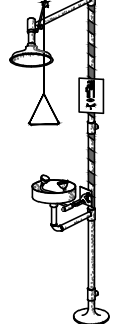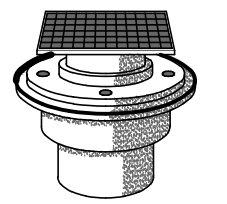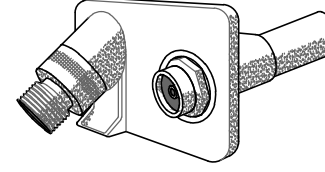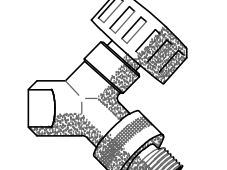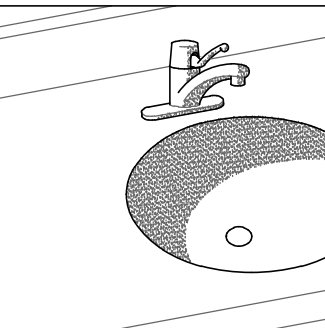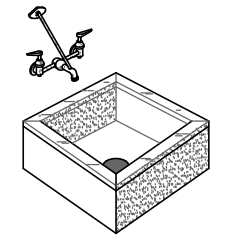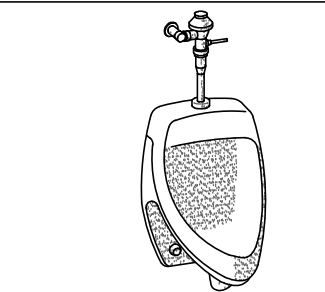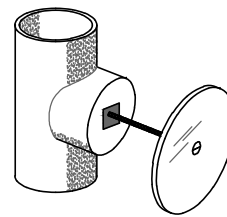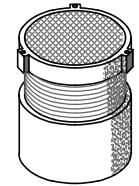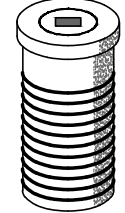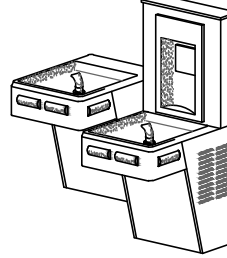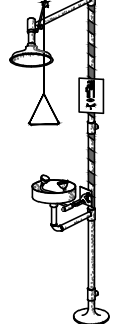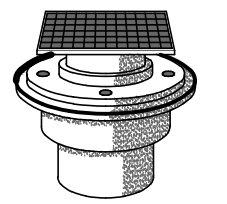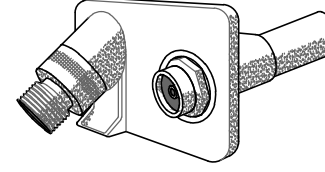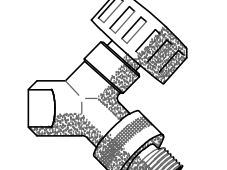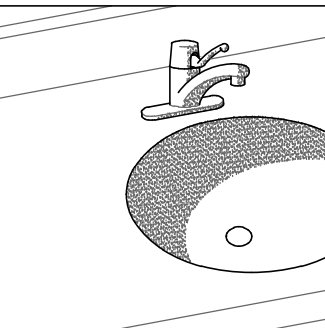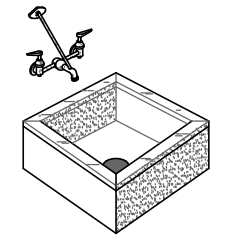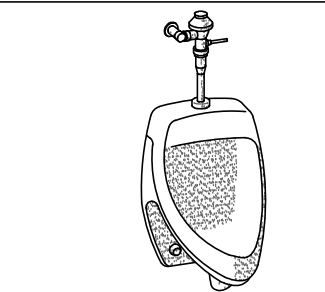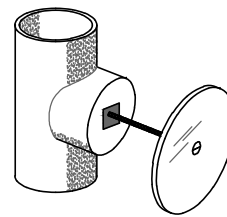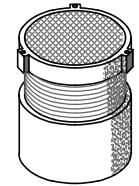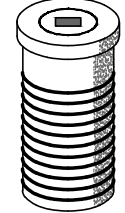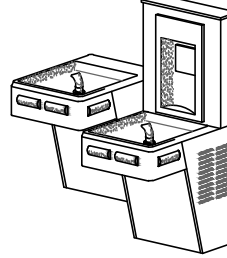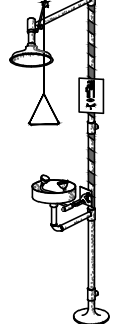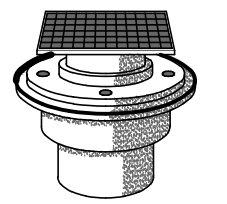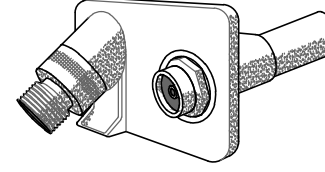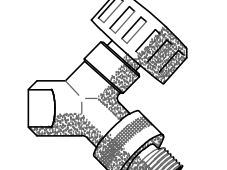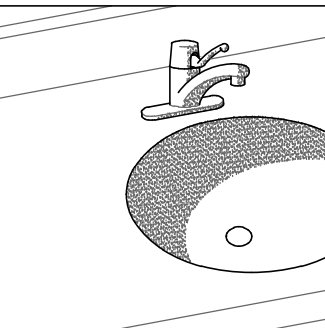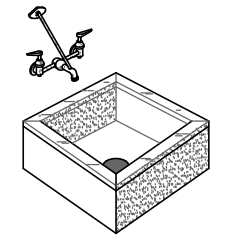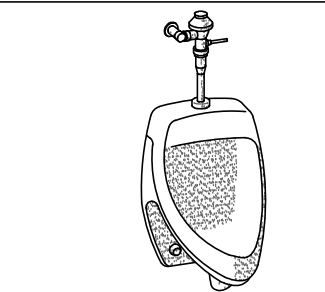	2	3	4	5	6	7	8	9	10	11	12	13	14	15																																																																																																																																																																																																																																																																																																																																																																																																				
	PLUMBING FIXTURE SCHEDULE <table><tr><th rowspan="2">SYMBOL / IMAGE</th><th rowspan="2">DESCRIPTION</th><th colspan="6">3 - EQUALS</th><th colspan="3">PIPING CONNECTIONS</th></tr><tr><th>MANUFACTURER</th><th>MODEL NUMBER</th><th>MANUFACTURER</th><th>MODEL NUMBER</th><th>MANUFACTURER</th><th>MODEL NUMBER</th><th>COLD WATER</th><th>HOT WATER</th><th>SANITARY SEWER</th></tr><tr><td rowspan="2"></td><td>WALL CLEANOUT</td><td>ZURN</td><td>CO-24IS-PVC</td><td>MFAB</td><td></td><td>JR SMITH</td><td></td><td>-</td><td>-</td><td>SEE PLUMB DRAWINGS</td></tr><tr><td>ACCESS COVER</td><td>ZURN</td><td>CO-2530-SS</td><td>MFAB</td><td></td><td>JR SMITH</td><td></td><td></td><td></td><td></td></tr><tr><td rowspan="2"></td><td>FLOOR CLEANOUT</td><td>ZURN</td><td>CO2449</td><td>MFAB</td><td></td><td>JR SMITH</td><td></td><td>-</td><td>-</td><td>SEE PLUMB DRAWINGS</td></tr><tr><td></td><td></td><td></td><td></td><td></td><td></td><td></td><td></td><td></td><td></td></tr><tr><td rowspan="2"></td><td>EXTERIOR CLEANOUT</td><td>ZURN</td><td>Z-1400-HD</td><td>WATTS</td><td>CO-200-RX-4-34</td><td>JR SMITH</td><td>4243</td><td>-</td><td>-</td><td>SEE PLUMB DRAWINGS</td></tr><tr><td>CLEANOUT HOUSING</td><td>ZURN</td><td>Z-1474</td><td>WATTS</td><td>CO-300-WF</td><td></td><td></td><td></td><td></td><td></td></tr><tr><td rowspan="2"></td><td>WATER COOLER</td><td>OASIS</td><td>P88FSL</td><td>ELKAY</td><td>LZSTL8WS</td><td>HALSEY TAYLOR</td><td>HTH-BHAC0BLPV-WF</td><td>1/2"</td><td>-</td><td>2"</td></tr><tr><td></td><td></td><td></td><td></td><td></td><td></td><td></td><td></td><td></td><td></td></tr><tr><td rowspan="2"></td><td>EMERGENCY EYEWASH SHOWER</td><td>BRADLEY</td><td>S9-314SB</td><td>SPEAKMAN</td><td>SE-697</td><td>GUARDIAN</td><td>G902</td><td>1 1/4"</td><td>1 1/4"</td><td>-</td></tr><tr><td>MIXING VALVE</td><td>BRADLEY</td><td>S9-2100</td><td>SPEAKMAN</td><td>SE-356</td><td>GUARDIAN</td><td>G380OLF</td><td></td><td></td><td></td></tr><tr><td rowspan="2"></td><td>FLOOR DRAIN</td><td>ZURN</td><td>ZW455</td><td>WATTS</td><td>FD-100-M</td><td>MFAB</td><td>F1000-H</td><td>1/2"</td><td>-</td><td>3"</td></tr><tr><td></td><td></td><td></td><td></td><td></td><td></td><td></td><td></td><td></td><td></td></tr><tr><td rowspan="2"></td><td>ANTIFREEZE HOSE BIBB</td><td>WOODFORD</td><td>65</td><td>WATTS</td><td>HY-420</td><td>MFAB</td><td>MHY-15</td><td>3/4"</td><td>-</td><td>-</td></tr><tr><td></td><td></td><td></td><td></td><td></td><td></td><td></td><td></td><td></td><td></td></tr><tr><td rowspan="2"></td><td>HOSE BIBB</td><td>WOODFORD</td><td>24</td><td>MFAB</td><td>MHY-9000-NFB</td><td>ZURN</td><td>195XL</td><td>3/4"</td><td>-</td><td>-</td></tr><tr><td></td><td></td><td></td><td></td><td></td><td></td><td></td><td></td><td></td><td></td></tr><tr><td rowspan="2"></td><td>LAVATORY</td><td>KOHLER</td><td>K-2210-O</td><td>AMERICAN STANDARD</td><td>9482000</td><td>TOTO</td><td>LT569</td><td></td><td></td><td></td></tr><tr><td>FAUCET</td><td>DELTA</td><td>523LF-HGM-HF</td><td>CHICAGO FAUCETS</td><td>2200-4</td><td>MOEN</td><td>8470</td><td></td><td></td><td></td></tr><tr><td rowspan="2"></td><td>TRAP</td><td>McGUIRE</td><td>8902</td><td>DEARBORN BRASS</td><td>702-1</td><td>KOHLER</td><td>K-8999</td><td></td><td></td><td>2"</td></tr><tr><td>SUPPLY</td><td>McGUIRE</td><td>58LK</td><td>BRASS CRAFT</td><td>R192AC</td><td>KOHLER</td><td>K-7605-P-CP</td><td>1/2"</td><td>1/2"</td><td></td></tr><tr><td rowspan="2"></td><td>MOP RECEPTOR</td><td>STERN WILLIAMS</td><td>SB-900</td><td>FIAT</td><td>T38100</td><td></td><td></td><td></td><td></td><td>3"</td></tr><tr><td>FAUCET</td><td>STERN WILLIAMS</td><td>T-10-VB</td><td>CHICAGO</td><td>897RCF</td><td>MOEN</td><td>8124</td><td>1/2"</td><td>1/2"</td><td></td></tr><tr><td rowspan="2"></td><td>HOSE</td><td>STERN WILLIAMS</td><td>T-35</td><td>FIAT</td><td>832AA</td><td></td><td></td><td></td><td></td><td></td></tr><tr><td>MOP BRACKET</td><td>STERN WILLIAMS</td><td>T-40</td><td>FIAT</td><td>889CC</td><td></td><td></td><td></td><td></td><td></td></tr><tr><td rowspan="2"></td><td>URINAL</td><td>KOHLER</td><td>K-5016-ET</td><td>SLOAN</td><td>SU7009</td><td>AMERICAN STANDARD</td><td>654U32</td><td></td><td></td><td>2"</td></tr><tr><td>VALVE</td><td>SLOAN</td><td>186</td><td>DELANY</td><td>F45H</td><td>ZURN</td><td>Z6003-AV</td><td>3/4"</td><td>-</td><td></td></tr><tr><td rowspan="2"></td><td>CARRIER</td><td>ZURN</td><td>Z-1221</td><td>JR SMITH</td><td>636</td><td>WATTS</td><td>CA-31</td><td></td><td></td><td></td></tr><tr><td></td><td></td><td></td><td></td><td></td><td></td><td></td><td></td><td></td><td></td></tr><tr><td rowspan="2"></td><td>SINK</td><td>BRADLEY</td><td>MF2949R</td><td>WILLOUGHBY</td><td>WAW-231R</td><td>ACORN</td><td>3644-H50</td><td></td><td></td><td></td></tr><tr><td>FAUCET</td><td>-</td><td>-</td><td>-</td><td>-</td><td>-</td><td>-</td><td></td><td></td><td></td></tr><tr><td rowspan="2"></td><td>TRAP</td><td>-</td><td>-</td><td>-</td><td>-</td><td>-</td><td>-</td><td></td><td></td><td>2"</td></tr><tr><td>SUPPLY</td><td>-</td><td>-</td><td>-</td><td>-</td><td>-</td><td>-</td><td>1/2"</td><td>1/2"</td><td></td></tr><tr><td colspan="11">UNIT SHALL BE FLOOR MOUNTED, FAUCET, TRAP, AND SUPPLY PROVIDED WITH LAVATORY. PROVIDE WITH WATER TEMPERATURE LIMITING DEVICE THAT CONFORMS TO ASSE 1070 OR CSA B125.3. PROVIDE WITH INFRARED ACTIVATION WITH PLUG-IN TRANSFORMER.</td></tr></table>										SYMBOL / IMAGE	DESCRIPTION	3 - EQUALS						PIPING CONNECTIONS			MANUFACTURER	MODEL NUMBER	MANUFACTURER	MODEL NUMBER	MANUFACTURER	MODEL NUMBER	COLD WATER	HOT WATER	SANITARY SEWER		WALL CLEANOUT	ZURN	CO-24IS-PVC	MFAB		JR SMITH		-	-	SEE PLUMB DRAWINGS	ACCESS COVER	ZURN	CO-2530-SS	MFAB		JR SMITH						FLOOR CLEANOUT	ZURN	CO2449	MFAB		JR SMITH		-	-	SEE PLUMB DRAWINGS												EXTERIOR CLEANOUT	ZURN	Z-1400-HD	WATTS	CO-200-RX-4-34	JR SMITH	4243	-	-	SEE PLUMB DRAWINGS	CLEANOUT HOUSING	ZURN	Z-1474	WATTS	CO-300-WF							WATER COOLER	OASIS	P88FSL	ELKAY	LZSTL8WS	HALSEY TAYLOR	HTH-BHAC0BLPV-WF	1/2"	-	2"												EMERGENCY EYEWASH SHOWER	BRADLEY	S9-314SB	SPEAKMAN	SE-697	GUARDIAN	G902	1 1/4"	1 1/4"	-	MIXING VALVE	BRADLEY	S9-2100	SPEAKMAN	SE-356	GUARDIAN	G380OLF					FLOOR DRAIN	ZURN	ZW455	WATTS	FD-100-M	MFAB	F1000-H	1/2"	-	3"												ANTIFREEZE HOSE BIBB	WOODFORD	65	WATTS	HY-420	MFAB	MHY-15	3/4"	-	-												HOSE BIBB	WOODFORD	24	MFAB	MHY-9000-NFB	ZURN	195XL	3/4"	-	-												LAVATORY	KOHLER	K-2210-O	AMERICAN STANDARD	9482000	TOTO	LT569				FAUCET	DELTA	523LF-HGM-HF	CHICAGO FAUCETS	2200-4	MOEN	8470					TRAP	McGUIRE	8902	DEARBORN BRASS	702-1	KOHLER	K-8999			2"	SUPPLY	McGUIRE	58LK	BRASS CRAFT	R192AC	KOHLER	K-7605-P-CP	1/2"	1/2"			MOP RECEPTOR	STERN WILLIAMS	SB-900	FIAT	T38100					3"	FAUCET	STERN WILLIAMS	T-10-VB	CHICAGO	897RCF	MOEN	8124	1/2"	1/2"			HOSE	STERN WILLIAMS	T-35	FIAT	832AA						MOP BRACKET	STERN WILLIAMS	T-40	FIAT	889CC							URINAL	KOHLER	K-5016-ET	SLOAN	SU7009	AMERICAN STANDARD	654U32			2"	VALVE	SLOAN	186	DELANY	F45H	ZURN	Z6003-AV	3/4"	-			CARRIER	ZURN	Z-1221	JR SMITH	636	WATTS	CA-31															SINK	BRADLEY	MF2949R	WILLOUGHBY	WAW-231R	ACORN	3644-H50				FAUCET	-	-	-	-	-	-					TRAP	-	-	-	-	-	-			2"	SUPPLY	-	-	-	-	-	-	1/2"	1/2"		UNIT SHALL BE FLOOR MOUNTED, FAUCET, TRAP, AND SUPPLY PROVIDED WITH LAVATORY. PROVIDE WITH WATER TEMPERATURE LIMITING DEVICE THAT CONFORMS TO ASSE 1070 OR CSA B125.3. PROVIDE WITH INFRARED ACTIVATION WITH PLUG-IN TRANSFORMER.											PLUMBING GENERAL NOTES 1. ALL WORK SHALL BE DONE IN ACCORDANCE WITH THE LATEST EDITION OF THE STATE CODE, ALL LOCAL AND OTHER APPLICABLE CODES. 2. ANY PERMITS AND INSPECTION FEES SHALL BE SECURED AND PAID FOR BY THE PLUMBING CONTRACTOR. 3. ALL WORK SHALL BE PERFORMED BY EXPERIENCED AND SKILLED CRAFTSMAN. THE PLUMBING CONTRACTOR SHALL COORDINATE ALL OF HIS WORK WITH ALL OTHER CONTRACTORS. 4. THE PLUMBING PLANS AND SPECIFICATIONS SHALL BE THOROUGHLY REVIEWED PRIOR TO PURCHASING MATERIALS AND INSTALLATION. ALL DISCREPANCIES OR INTERFERENCE'S SHALL BE BROUGHT TO THE ENGINEERS ATTENTION. 5. THESE PLANS ARE DIAGRAMMATIC AND MAY NOT SHOW MINOR DETAILS AND LOCATIONS. FOR DIMENSIONS, REFER TO THE ARCHITECTURAL PLANS. 6. THE PLUMBING CONTRACTOR SHALL PROVIDE ALL OPENINGS REQUIRED FOR THE PLUMBING WORK. THE PATCHING SHALL BE BY THE PLUMBING CONTRACTOR AND FINISHING BY GENERAL CONTRACTOR. 7. WATER PIPING BELOW GRADE SHALL BE TYPE 1" COPPER (NO JOINTS BELOW GRADE) AND ABOVE GRADE TYPE 1" COPPER, SUPPORTED AS REQUIRED AND SHALL BE HYDROSTATICALLY TESTED FOR ONE HOUR AT 150 PSI TEST TO COMPLY WITH ALL EPA STANDARDS. THE ENTIRE WATER DISTRIBUTION SYSTEM SHALL BE DISINFECTED PRIOR TO PLACING IN SERVICE. 8. ALL PIPE, FITTINGS, FIXTURES, AND SOLDER TO BE LEAD FREE. 9. WATER PIPING LOCATED ABOVE CEILINGS AND IN EXTERIOR WALLS SHALL BE ROUTED ON HEATED SIDE OF CEILING INSULATION (UNDERSIDE) AND WALL INSULATION (INSIDE). 10. ALL COLD AND HOT WATER PIPING SHALL BE INSULATED. INSULATE WASTE PIPING AS DESIGNATED ON PLUMBING DRAWINGS. INSULATION SHALL BE 1" FIBERGLASS. EXPOSED PIPING TO BE WRAPPED WITH ALUMINUM JACKET. 11. DO NOT SUPPORT PIPING FROM BAR JOIST BRIDGING AND/OR ROOF DECK. 12. WATER SHUT - OFF VALVES ABOVE FINISHED CEILING ARE TO BE FREE FROM OBSTRUCTIONS SUCH AS DUCTWORK, LIGHTS, WIRING AND OTHER PIPING SO AS TO PROVIDE EASY ACCESS. MOUNT NO MORE THAN 2'-0" ABOVE FINISHED CEILING. 13. IF THE WATER PRESSURE EXCEEDS 80 PSI A PRESSURE REDUCING VALVE SHALL BE INSTALLED WHERE THE WATER ENTERS THE BUILDING. 14. PLUMBING CONTRACTOR SHALL PROVIDE A DIELECTRIC UNION WHEN CONNECTING DISSIMILAR MATERIAL. 15. WATER HEATERS SHALL HAVE AND EFFICIENCY MEETING REQUIREMENTS OF THE NORTH CAROLINA BUILDING CODE. 16. THE PLUMBING CONTRACTOR SHALL BE RESPONSIBLE FOR ALL ELECTRICAL AND CONTROL CONNECTIONS TO THE EQUIPMENT FURNISHED UNDER HIS CONTRACT. 17. SANITARY SEWER AND VENT PIPING SHALL BE SCHEDULE 40 PVC, CELLULAR CORE (FOAM CORED) IS NOT ALLOWED. SANITARY SEWER AND VENT PIPING SHALL BE GAS AND AIR TIGHT. 18. THE PLUMBING CONTRACTOR SHALL COORDINATE ALL WORK WITH OTHER TRADES PRIOR TO INSTALLATION OF ANY WORK. 19. THE PLUMBING CONTRACTOR SHALL REVIEW ALL UTILITY SITE PLANS FOR WORK BY OTHERS. IT SHALL BE THE RESPONSIBILITY OF THE CONTRACTOR TO COORDINATE HIS WORK WITH WORK BY OTHERS AND AVOID ALL CONFLICTS. 20. LOCATIONS OF UTILITIES (WASTE AND WATER PIPING, ETC.) PROVIDED BY OTHERS, THAT ARE TO BE CONNECTED TO ARE ASSUMED. IT SHALL BE THE RESPONSIBILITY OF THE PLUMBING CONTRACTOR TO VERIFY THESE LOCATIONS AND MAKE FINAL CONNECTIONS AS REQUIRED. 21. VERIFY THE LOCATION OF ALL EQUIPMENT SUPPLIED BY OTHERS. 22. PROVIDE VACUUM BREAKERS ON ALL EQUIPMENT DIRECTLY CONNECTED TO THE WATER SYSTEM. 23. ALL VENT PIPING THROUGH THE ROOF SHALL BE A MINIMUM OF 15'-0" FROM ALL MAKE-UP AIR INLETS OR A MINIMUM OF 2'-0" ABOVE THE TOP OF ALL MAKE-UP AIR INLETS. VENTS THROUGH ROOF ARE TO BE ON REAR OF BUILDING. 24. SEE ARCHITECTURAL DRAWINGS FOR PLUMBING MINIMUM FACILITY CALCULATIONS. 25. ALL INDIRECT WASTE IS TO BE PROVIDED WITH AN AIR GAP 2 TIMES THE SIZE OF THE WASTE INLET. 26. THE PLUMBING CONTRACTOR SHALL VERIFY BUILDING FLOOR ELEVATION IS ABOVE MANHOLE RIM ELEVATION OR PROVIDE A BACKWATER VALVE AS REQUIRED. 27. THE PLUMBING CONTRACTOR SHALL BE RESPONSIBLE FOR MINOR DEMOLITION AT NO COST TO THE OWNER. 28. THE PLUMBING CONTRACTOR SHALL PROVIDE THE ENGINEER WITH A SET OF AS-BUILT DRAWINGS UPON COMPLETION OF PROJECT.					GENERAL NOTES SCO# 23-2704401A <table><tr><td></td><td></td><td></td></tr><tr><td></td><td></td><td></td></tr><tr><td></td><td></td><td></td></tr><tr><td></td><td></td><td></td></tr><tr><td>NO</td><td>REVISION</td><td>DATE</td></tr></table> J K F ARCHITECTURE 423 LYNDALE CT, SUITE F, GREENVILLE, NC 27858 252-355-1068 BEAUFORT COUNTY COMMUNITY COLLEGE INDUSTRIAL TRAINING CENTER AURORA, NC DRAWING TITLE PLUMBING NOTES, LEGEND, LOAD AND FIXTURE SCHEDULE SCALE NOT TO SCALE DRAWN DRD CHECKED JED DATE 01-06-2025 PROJECT NO. 2024-10 PO.I																	NO	REVISION	DATE
SYMBOL / IMAGE	DESCRIPTION	3 - EQUALS						PIPING CONNECTIONS																																																																																																																																																																																																																																																																																																																																																																																																										
		MANUFACTURER	MODEL NUMBER	MANUFACTURER	MODEL NUMBER	MANUFACTURER	MODEL NUMBER	COLD WATER	HOT WATER	SANITARY SEWER																																																																																																																																																																																																																																																																																																																																																																																																								
	WALL CLEANOUT	ZURN	CO-24IS-PVC	MFAB		JR SMITH		-	-	SEE PLUMB DRAWINGS																																																																																																																																																																																																																																																																																																																																																																																																								
	ACCESS COVER	ZURN	CO-2530-SS	MFAB		JR SMITH																																																																																																																																																																																																																																																																																																																																																																																																												
	FLOOR CLEANOUT	ZURN	CO2449	MFAB		JR SMITH		-	-	SEE PLUMB DRAWINGS																																																																																																																																																																																																																																																																																																																																																																																																								
	EXTERIOR CLEANOUT	ZURN	Z-1400-HD	WATTS	CO-200-RX-4-34	JR SMITH	4243	-	-	SEE PLUMB DRAWINGS																																																																																																																																																																																																																																																																																																																																																																																																								
	CLEANOUT HOUSING	ZURN	Z-1474	WATTS	CO-300-WF																																																																																																																																																																																																																																																																																																																																																																																																													
	WATER COOLER	OASIS	P88FSL	ELKAY	LZSTL8WS	HALSEY TAYLOR	HTH-BHAC0BLPV-WF	1/2"	-	2"																																																																																																																																																																																																																																																																																																																																																																																																								
	EMERGENCY EYEWASH SHOWER	BRADLEY	S9-314SB	SPEAKMAN	SE-697	GUARDIAN	G902	1 1/4"	1 1/4"	-																																																																																																																																																																																																																																																																																																																																																																																																								
	MIXING VALVE	BRADLEY	S9-2100	SPEAKMAN	SE-356	GUARDIAN	G380OLF																																																																																																																																																																																																																																																																																																																																																																																																											
	FLOOR DRAIN	ZURN	ZW455	WATTS	FD-100-M	MFAB	F1000-H	1/2"	-	3"																																																																																																																																																																																																																																																																																																																																																																																																								
	ANTIFREEZE HOSE BIBB	WOODFORD	65	WATTS	HY-420	MFAB	MHY-15	3/4"	-	-																																																																																																																																																																																																																																																																																																																																																																																																								
	HOSE BIBB	WOODFORD	24	MFAB	MHY-9000-NFB	ZURN	195XL	3/4"	-	-																																																																																																																																																																																																																																																																																																																																																																																																								
	LAVATORY	KOHLER	K-2210-O	AMERICAN STANDARD	9482000	TOTO	LT569																																																																																																																																																																																																																																																																																																																																																																																																											
	FAUCET	DELTA	523LF-HGM-HF	CHICAGO FAUCETS	2200-4	MOEN	8470																																																																																																																																																																																																																																																																																																																																																																																																											
	TRAP	McGUIRE	8902	DEARBORN BRASS	702-1	KOHLER	K-8999			2"																																																																																																																																																																																																																																																																																																																																																																																																								
	SUPPLY	McGUIRE	58LK	BRASS CRAFT	R192AC	KOHLER	K-7605-P-CP	1/2"	1/2"																																																																																																																																																																																																																																																																																																																																																																																																									
	MOP RECEPTOR	STERN WILLIAMS	SB-900	FIAT	T38100					3"																																																																																																																																																																																																																																																																																																																																																																																																								
	FAUCET	STERN WILLIAMS	T-10-VB	CHICAGO	897RCF	MOEN	8124	1/2"	1/2"																																																																																																																																																																																																																																																																																																																																																																																																									
	HOSE	STERN WILLIAMS	T-35	FIAT	832AA																																																																																																																																																																																																																																																																																																																																																																																																													
	MOP BRACKET	STERN WILLIAMS	T-40	FIAT	889CC																																																																																																																																																																																																																																																																																																																																																																																																													
	URINAL	KOHLER	K-5016-ET	SLOAN	SU7009	AMERICAN STANDARD	654U32			2"																																																																																																																																																																																																																																																																																																																																																																																																								
	VALVE	SLOAN	186	DELANY	F45H	ZURN	Z6003-AV	3/4"	-																																																																																																																																																																																																																																																																																																																																																																																																									
	CARRIER	ZURN	Z-1221	JR SMITH	636	WATTS	CA-31																																																																																																																																																																																																																																																																																																																																																																																																											
	SINK	BRADLEY	MF2949R	WILLOUGHBY	WAW-231R	ACORN	3644-H50																																																																																																																																																																																																																																																																																																																																																																																																											
	FAUCET	-	-	-	-	-	-																																																																																																																																																																																																																																																																																																																																																																																																											
	TRAP	-	-	-	-	-	-			2"																																																																																																																																																																																																																																																																																																																																																																																																								
	SUPPLY	-	-	-	-	-	-	1/2"	1/2"																																																																																																																																																																																																																																																																																																																																																																																																									
UNIT SHALL BE FLOOR MOUNTED, FAUCET, TRAP, AND SUPPLY PROVIDED WITH LAVATORY. PROVIDE WITH WATER TEMPERATURE LIMITING DEVICE THAT CONFORMS TO ASSE 1070 OR CSA B125.3. PROVIDE WITH INFRARED ACTIVATION WITH PLUG-IN TRANSFORMER.																																																																																																																																																																																																																																																																																																																																																																																																																		
NO	REVISION	DATE																																																																																																																																																																																																																																																																																																																																																																																																																
PLUMBING SYMBOL LEGEND <table><tr><th>SYMBOL</th><th>DESCRIPTION</th></tr><tr><td></td><td>COLD WATER PIPING</td></tr><tr><td></td><td>WATER PIPING DIRECTION OF FLOW</td></tr><tr><td></td><td>COLD WATER PIPING BELOW FINISHED FLOOR</td></tr><tr><td></td><td>HOT WATER PIPING BELOW FINISHED FLOOR</td></tr><tr><td></td><td>120° F HOT WATER PIPING</td></tr><tr><td></td><td>BALL VALVE</td></tr><tr><td></td><td>WATER PIPING TURNED DOWN</td></tr><tr><td></td><td>WATER PIPING TURNED UP</td></tr><tr><td></td><td>PIPING SIDE CONNECTION</td></tr><tr><td></td><td>SANITARY SEWER / WASTE PIPING</td></tr><tr><td></td><td>SANITARY SEWER / WASTE PIPING DIRECTION OF FLOW</td></tr><tr><td></td><td>VENT PIPING</td></tr><tr><td></td><td>VENT PIPE UP</td></tr><tr><td></td><td>PLUMBING FIXTURE PROVIDED AND INSTALLED BY PLUMBING CONTRACTOR</td></tr><tr><td></td><td>PLUMBING FIXTURE PROVIDED BY OTHERS AND INSTALLED BY PLUMBING CONTRACTOR</td></tr></table>											SYMBOL	DESCRIPTION		COLD WATER PIPING		WATER PIPING DIRECTION OF FLOW		COLD WATER PIPING BELOW FINISHED FLOOR		HOT WATER PIPING BELOW FINISHED FLOOR		120° F HOT WATER PIPING		BALL VALVE		WATER PIPING TURNED DOWN		WATER PIPING TURNED UP		PIPING SIDE CONNECTION		SANITARY SEWER / WASTE PIPING		SANITARY SEWER / WASTE PIPING DIRECTION OF FLOW		VENT PIPING		VENT PIPE UP		PLUMBING FIXTURE PROVIDED AND INSTALLED BY PLUMBING CONTRACTOR		PLUMBING FIXTURE PROVIDED BY OTHERS AND INSTALLED BY PLUMBING CONTRACTOR	PLUMBING LOAD SUMMARY <table><tr><th>WATER DEMAND FU</th><th>WATER DEMAND GPM</th><th>SANITARY SEWER DEMAND FU</th></tr><tr><td>69</td><td>58</td><td>39</td></tr></table>					WATER DEMAND FU	WATER DEMAND GPM	SANITARY SEWER DEMAND FU	69	58	39																																																																																																																																																																																																																																																																																																																																																													
SYMBOL	DESCRIPTION																																																																																																																																																																																																																																																																																																																																																																																																																	
	COLD WATER PIPING																																																																																																																																																																																																																																																																																																																																																																																																																	
	WATER PIPING DIRECTION OF FLOW																																																																																																																																																																																																																																																																																																																																																																																																																	
	COLD WATER PIPING BELOW FINISHED FLOOR																																																																																																																																																																																																																																																																																																																																																																																																																	
	HOT WATER PIPING BELOW FINISHED FLOOR																																																																																																																																																																																																																																																																																																																																																																																																																	
	120° F HOT WATER PIPING																																																																																																																																																																																																																																																																																																																																																																																																																	
	BALL VALVE																																																																																																																																																																																																																																																																																																																																																																																																																	
	WATER PIPING TURNED DOWN																																																																																																																																																																																																																																																																																																																																																																																																																	
	WATER PIPING TURNED UP																																																																																																																																																																																																																																																																																																																																																																																																																	
	PIPING SIDE CONNECTION																																																																																																																																																																																																																																																																																																																																																																																																																	
	SANITARY SEWER / WASTE PIPING																																																																																																																																																																																																																																																																																																																																																																																																																	
	SANITARY SEWER / WASTE PIPING DIRECTION OF FLOW																																																																																																																																																																																																																																																																																																																																																																																																																	
	VENT PIPING																																																																																																																																																																																																																																																																																																																																																																																																																	
	VENT PIPE UP																																																																																																																																																																																																																																																																																																																																																																																																																	
	PLUMBING FIXTURE PROVIDED AND INSTALLED BY PLUMBING CONTRACTOR																																																																																																																																																																																																																																																																																																																																																																																																																	
	PLUMBING FIXTURE PROVIDED BY OTHERS AND INSTALLED BY PLUMBING CONTRACTOR																																																																																																																																																																																																																																																																																																																																																																																																																	
WATER DEMAND FU	WATER DEMAND GPM	SANITARY SEWER DEMAND FU																																																																																																																																																																																																																																																																																																																																																																																																																
69	58	39																																																																																																																																																																																																																																																																																																																																																																																																																
1	2	3	4	5	6	7	8	9	10	11	12	13	14	15																																																																																																																																																																																																																																																																																																																																																																																																				

 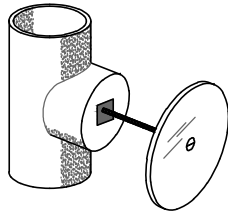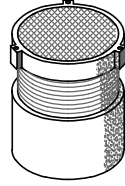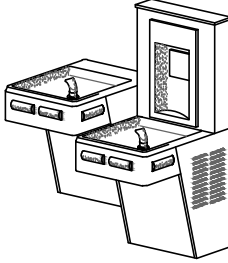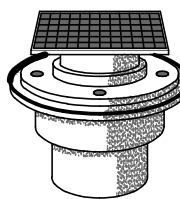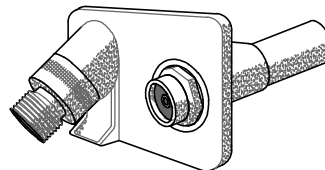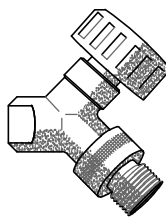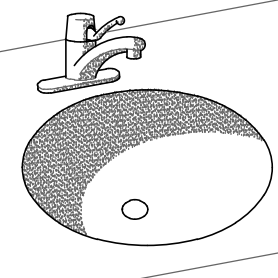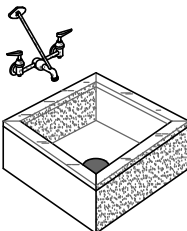SYMBOL / IMAGE	DESCRIPTION	3 - EQUALS						PIPING CONNECTIONS		
		MANUFACTURER	MODEL NUMBER	MANUFACTURER	MODEL NUMBER	MANUFACTURER	MODEL NUMBER	COLD WATER	HOT WATER	SANITARY SEWER
CO-1	WALL CLEANOUT	ZURN	CO-243-PVC	MFAB		JR SMITH		-	-	SEE PLUMBING DRAWINGS
	ACCESS COVER	ZURN	CO-2530-SS	MFAB		JR SMITH				
	PVC CLEANOUT BODY AND PLUG TO BE GAS AND WATER TIGHT. PLUG TO HAVE A BRASS THREADED INSERT TO RECEIVE SECURING SCREW FOR STAINLESS STEEL ROUND ACCESS COVER.									
CO-2	FLOOR CLEANOUT	ZURN	CO2449	MFAB		JR SMITH		-	-	SEE PLUMBING DRAWINGS
	PVC CLEANOUT WITH AND ADJUSTABLE PVC RISER, NICKEL BRONZE FRAME AND COVER, AND AN ABS TAPER THREADED PLUG. CLEANOUT TO BE GAS AND WATERTIGHT.									
CO-3	EXTERIOR CLEANOUT	ZURN	Z-1400-HD	WATTS	CO-200-RX-4-34	JR SMITH	4243	-	-	SEE PLUMBING DRAWINGS
	CLEANOUT HOUSING	ZURN	Z-1474	WATTS	CO-300-MF					
	HEAVY DUTY EXTERIOR CLEANOUT WITH CAST IRON BODY, EXTRA HEAVY DUTY TOP, AND GAS AND WATERTIGHT ABS TAPERED THREAD PLUG.									
	EW-C1	OASIS	P8SEFSL	ELKAY	LZSTL8WS	HALSEY TAYLOR	HTHBAC08LVPV-WF	1/2"	-	2"
	PROVIDE WITH FRONT AND SIDE CONTROLS, SHUT-OFF VALVE, CARRIER, AND TRAP. PROVIDE STAINLESS STEEL FINISH. PROVIDE WITH BOTTLE FILLER.									
EWS-1	EMERGENCY EYEWASH SHOWER	BRADLEY	S9-34ASB	SPEAKMAN	SE-697	GUARDIAN	G902	1 1/4"	1 1/4"	-
	MIXING VALVE	BRADLEY	S9-200	SPEAKMAN	SE-356	GUARDIAN	G380OLF			
	COMBINATION SHOWER AND EYEWASH WITH SHOWER-HEAD, RECEPTOR, TWIN ANTI-SURGE SOFT-FLO EYEWASH HEADS, PULL ROD ACTIVATED SHOWER, AND PUSH FLAG ACTIVATED EYEWASH. PROVIDE WITH FLOOR DRAIN AND WITH TEPID WATER THROUGH A MIXING VALVE.									
FD-1	FLOOR DRAIN	ZURN	ZN455	WATTS	FD-100-M	MFAB	FI0001	1/2"	-	3"
	FLOOR DRAIN TO HAVE A 3" WASTE BOTTOM OUTLET, CAST IRON BODY WITH ADJUSTABLE COLLAR, POLISHED 6" x 6" NICKEL BRONZE SQUARE HEELPROOF STRAINER, AND 1/2" TRAP PRIMER CONNECTION.									
HH	ANTIFREEZE HOSE BIBB	WOODFORD	65	WATTS	HY-420	MFAB	MHY-5	3/4"	-	-
	ANTIFREEZE HOSE BIBB SHALL HAVE AUTOMATIC DRAINING WITH ANTI-SIPHON VACUUM BREAKER. 3/4" INLET AND OUTLET. EXTERIOR FINISH TO BE CHROME. PROVIDE WITH LOOSE TEE KEY FOR EACH HOSE BIBB. MOUNT 12" ABOVE FINISHED GRADE.									
HH	HOSE BIBB	WOODFORD	24	MFAB	MHY-9000-HFB	ZURN	195XL	3/4"	-	-
	HOSE BIBB SHALL HAVE AUTOMATIC DRAINING WITH ANTI-SIPHON VACUUM BREAKER. 3/4" INLET AND OUTLET. EXTERIOR FINISH TO BE CHROME. PROVIDE WITH LOOSE TEE KEY FOR EACH HOSE BIBB.									
	L-1	KOHLER	K-220-O	AMERICAN STANDARD	9482000	TOTO	LT569			
	FAUCET	DELTA	523LF-HGM-HDF	CHICAGO FAUCETS	2200-4	MOEN	8470			
	TRAP	McGUIRE	6902	DEARBORN BRASS	7024	KOHLER	K-6999			2"
	SUPPLY	McGUIRE	58LK	BRASS CRAFT	R192AC	KOHLER	K-7605-P-CP	1/2"	1/2"	
	UNDERMOUNT LAVATORY SHALL BE MADE OF VITREOUS CHINA WITH A WHITE FINISH. HAVE AN OVERFLOW, AND INCLUDE SEALANT. FAUCET SHALL BE CHROME FINISH. SINGLE LEVER, 4" CENTERS, WITH 3/8" COPPER SUPPLY TUBE INLETS, AND PROVIDED WITH AN AERATOR. RIGID SUPPLY KIT SHALL INCLUDE CHROME PLATED BRASS STOPS WITH THREADED CONNECTIONS, FULL TURN BRASS STEM, REDUCER, AND FLANGE. INLET SHALL BE 3/8" IPS. OUTLET SHALL BE 3/8" IPS. P-TRAP SHALL BE CHROME PLATED CAST BRASS BODY WITH CLEANOUT, CAST BRASS ELBOW, CAST BRASS SLIP NUT, AND FLANGE. PROVIDE WITH OFFSET STRAINER, McGUIRE PROWRAP INSULATOR, AND APPROVED WATER-TEMPERATURE LIMITING DEVICE THAT CONFORMS TO ASSE 1070 OR CSA B125.3.									
MR-1	MOP RECEPTOR	STERN WILLIAMS	SB-900	FIAT	T3800					3"
	FAUCET	STERN WILLIAMS	T-10-VB	CHICAGO	897RCF	MOEN	8124	1/2"	1/2"	
	HOSE	STERN WILLIAMS	T-35	FIAT	832AA					
	MOP BRACKET	STERN WILLIAMS	T-40	FIAT	889CC					
	MOP RECEPTOR SHALL BE 24" x 24" x 12" DEEP WITH ONE PIECE STAINLESS STEEL CAP, NO FLANGES.									
	U-1	KOHLER	K-506-ET	SLOAN	SU7009	AMERICAN STANDARD	654U32			2"
	VALVE	SLOAN	166	DELANEY	F45H	ZURN	Z6003-AV	3/4"	-	
	CARRIER	ZURN	Z-121	JR SMITH	636	WATTS	CA-31			
	URINAL SHALL BE MADE OF VITREOUS CHINA WITH A WHITE FINISH AND 3/4" TOP SPUD. EXPOSED CHROME PLATED FLUSH VALVE WITH 3/4" CHROME PLATED SPUD COUPLING AND FLANGE. MOUNTING HEIGHT TO BE ADA COMPLIANT.									
	S-1	BRADLEY	MF2949R	WILLOUGHBY	WAW-231R	ACORN	3644-HSO			
NO IMAGE	FAUCET	-	-	-	-	-	-			
	TRAP	-	-	-	-	-	-			2"
	SUPPLY	-	-	-	-	-	-	1/2"	1/2"	
	UNIT SHALL BE FLOOR MOUNTED. FAUCET, TRAP, AND SUPPLY PROVIDED WITH LAVATORY. PROVIDE WITH WATER TEMPERATURE LIMITING DEVICE THAT CONFORMS TO ASSE 1070 OR CSA B125.3. PROVIDE WITH INFRARED ACTIVATION WITH PLUG-IN TRANSFORMER.									

 PLUMBING SYMBOL LEGEND		
SYMBOL	DESCRIPTION	
	COLD WATER PIPING	
	WATER PIPING DIRECTION OF FLOW	
	COLD WATER PIPING BELOW FINISHED FLOOR	
	HOT WATER PIPING BELOW FINISHED FLOOR	
	120° F HOT WATER PIPING	
	BALL VALVE	
	WATER PIPING TURNED DOWN	
	WATER PIPING TURNED UP	
	PIPING SIDE CONNECTION	
	SANITARY SEWER / WASTE PIPING	
	SANITARY SEWER / WASTE PIPING DIRECTION OF FLOW	
	VENT PIPING	
	VENT PIPE UP	
	PLUMBING FIXTURE PROVIDED AND INSTALLED BY PLUMBING CONTRACTOR	
	PLUMBING FIXTURE PROVIDED BY OTHERS AND INSTALLED BY PLUMBING CONTRACTOR	
PLUMBING LOAD SUMMARY		
WATER DEMAND FU	WATER DEMAND GPM	SANITARY SEWER DEMAND FU
69	58	39

ATLANTECENGINEERS, P.A.

nowIMEG

322 BLUE RIDGE ROAD, SUITE 15RALEIGH, NC 27602919 571-124097

SEAL

IMEGCONSULTANTS CORP.No. T-1507

SEAL

IMEGCONSULTANTS CORP.No. T-1507

GENERAL NOTES

KEY PLAN

SCO# 23-2704401A

NO

REVISION

DATE

J K FARCHITECTURE

625 LYNNDALE CT., SUITE F, GREENVILLE, NC 27858 252-355-1068

BEAUFORT COUNTYCOMMUNITY COLLEGEINDUSTRIAL TRAINING CENTER

ALORA, NC

DRAWING TITLE

PLUMBING NOTES, LEGEND, LOAD AND FIXTURE SCHEDULE

SCALE

NOT TO SCALE

DRAWING NO

DRAWN

DRD

CHECKED

JBD

DATE

01-06-2025

PROJECT NO.

2024-10

PO.1

© COPYRIGHT, JKF ARCHITECTURE PC, JOHN K. FARAS, AIA

1

2

3

4

5

6

7

8

9

10

11

12

13

14

15

M

L

K

J

H

G

F

E

D

C

B

A

24097

1

2

3

4

5

6

7

8

9

10

11


 
12

13

14

15

PLUMBING FIXTURE SCHEDULE

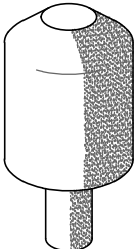SYMBOL / IMAGE	DESCRIPTION	3 - EQUALS						PIPING CONNECTIONS		
		MANUFACTURER	MODEL NUMBER	MANUFACTURER	MODEL NUMBER	MANUFACTURER	MODEL NUMBER	COLD WATER	HOT WATER	SANITARY SEWER
SA-1	SHOCK ABSORBER	JOSAM	75000	ZURN	Z1700	WADE	4480			
	SHOCK ABSORBERS SHALL HAVE A STAINLESS STEEL CASING, FLEXIBLE MECHANICAL BELLOW, PRESSURIZED INERT GAS CHAMBER AND CERTIFICATION STAMP AS CONFORMING TO STANDARD FDI WH-201 OF THE PLUMBING AND DRAINAGE INSTITUTE.									
TP-1	TRAP PRIMER	MIFAB	MR-500					1/2"	-	-
	PRESSURE DROP ACTIVATED BRASS TRAP SEAL PRIMER, WITH INLET OPENING OF 1/2" MALE N.P.T. AND OUTLET OPENING OF FEMALE 1/2" N.P.T. SERVES UP TO 6 FLOOR DRAIN TRAPS.									
WC-1	WATER CLOSET	KOHLER	K-96059-O	SLOAN	ST-2009	AMERICAN STANDARD	2234.05			4"
	SEAT	BEMIS	K655SSC	KOHLER	K-4670-C-O	CHURCH	9500C			
	VALVE	SLOAN	III	DELANY	F402H	ZURN	Z6000-WSI	1"	-	
WC-2	WATER CLOSET	KOHLER	K-96057-O	SLOAN	ST-2029	AMERICAN STANDARD	2305J00			4"
	SEAT	BEMIS	K655SSC	KOHLER	K-4670-C-O	CHURCH	9500C			
	VALVE	SLOAN	III	DELANY	F402H	ZURN	Z6000-WSI	1"	-	
WH-1	WATER CLOSET	KOHLER	K-96057-O	SLOAN	ST-2029	AMERICAN STANDARD	2305J00			4"
	SEAT	BEMIS	K655SSC	KOHLER	K-4670-C-O	CHURCH	9500C			
	VALVE	SLOAN	III	DELANY	F402H	ZURN	Z6000-WSI	1"	-	
	WATER HEATER	STATE INDUSTRIES	PCE 50 20LSA	RHEEM/RLUD	ELD552	LOCHINVAR		3/4"	3/4"	
	ELECTRIC WATER HEATER SHALL HAVE A 50 GALLON STORAGE CAPACITY, AN ELECTRIC INPUT OF 4.5 KW AT 208 VOLT, SINGLE PHASE AND A RECOVERY OF 19 GPH AT A 100°F RISE. PROVIDE WITH THERMOSTATIC MIXING VALVE SET AT 110°F, EXPANSION TANK AND HEAVY DUTY FUSIBLE DISCONNECT, WIRING BY LICENSED ELECTRICAL CONTRACTOR. WATER HEATER TO BE PROVIDED WITH HEAT TRAPS AND MEET THE ENERGY EFFICIENCY REQUIREMENT PER 2018 NORTH CAROLINA STATE BUILDING CODE: ENERGY CONSERVATION CODE.									
	PLUMBING SCHEDULE NOTES AND LEGEND: 1. THE PLUMBING CONTRACTOR MAY SUBSTITUTE FIXTURES WITH OWNERS' APPROVAL. 2. SUBMIT CUT SHEETS FOR ALL PROPOSED FIXTURES TO ARCHITECT PRIOR TO BIDDING. 3. PROVIDE VACUUM BREAKER ON ALL EQUIPMENT REQUIRING PLUMBING. 4. REFER TO MANUFACTURERS WEB SITE FOR CUT SHEETS AND DATA ON THE FIXTURES AND APPURTENANCES USED IN THIS SCHEDULE.  ADA COMPLIANT  ELECTRICAL POWER									


ATLANTECENGINEERS, P.A.

now


IMEG

320 BLUE RIDGE ROAD, SUITE 15
RALEIGH, NC 27602
919 571-1111
24097

SEAL

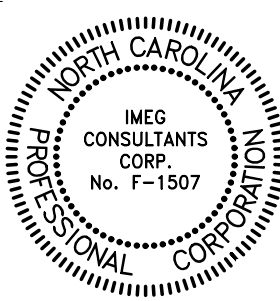

SEAL

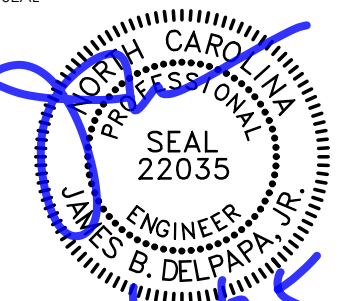

GENERAL NOTES

KEY PLAN

SCO# 23-2704401A

NO	REVISION	DATE

J K F

ARCHITECTURE

625 LYNNDALE CT., SUITE F, GREENVILLE, NC 27858 252-355-1068

BEAUFORT COUNTY
COMMUNITY COLLEGE
INDUSTRIAL TRAINING CENTER
AURORA, NC

DRAWING TITLE

PLUMBING FIXTURE SCHEDULE

SCALE

NOT TO SCALE

DRAWN

DRD

CHECKED

JBD

DATE

01-06-2025


PROJECT NO.

2024-10

DRAWING NO

PO.2



© COPYRIGHT, JKF ARCHITECTURE PC, JOHN K. FARRAS, AIA

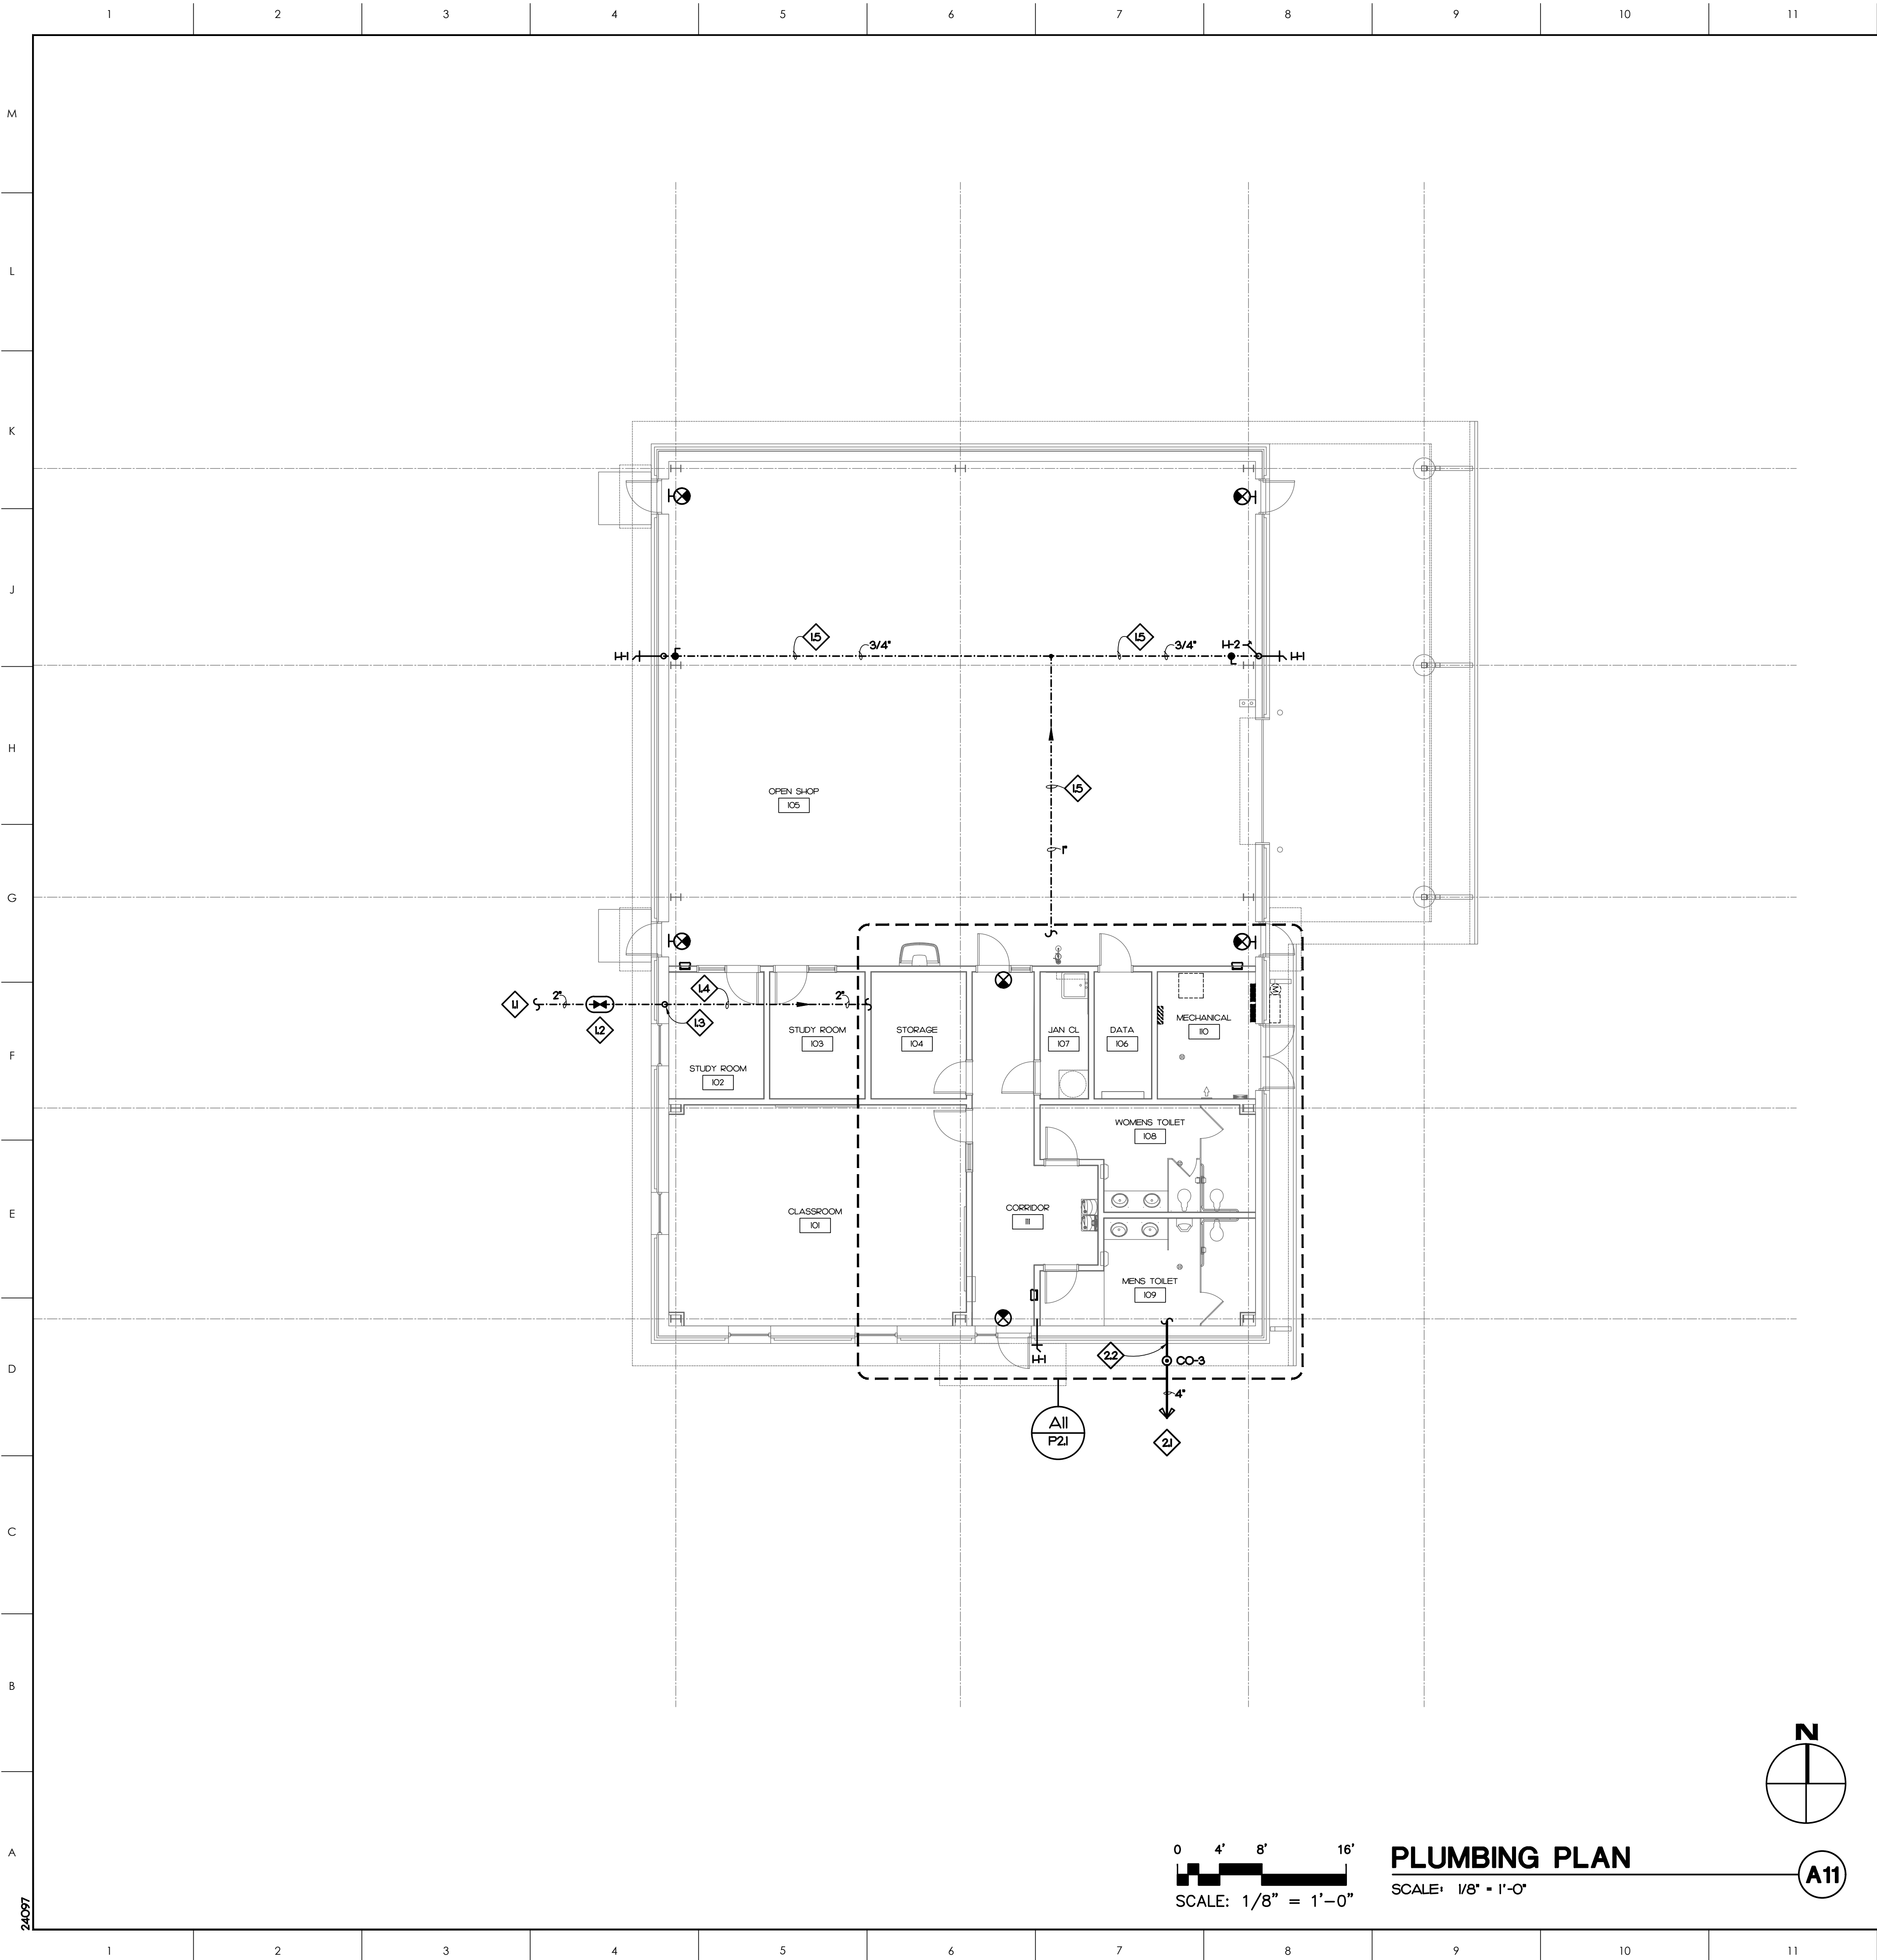

PLUMBING KEY NOTES

- 1 2" COLD WATER PIPE BELOW FINISHED GRADE. PLUMBING CONTRACTOR'S WORK BEGINS 5'-0" OUTSIDE BUILDING. SEE SITE PLAN FOR CONTINUATION, WATER METER AND BACKFLOW PREVENTER.
- 12 MAIN SHUT OFF VALVE IN VALVE BOX.
- 13 WATER LINE UP IN WALL TO ABOVE FINISHED CEILING.
- 14 WATER PIPING ABOVE FINISHED CEILING. COORDINATE LOCATION WITH MECHANICAL AND ELECTRICAL CONTRACTORS.
- 15 WATER PIPING AT STRUCTURE. COORDINATE LOCATION WITH MECHANICAL AND ELECTRICAL CONTRACTORS. ROUTE WATER PIPING IN SHOP AREA IN A NEAT MANNER. GENERAL CONTRACTOR IS TO PAINT TO MATCH SURROUNDINGS.
- 21 4" SANTARY SEWER PIPE BELOW FINISHED GRADE. PLUMBING CONTRACTOR'S WORK EXTENDS 5'-0" OUTSIDE BUILDING. SEE SITE PLAN FOR CONTINUATION.
- 22 INVERT ELEVATION IS TO BE 2.05' BELOW FINISHED FLOOR.

ATLANTEC
ENGINEERS, P.A.
now **IMEG**
322 BLUE RIDGE ROAD, SUITE 15
RALEIGH, NC 27602
240977

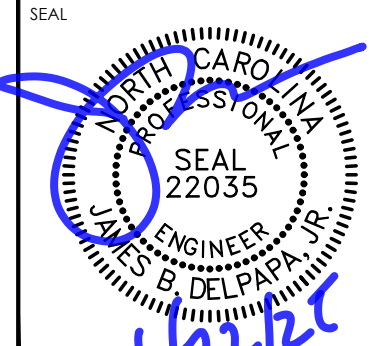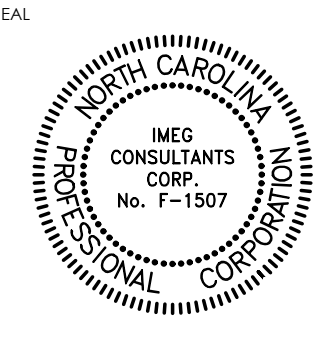

GENERAL NOTES

KEY PLAN

SCO# 23-2704401A

NO	REVISION	DATE



J K F
ARCHITECTURE

625 LYNNDALE CT., SUITE F, GREENVILLE, NC 27858 252-355-1068

BEAUFORT COUNTY
COMMUNITY COLLEGE
INDUSTRIAL TRAINING CENTER
AURORA, NC


DRAWING TITLE
PLUMBING PLAN

SCALE 1/8" = 1'-0"	DRAWING NO. P.I.1
DRAWN DRD	
CHECKED JBD	
DATE 01-06-2025	
PROJECT NO. 2024-10	

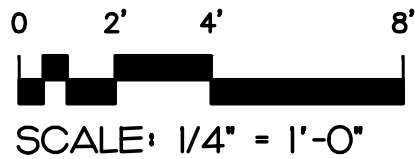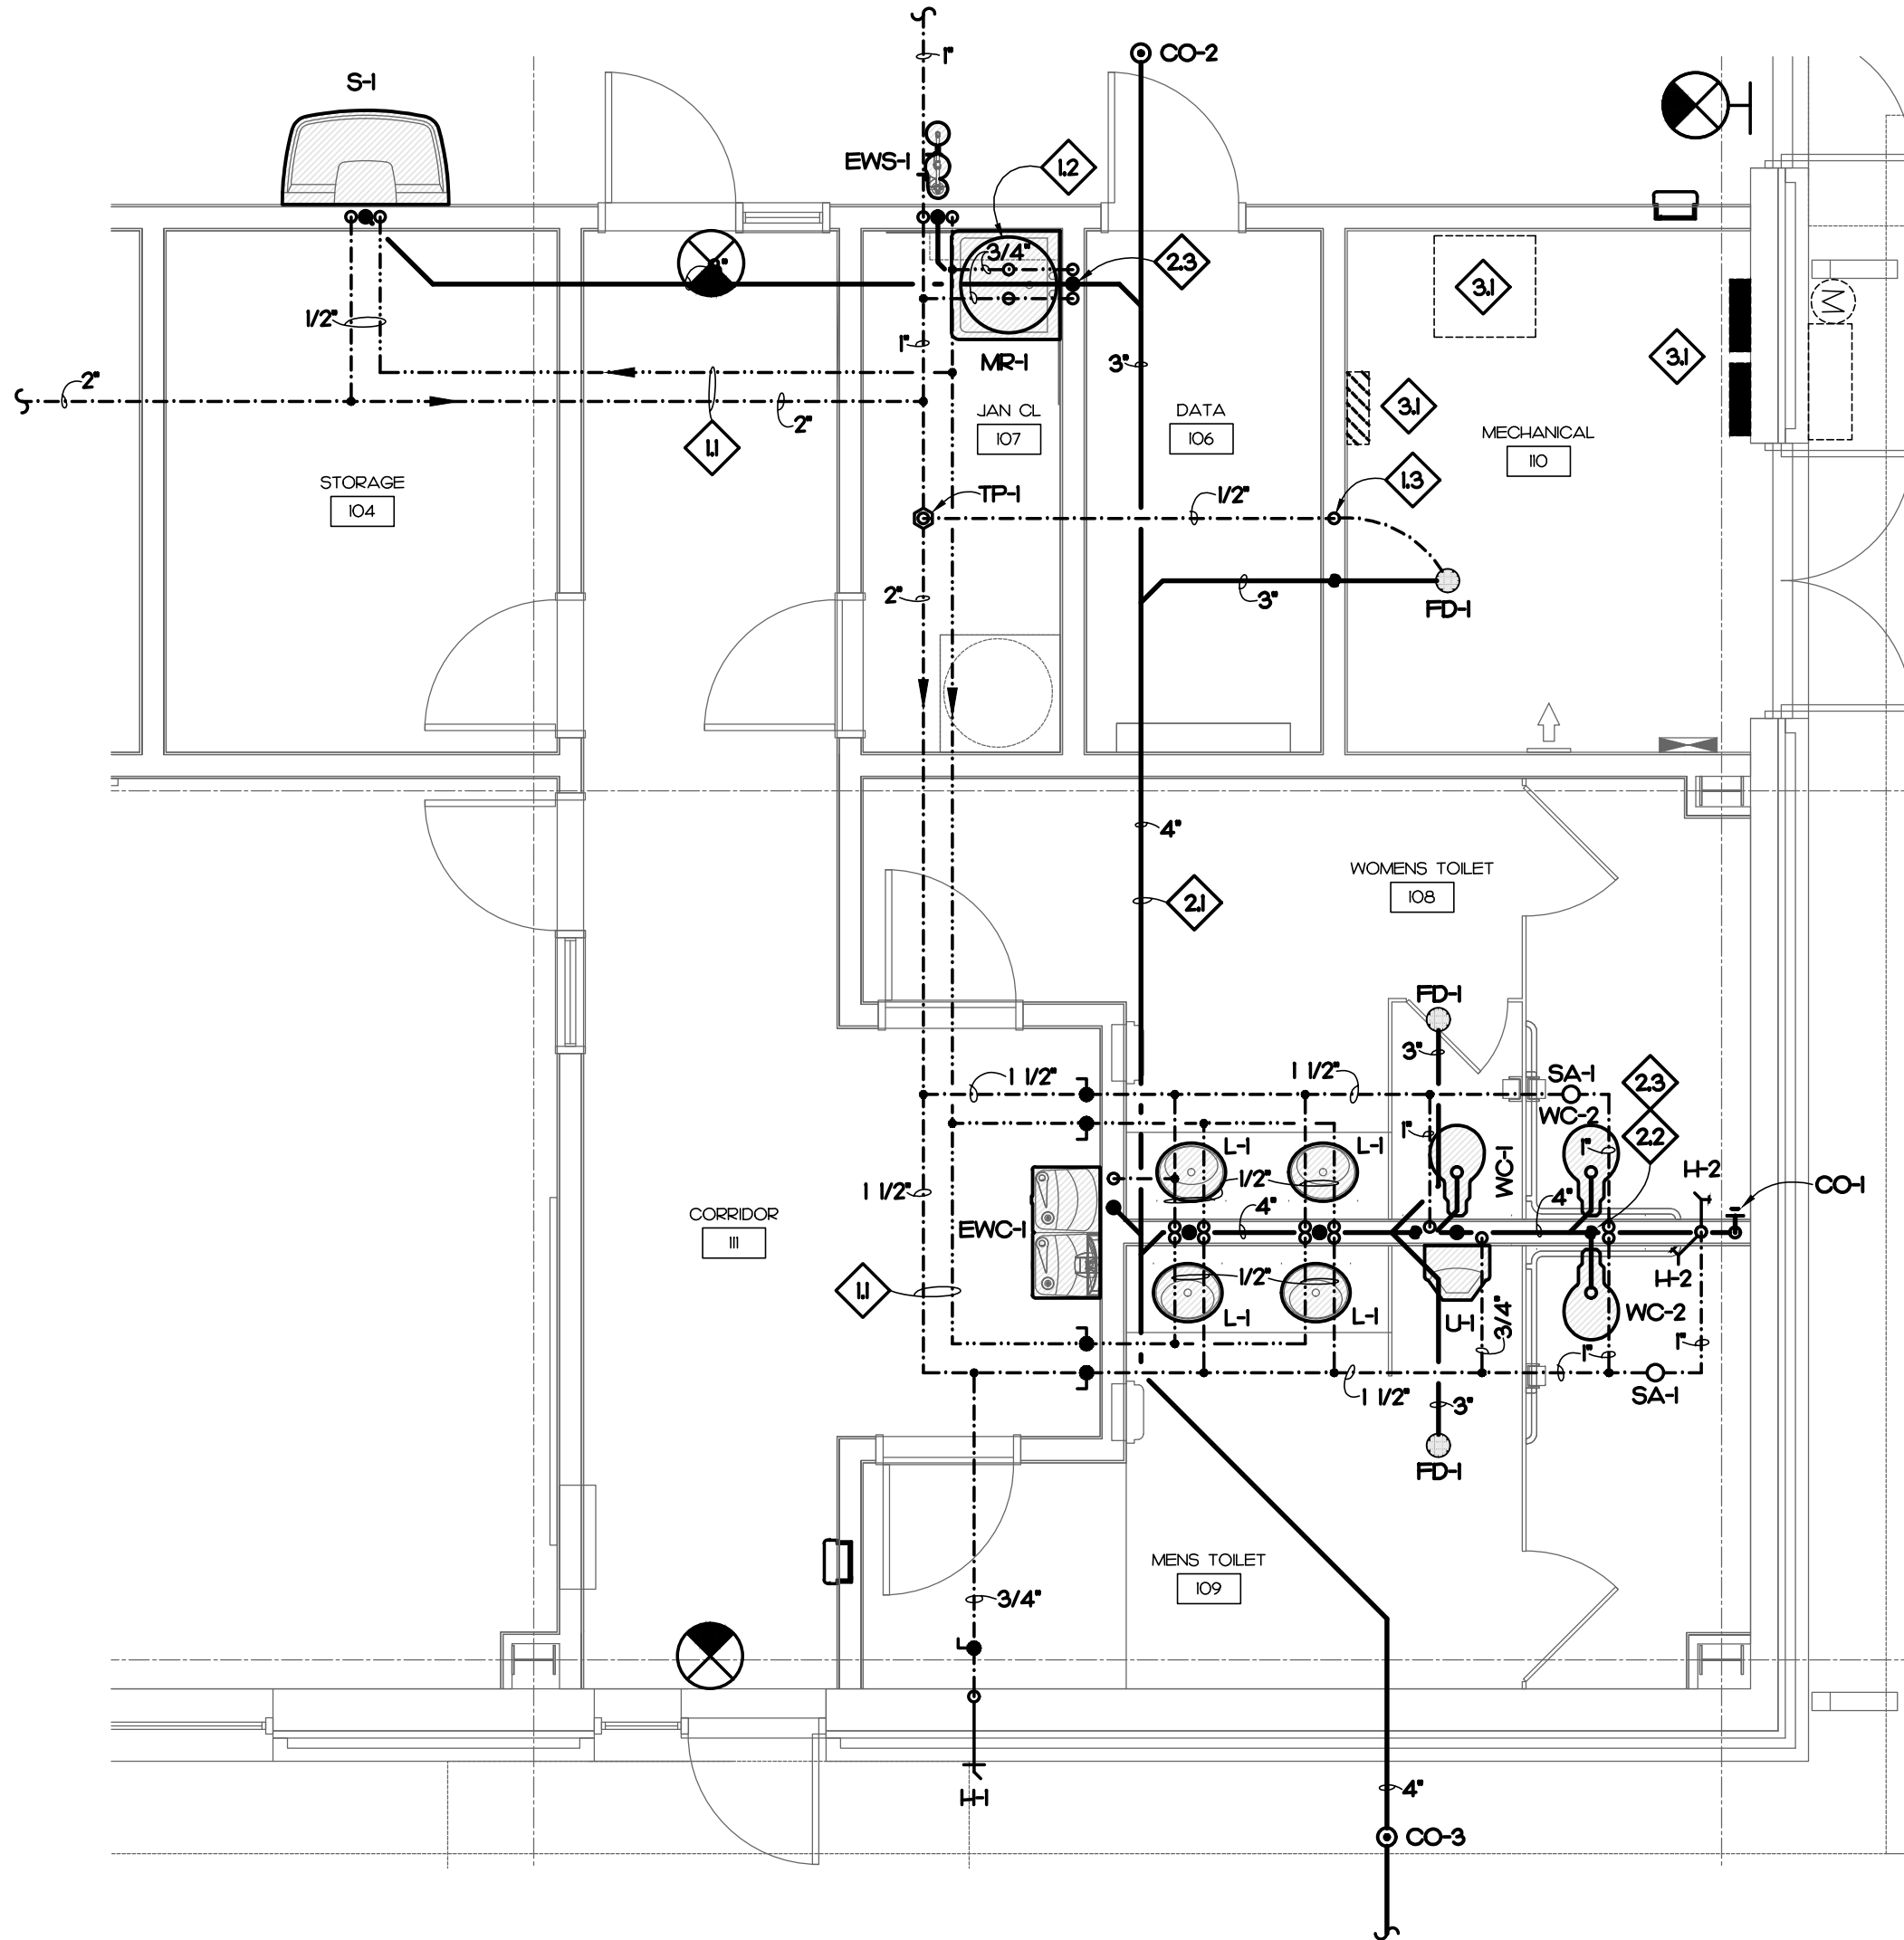

ENLARGED PLUMBING PLAN



SCALE: 1/4" = 1'-0"

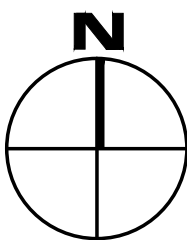

A11

PLUMBING KEY NOTES

- 1 WATER PIPING ABOVE FINISHED CEILING. COORDINATE LOCATION WITH MECHANICAL AND ELECTRICAL CONTRACTORS.
- 2 WATER HEATER (WH-1) LOCATED ON WALL.
- 3 DROP IN WALL TO BELOW FINISHED FLOOR.
- 21 SANITARY SEWER PIPE BELOW FINISHED FLOOR.
- 22 SANITARY TEE.
- 23 3" VENT THROUGH ROOF.
- 31 ELECTRICAL EQUIPMENT BY ELECTRICAL CONTRACTOR.

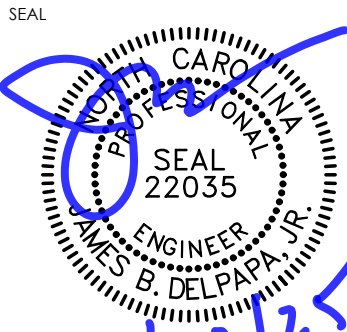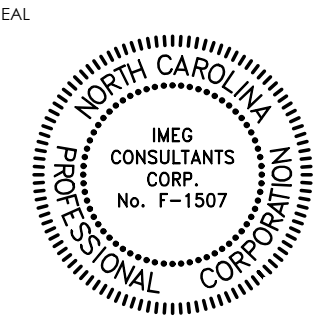

112425

GENERAL NOTES

KEY PLAN

SCO# 23-2704401A

NO	REVISION	DATE
----	----------	------

J K F
ARCHITECTURE


625 LYNNDALE CT., SUITE F, GREENVILLE, NC 27858 252-355-1068

BEAUFORT COUNTY
COMMUNITY COLLEGE
INDUSTRIAL TRAINING CENTER
AURORA, NC

DRAWING TITLE
ENLARGED PLUMBING PLAN

SCALE	1/4" = 1'-0"
DRAWN	DRD
CHECKED	JBD
DATE	01-06-2025
PROJECT NO.	2024-10

P2.1

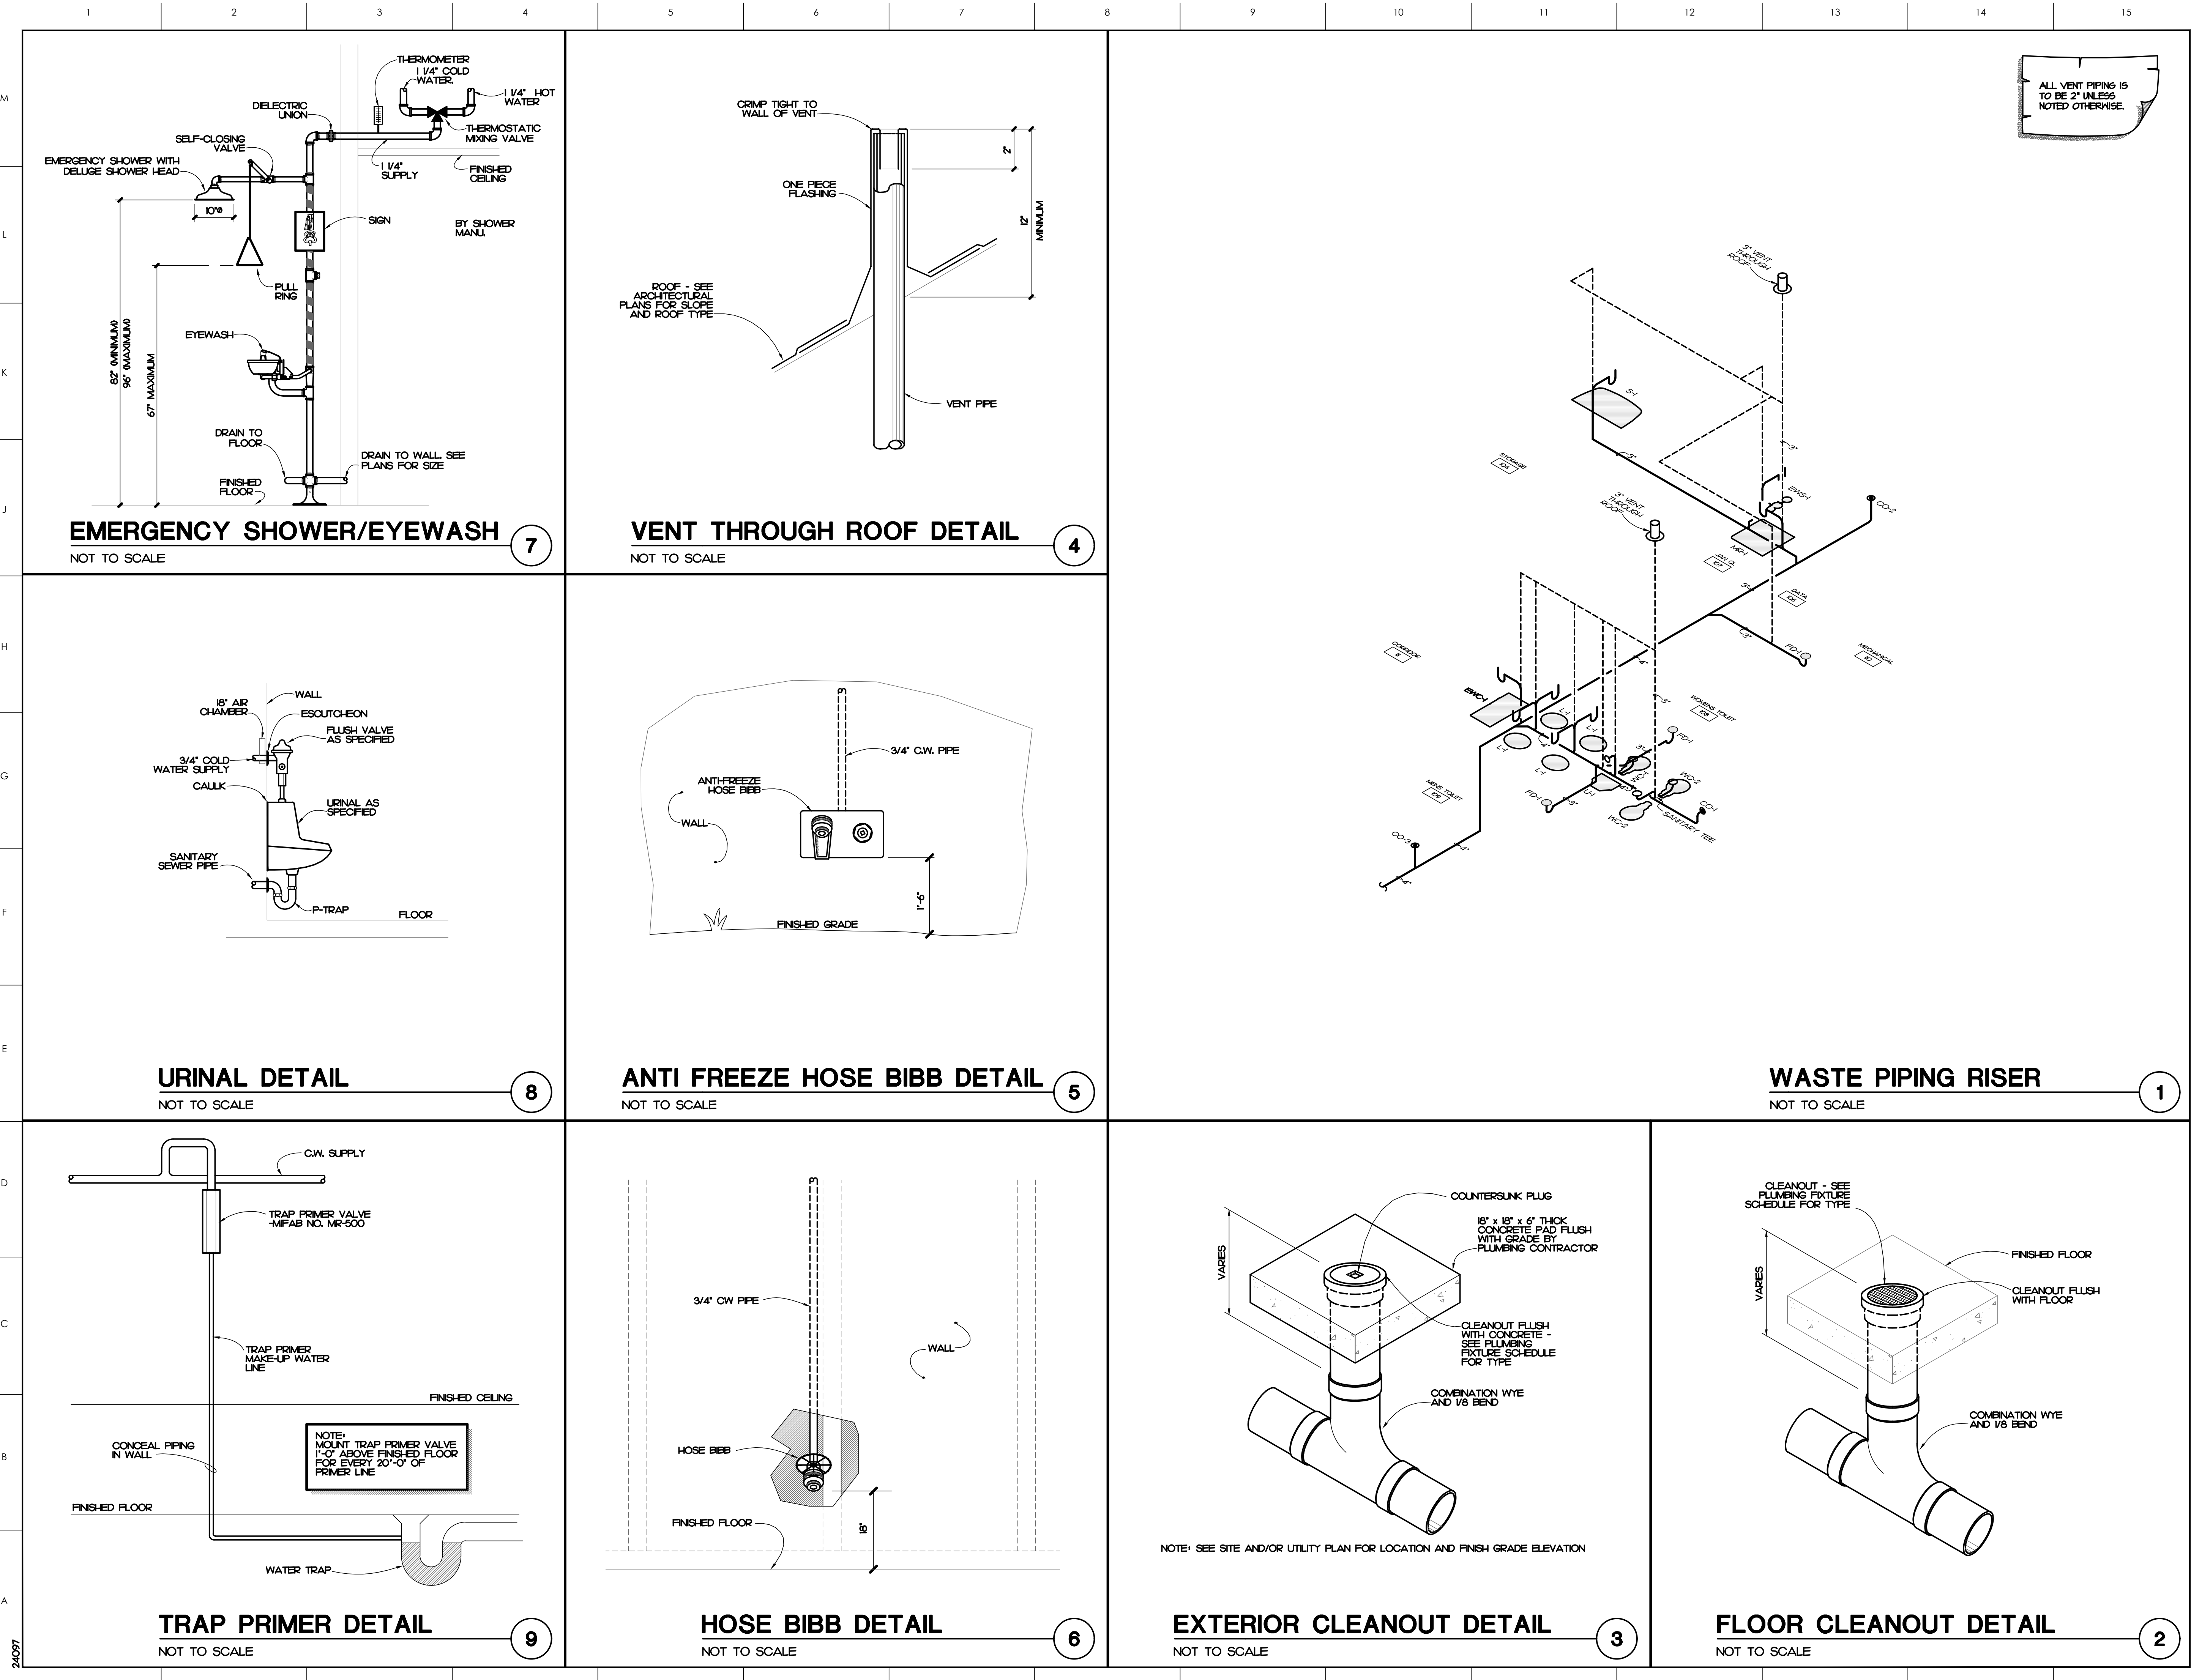

ATLANTECENGINEERS, P.A.

now

IMEG

322 BLUE RIDGE ROAD, SUITE 105
RALEIGH, NC 27602
240977

SEAL

STATE OF NORTH CAROLINA
IMEG CONSULTANTS
CORP.
No. T-1507
PROFESSIONAL CORPORATION

SEAL

STATE OF NORTH CAROLINA
ENGINEER
JAMES B. DELPAPP JR.
No. 22035
PROFESSIONAL CORPORATION

1/22/25

GENERAL NOTES

KEY PLAN

SCO# 23-2704401A

NO	REVISION	DATE

JKF

ARCHITECTURE

625 LYNDDALE CT., SUITE F, GREENVILLE, NC 27858 252-355-1068

BEAUFORT COUNTY
COMMUNITY COLLEGE
INDUSTRIAL TRAINING CENTER
AURORA, NC

DRAWING TITLE
PLUMBING DETAILS AND WASTE RISER

SCALE
NOT TO SCALE

DRAWN
DRD

CHECKED
JBD

DATE
01-06-2025

PROJECT NO.
2024-10

DRAWING NO.
P3.1

© COPYRIGHT, JKF ARCHITECTURE PC, JOHN K. FARRAS, AIA

NOT TO SCALE



NOT TO SCALE



NOT TO SCALE



NOT TO SCALE



NOT TO SCALE



J K F
ARCHITECTURE

625 LYNNDAL CT., SUITE F, GREENVILLE, NC 27858 252-355-1068

BEAUFORT COUNTY
COMMUNITY COLLEGE
INDUSTRIAL TRAINING CENTER
AURORA, NC

DRAWING TITLE

PLUMBING DETAILS

SCALE NOT TO SCALE

DRAWN	DED
-------	-----

CHECKED	BD
---------	----

DATE _____

PROJECT NO.	01002025
-------------	----------

P3.2

NOT TO SCALE

NOT TO SCALE

NOT TO SCALE

NOT TO SCALE

NOT TO SCALE

NOT TO SCALE

NOT TO SCALE



NOT TO SCALE

NOT TO SCALE

NOT TO SCALE

NOT TO SCALE

NOT TO SCALE

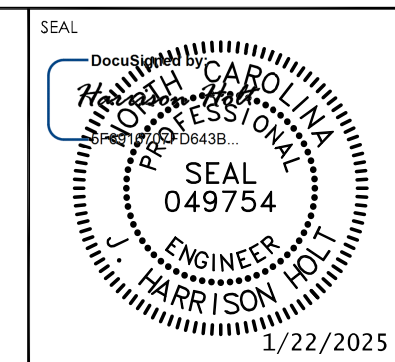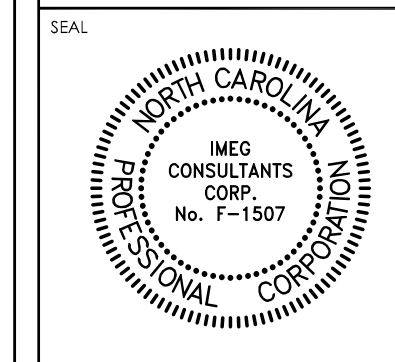

GENERAL NOTES

KEY PLAN

SCO# 23-2704401A

NO	REVISION	DATE
----	----------	------

JKF
ARCHITECTURE

625 LYNDALE CT., SUITE F, GREENVILLE, NC 27858 252-355-1068

BEAUFORT COUNTY
COMMUNITY COLLEGE
INDUSTRIAL TRAINING CENTER
AURORA, NC

DRAWING TITLE

MECHANICAL DETAILS

SCALE	DRAWING NO.
NOT TO SCALE	
DRAWN	JH
CHECKED	JB
DATE	M2.1
PROJECT NO.	
2024-10	

1	2	3	4	5	6	7	8	9	10	11	12	13	14	15															
															ATLANTECENGINEERS, PA nowIMEG 3228 BLUE RIDGE ROAD, SUITE 103 RALEIGH, NC 27602 919 571-1111 24097 SEAL IMEGCONSULTANTS CORP. No. F-1507 NORTH CAROLINA PROFESSIONAL CORPORATION SEAL <i>Allen F. Farris</i> IMEGCONSULTANTS CORP. No. F-1507 NORTH CAROLINA PROFESSIONAL CORPORATION														

LIGHT FIXTURE SCHEDULE				
TYPE	DESCRIPTION	CATALOG	ELECTRICAL DATA	NOTES
A30	2x2 LED DIRECT/INDIRECT FIXTURE RECESSED MOUNTED PERFORATED DIRECT LIGHT SHIELD 3000 LUMEN	LITHONIA: 2AVL2-30LSE-MDR-GZIO-LP840 COLUMBIA LIGHTING: EQUAL ORACLE LIGHTING: EQUAL	3000 LUMEN LED, 4000K 0-10V ELECTRONIC DIMMING DRIVER 34 WATTS - 37 VA, 120-277V	
A40	2x2 LED DIRECT/INDIRECT FIXTURE RECESSED MOUNTED PERFORATED DIRECT LIGHT SHIELD 4000 LUMEN	LITHONIA: 2AVL2-40LSE-MDR-GZIO-LP840 COLUMBIA LIGHTING: EQUAL ORACLE LIGHTING: EQUAL	4000 LUMEN LED, 4000K 0-10V ELECTRONIC DIMMING DRIVER 48 WATTS - 53 VA, 120-277V	
A40/EM	2x2 LED DIRECT/INDIRECT FIXTURE RECESSED MOUNTED PERFORATED DIRECT LIGHT SHIELD 4000 LUMEN WITH EMERGENCY BATTERY BACKUP	LITHONIA: 2AVL2-40LSE-MDR-GZIO-LP840-ELJ4L COLUMBIA LIGHTING: EQUAL ORACLE LIGHTING: EQUAL	4000 LUMEN LED, 4000K 0-10V ELECTRONIC DIMMING DRIVER 48 WATTS - 53 VA, 120-277V	
B	ROUND H-BAY LED FIXTURE CLEAR ACRYLIC REFLECTOR, NO LENS PENDANT MOUNTED 12000 LUMEN	LITHONIA: JCSL-12000LM-ACCR-MVOLT-GZIO-40K- -80CRI-*** CREE LIGHTING: EQUAL HUBBELL LIGHTING: EQUAL	12000 LUMEN LED, 4000K 0-10V ELECTRONIC DIMMING DRIVER 84 WATTS, 120-277V	*** FIELD VERIFY MOUNTING HARDWARE WITH ARCHITECT MOUNT BOTTOM 16 FT. AFF. PROVIDE METAL ROD OR CONDUIT TO HANG FROM ROOF DECK.
C	47" ARCHITECTURAL LED WALL MOUNTED FIXTURE UP/DOWN ASYMMETRICAL DISTRIBUTION 2300 TOTAL DELIVERED LUMEN	VISA: CV176-L40K10-MVOLT-** PRUDENTIAL: EQUAL CORONET: EQUAL	2300 TOTAL DELIVERED LUMEN LED, 4000K 0-10V ELECTRONIC DIMMING DRIVER 32 WATTS - 36 VA, 120-277V	MOUNT TOP OF FIXTURE 8" AFF. FIELD VERIFY WITH ARCHITECT.
C/EM	SAME AS TYPE C EXCEPT FIXTURE TO BE USED AS AN EMERGENCY LIGHT.	VISA: CV176-L40K10-MVOLT-** PRUDENTIAL: EQUAL CORONET: EQUAL	2300 TOTAL DELIVERED LUMEN LED, 4000K 0-10V ELECTRONIC DIMMING DRIVER 32 WATTS - 36 VA, 120-277V	MOUNT TOP OF FIXTURE 8" AFF. FIELD VERIFY WITH ARCHITECT. WHERE INDICATED FOR USE AS AN EMERGENCY LIGHT, PROVIDE WITH EMERGENCY LIGHTING INVERTER, TOTAL IS-501 OR EQUAL BY DUAL-LITE, MYERS, ACUTY, EELP
D	6" LED CAN RECESSED MOUNTED, FLANGED DOWNLIGHT TRIM MEDIUM WIDE DISTRIBUTION (S2) 2000 LUMEN	MAXILLUME: L44-LED-2000L-DIM10-MWD-40K-90- L44-6501 GOTHAM: EQUAL PRESCOLITE: EQUAL	2000 LUMEN LED, 4000K 0-10V ELECTRONIC DIMMING DRIVER 20 WATTS - 23 VA, 120-277V	
F/EM	LED FIXTURE MOUNTED SURFACE MOUNTED 2400 LUMEN WET LOCATION LISTED EMERGENCY BATTERY BACKUP	GARDCO: SVPS-A01-840-TIR-SUR-120V-EM GOTHAM: EQUAL PRESCOLITE: EQUAL	2000 LUMEN LED, 4000K 0-10V ELECTRONIC DIMMING DRIVER 21 WATTS, 120-277V	
G	1 LED POLE LIGHT 4000K, 18000 LUMENS 20 FT. STEEL ROUND POLE TO MATCH ADJUSTABLE ARM MOUNT PHOTOCELL	GARDCO: P26-A03-840-T4M--ARH20V-0-10V-PCB LITHONIA LIGHTING: EQUAL COLUMBIA LIGHTING: EQUAL	18000 LUMEN LED, 4000K 0-10V ELECTRONIC DIMMING DRIVER 103 WATTS, 120V	** FINISH COLOR PER ARCHITECT INSTRUCTION. ORDER WITH 4" ROUND STRAIGHT STEEL POLE. CONFIRM POLE FOR 140MPH EPA. GARDCO:SR5-GB-4-F-20 ATLAS: EQUAL LITHONIA: EQUAL
S4	4 FT. LED STRIP LIGHT PENDANT OR SURFACE MOUNTED 4000 LUMEN	LITHONIA: CSS-L48-4000LM-MVOLT-40K-80CRI COLUMBIA LIGHTING: EQUAL ORACLE LIGHTING: EQUAL	4000 LUMEN LED, 4000K 0-10V ELECTRONIC DIMMING DRIVER 36 WATTS - 40 VA, 120-277V	
PI	8 FT. VAPOR TIGHT LED FIXTURE POLYCARBONATE FROSTED LENS PENDANT MOUNTED LISTED FOR WET LOCATION, IP66 AND -20F TO 120F 9000 LUMEN, MEDIUM DISTRIBUTION	LITHONIA: FEM-L96-9000LM-LPFL-MD-MVOLT -GZIO-40K-80CRI-DPMB COLUMBIA LIGHTING: EQUAL ORACLE LIGHTING: EQUAL	9000 LUMEN LED, 4000K 0-10V ELECTRONIC DIMMING DRIVER 53.4 WATTS, 120-277V	
W	EXTERIOR WALL MOUNTED CUT-OFF TRAPEZOIDAL SHAPE 2944 LUMEN LISTED FOR WET LOCATION AND OF	GARDCO: JOL-XL-530-NW-GH-2-UNV HUBBELL LIGHTING: EQUAL NLS: EQUAL	2944 LUMEN LED, 4000K ELECTRONIC DRIVER 28 WATTS, 120-277V	** FINISH COLOR PER ARCHITECT INSTRUCTION. MOUNT APPROX. 12" AFF. SEE ARCHITECTURAL ELEVATION FOR LOCATION AND HEIGHT.
W/EM	EXTERIOR WALL MOUNTED CUT-OFF TRAPEZOIDAL SHAPE 2944 LUMEN LISTED FOR WET LOCATION AND OF WITH EMERGENCY BATTERY BACKUP	GARDCO: JOL-XL-530-NW-GH-2-EBPC-UNV HUBBELL LIGHTING: EQUAL NLS: EQUAL	2944 LUMEN LED, 4000K ELECTRONIC DRIVER 28 WATTS, 120-277V	** FINISH COLOR PER ARCHITECT INSTRUCTION. MOUNT APPROX. 12" AFF. SEE ARCHITECTURAL ELEVATION FOR LOCATION AND HEIGHT.
EGX	EMERGENCY WITH EXIT LIGHT 1 SIDE GREEN LETTER	LITHONIA: LHQM-LED-G MAXILLUME: EQUAL DUAL-LITE: EQUAL	(2) 15W LED HEADS, LED FOR PANEL 4.3 WATTS - 11 VA, 120/277V	
EG	EMERGENCY LIGHT 220 LUMEN TOTAL	LITHONIA: ELM2-L-M2 MAXILLUME: EQUAL DUAL-LITE: EQUAL	(2) 12W LED HEADS 1 WATTS - 5 VA, 120-277V	

ATLANTEC
ENGINEERS, P.A.
now
IMEG
320 BLUE RIDGE ROAD, SUITE 10
RALEIGH, NC 27602
919 571-1111
24097

SEAL

SEAL

GENERAL NOTES

KEY PLAN

SCO# 23-2704401A

NO	REVISION	DATE

J K F
ARCHITECTURE

625 LYNNDALE CT., SUITE F, GREENVILLE, NC 27858 252-355-1068

BEAUFORT COUNTY
COMMUNITY COLLEGE
INDUSTRIAL TRAINING CENTER
AURORA, NC

DRAWING TITLE

LIGHT FIXTURE SCHEDULE

SCALE

NOT TO SCALE

DRAWN

AB

CHECKED

AB

DATE

01-06-2025



PROJECT NO.

2024-10

DRAWING NO

EO.2

© COPYRIGHT, JKF ARCHITECTURE PC, JOHN K. FARRAS, AIA

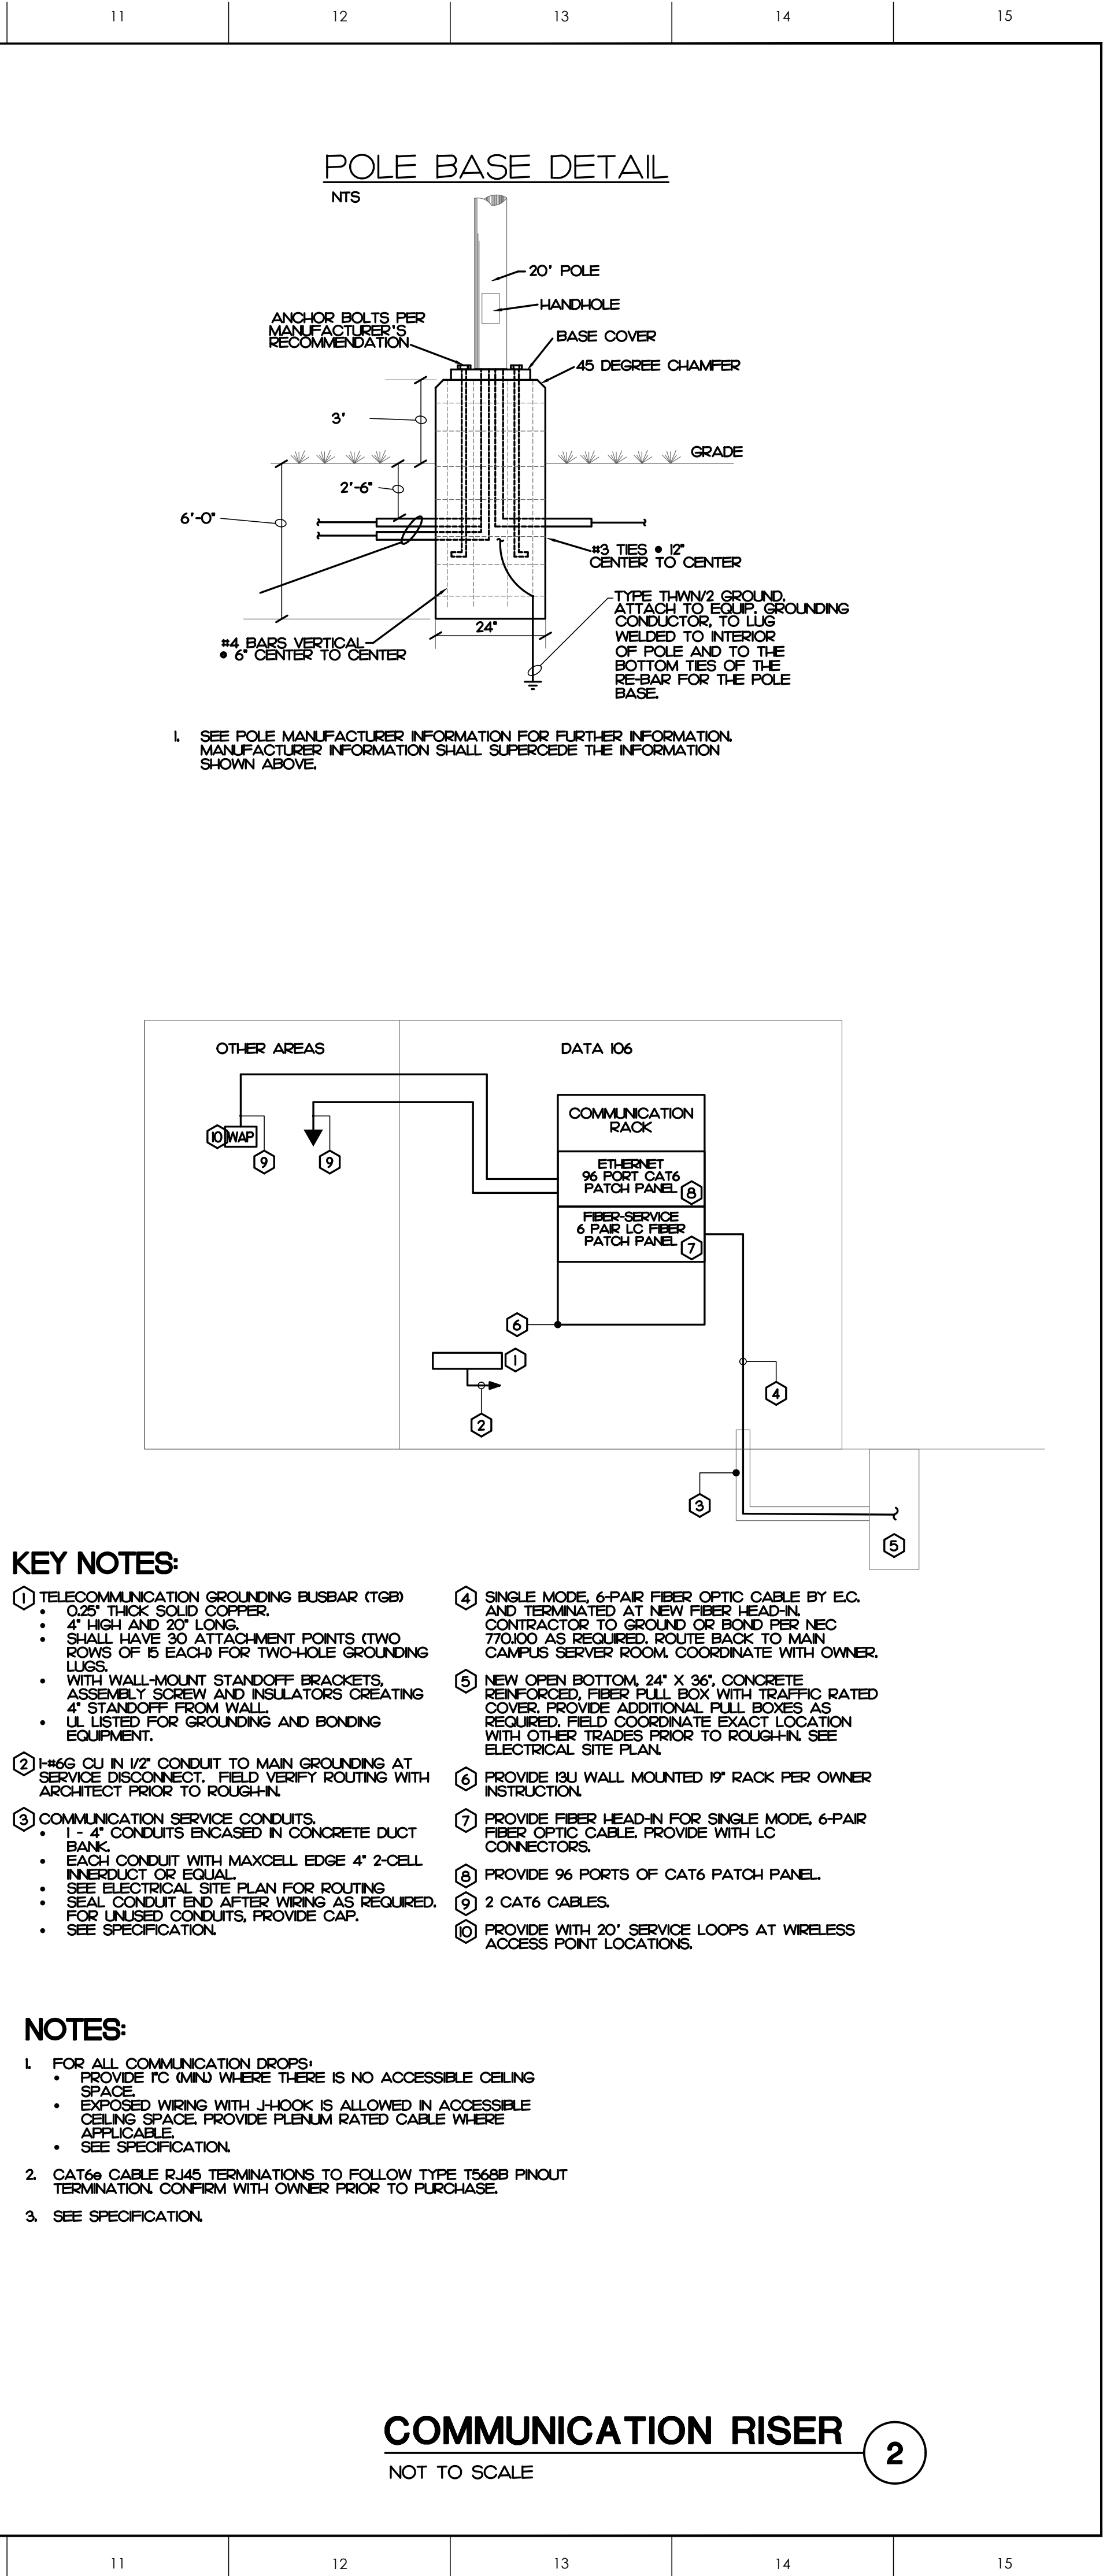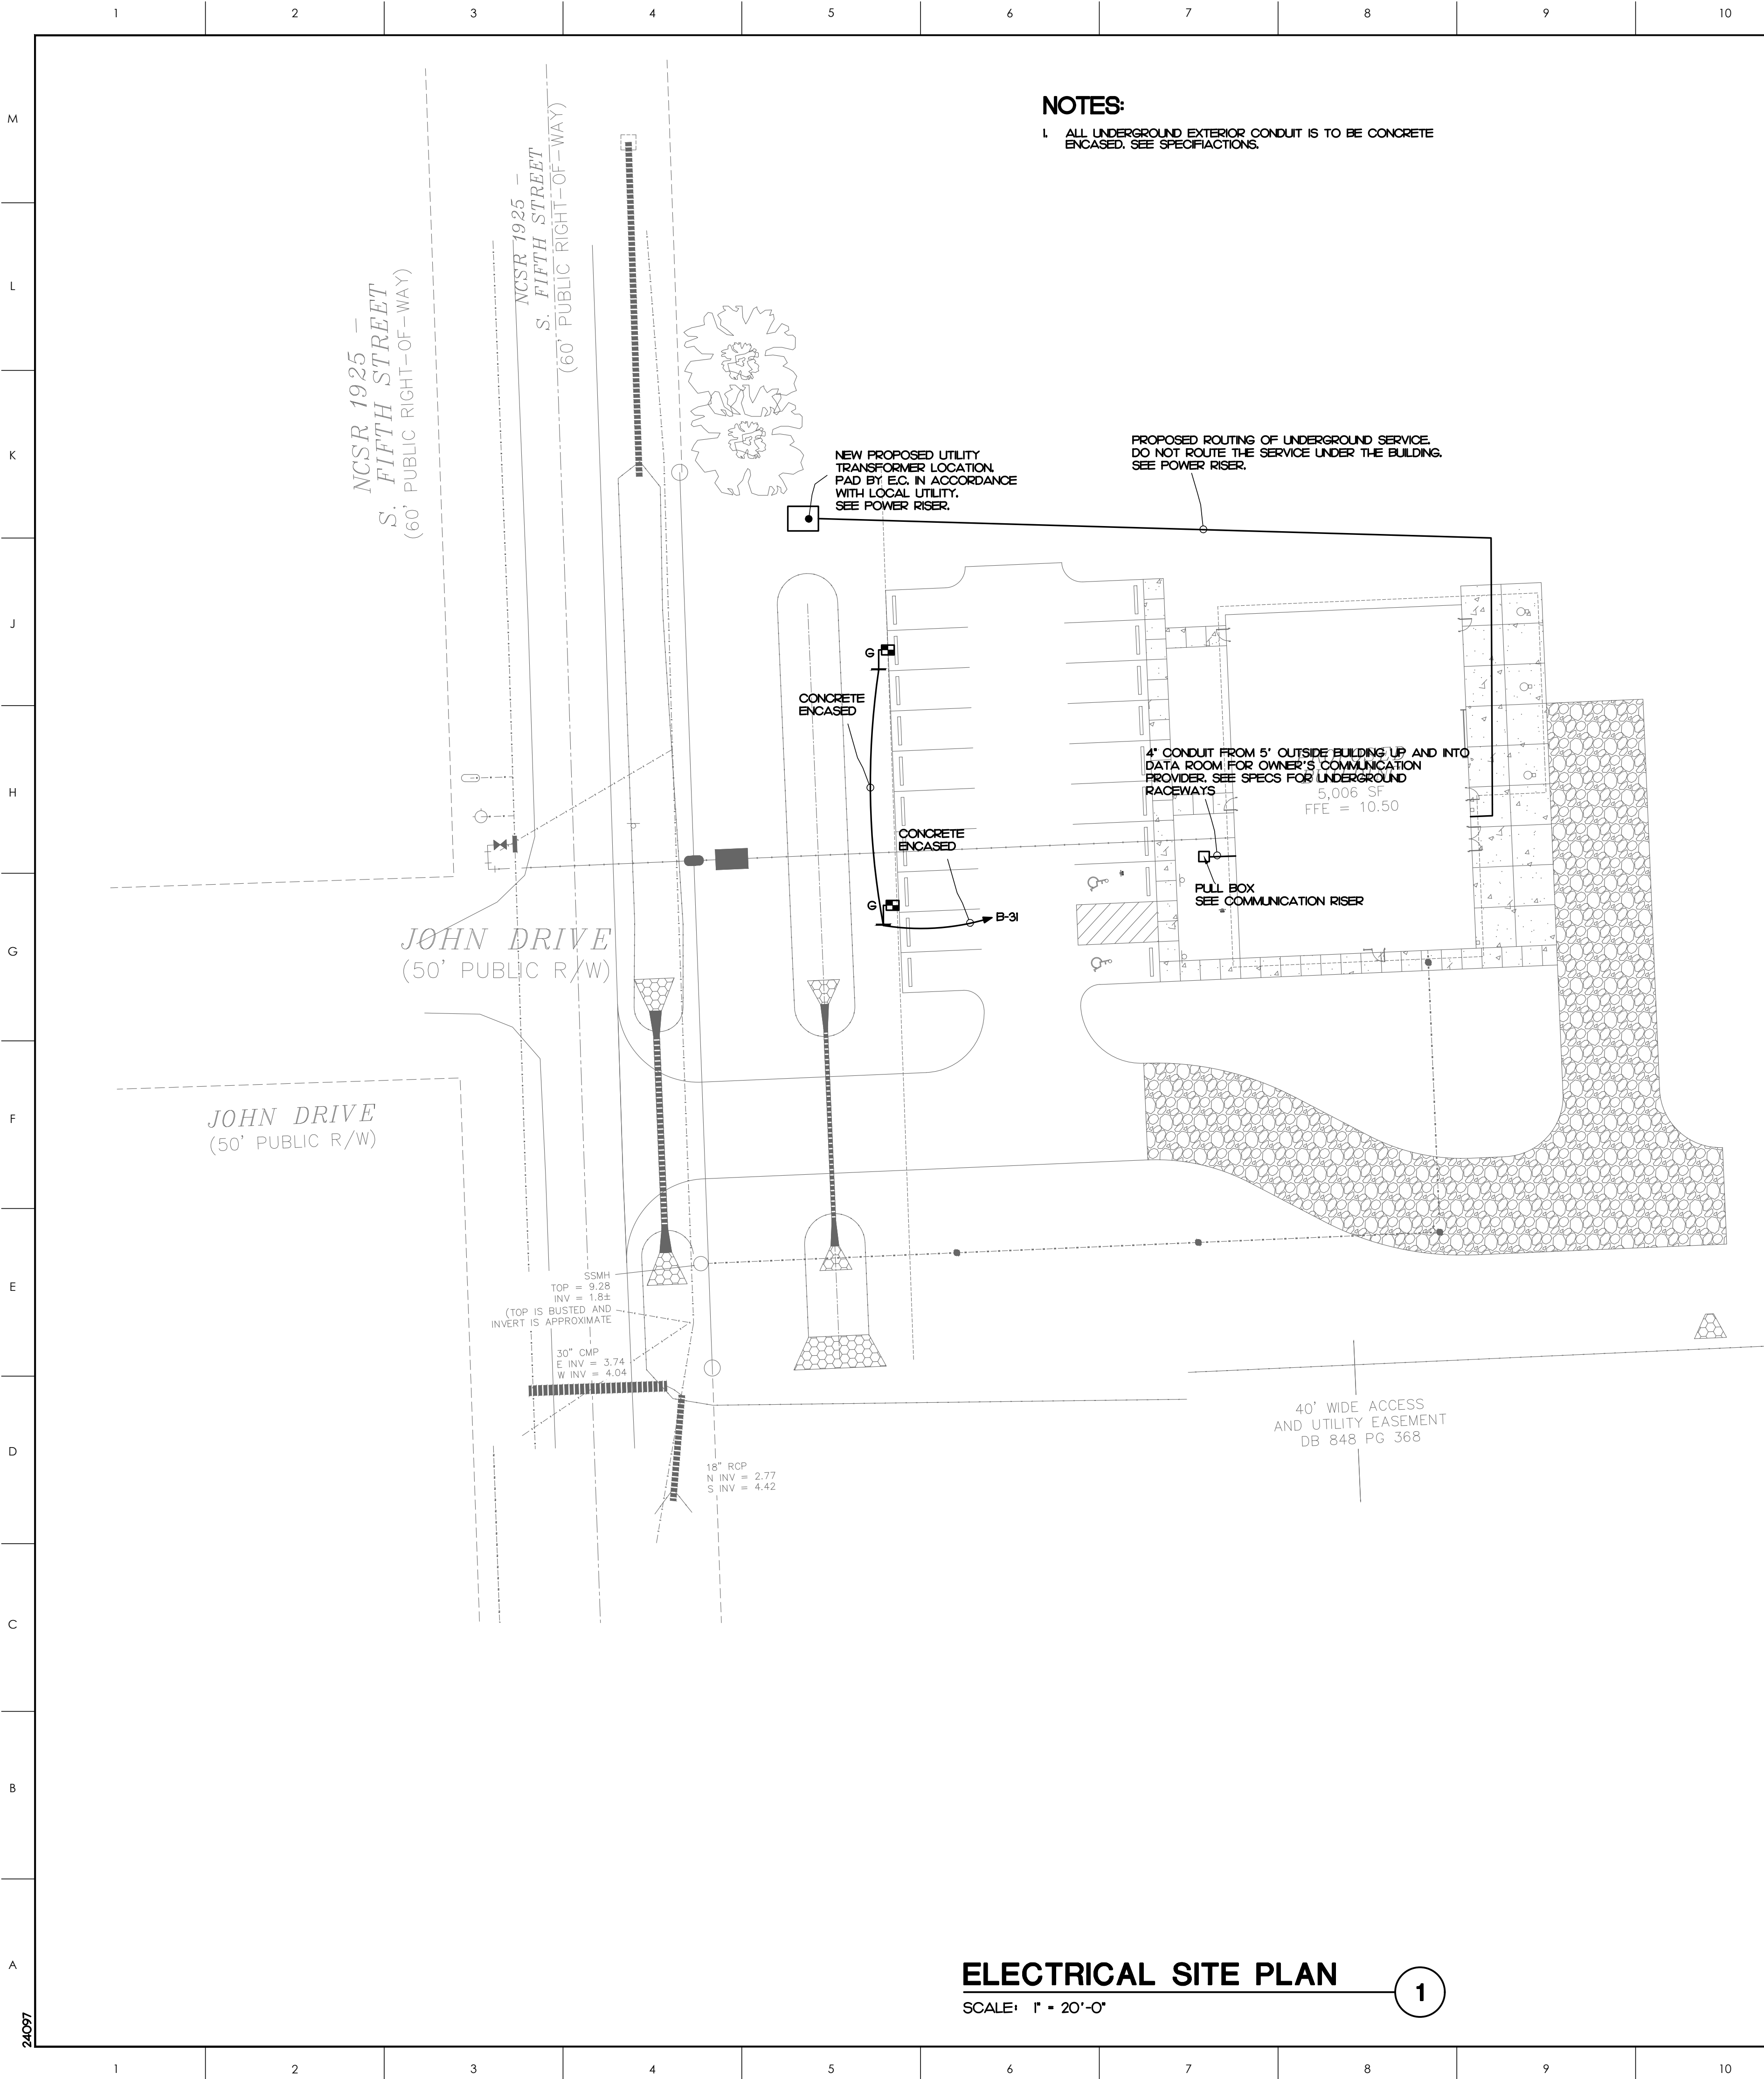

ATLANTEC
ENGINEERS, PA
now **IMEG**
320 BLUE RIDGE ROAD, SUITE 15
RALEIGH, NC 27602
24097

SEAL
NORTH CAROLINA
CONSULTANTS
CORP.
No. F-1507
PROFESSIONAL CORPORATION

SEAL
NORTH CAROLINA
PROFESSIONAL
ENGINEER
WILLIAM S. BOWLING
1/24/2025

GENERAL NOTES

KEY PLAN

SCO# 23-2704401A

NO	REVISION	DATE

J K F
ARCHITECTURE


625 LYNNDALE CT., SUITE F, GREENVILLE, NC 27858 252-355-1068


**BEAUFORT COUNTY
COMMUNITY COLLEGE
INDUSTRIAL TRAINING CENTER**
AURORA, NC

DRAWING TITLE
ELECTRICAL SITE PLAN

SCALE	DRAWING NO.
1/8" = 1'-0"	EI.O
DRAWN AB	
CHECKED AB	
DATE 01-06-2025	
PROJECT NO. 2024-10	

© COPYRIGHT, JKF ARCHITECTURE PC, JOHN K. FARRAS, AIA

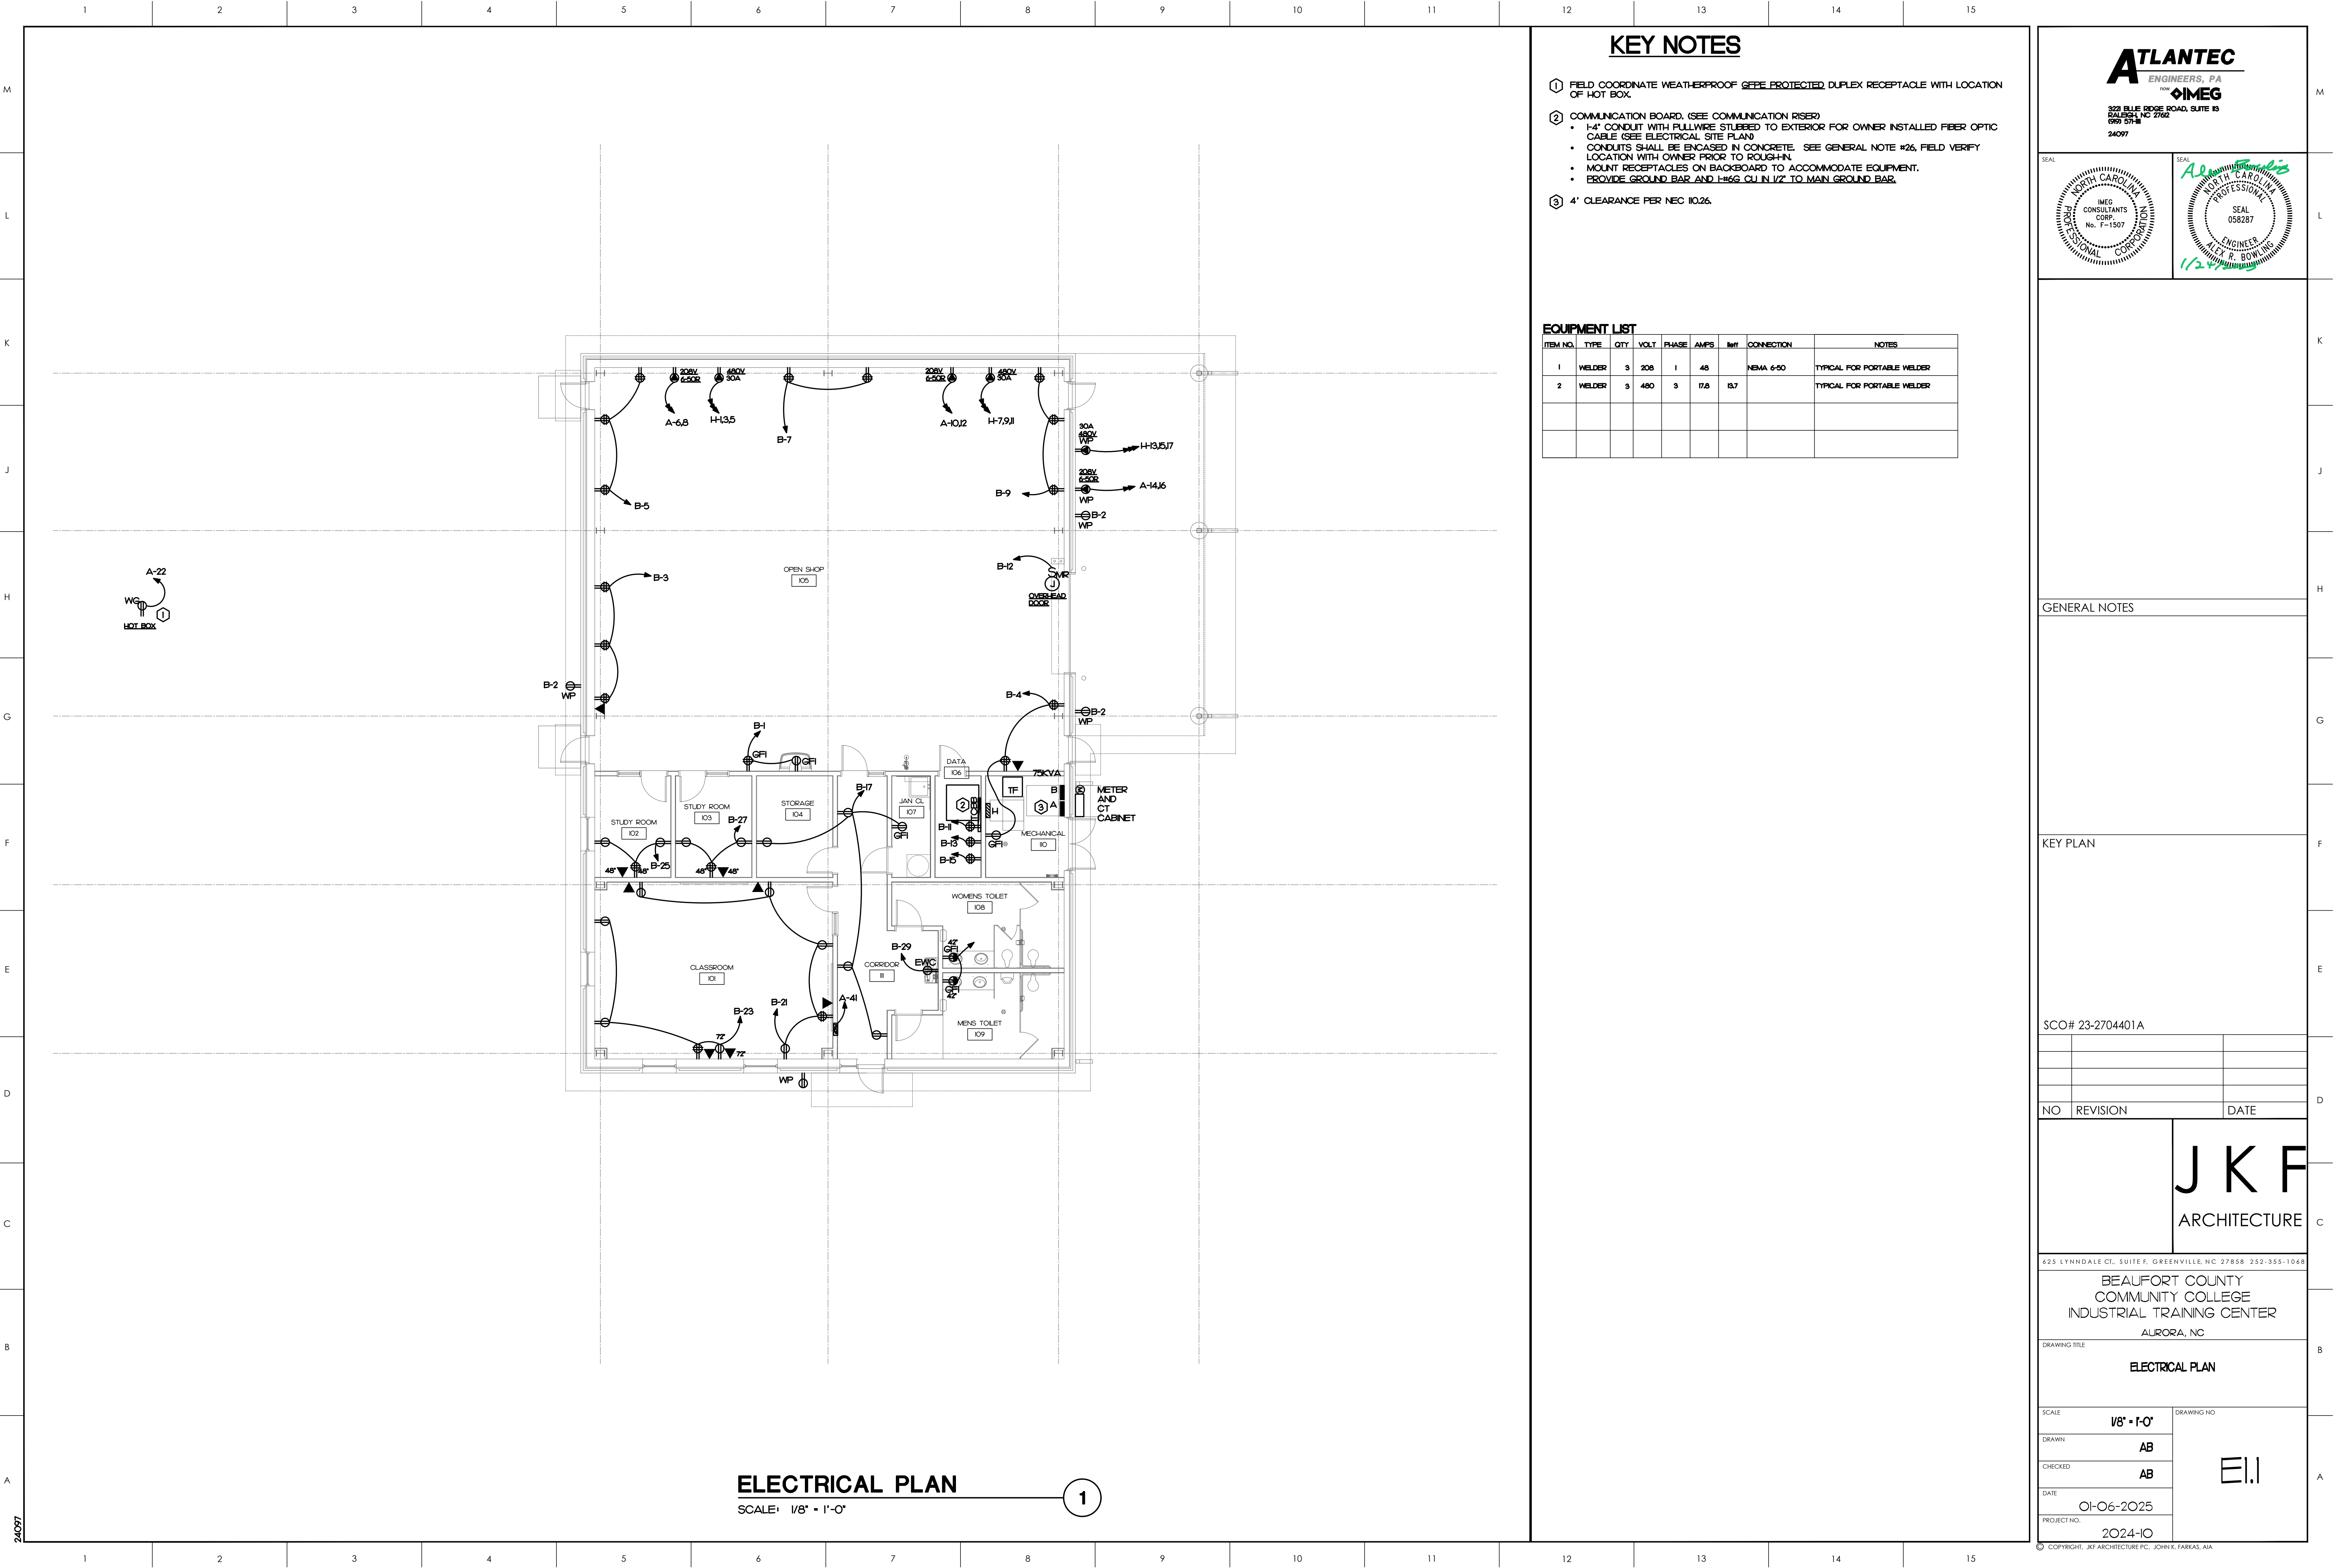

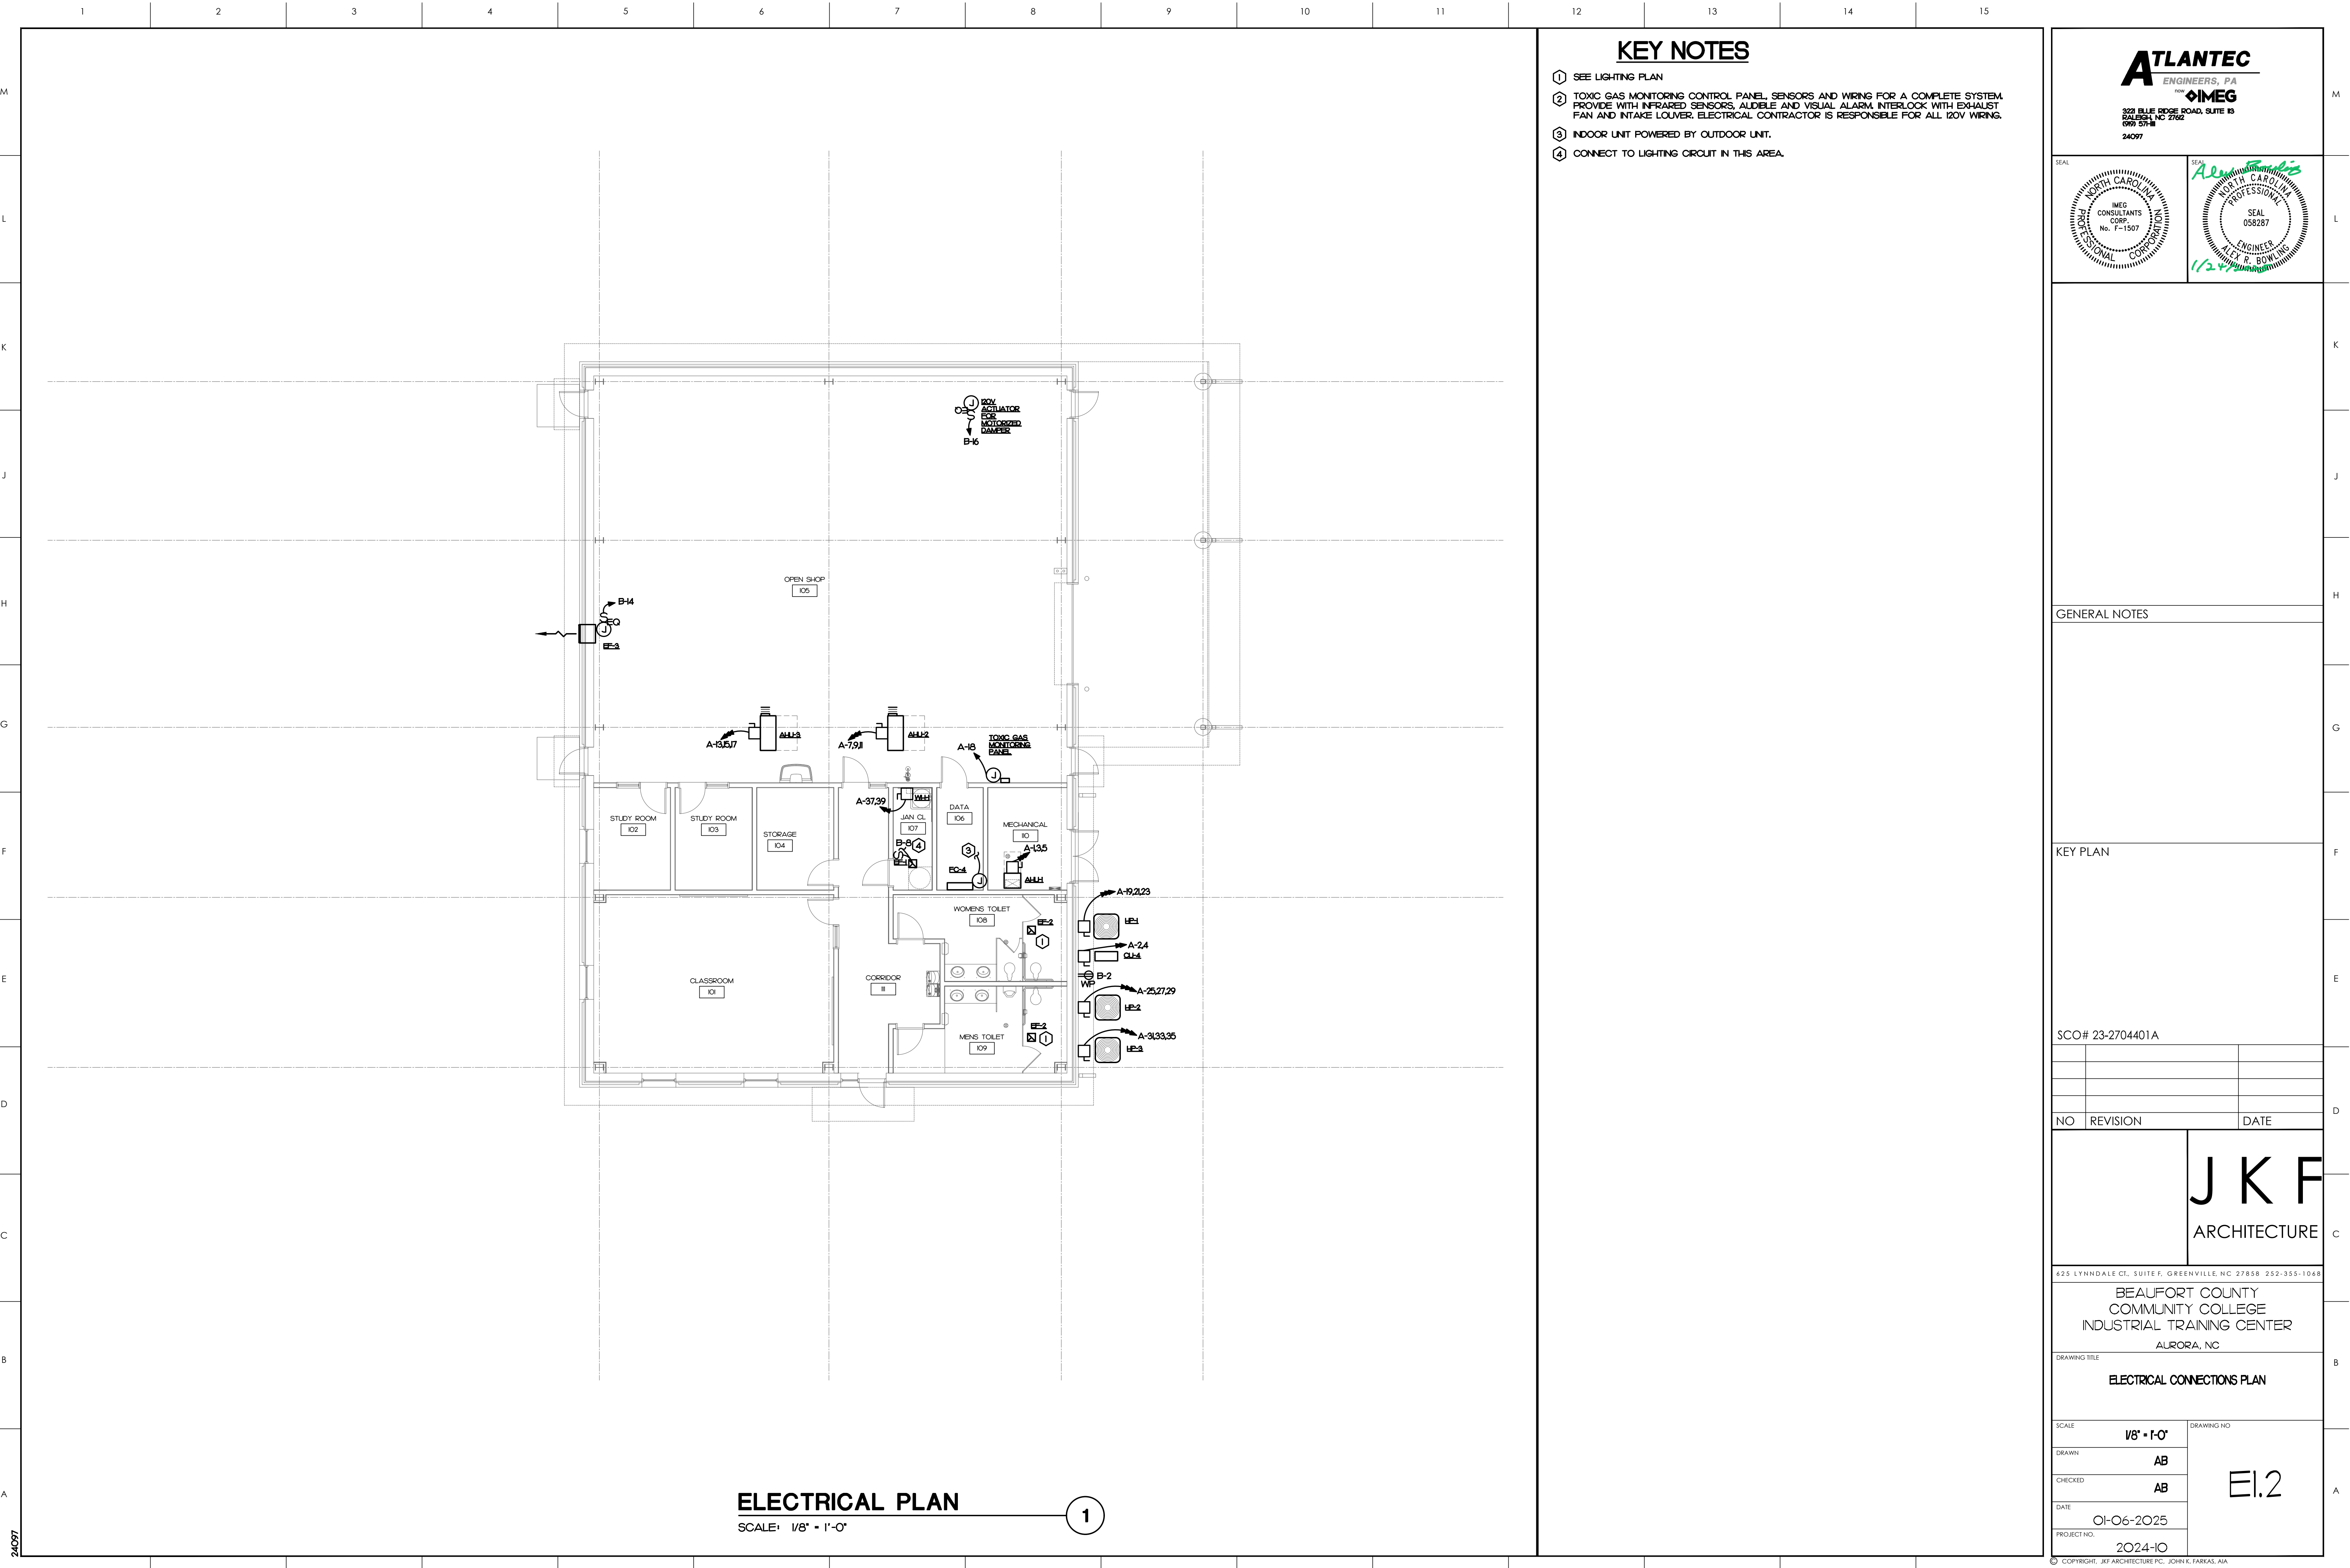


KEY NOTES

- SEE LIGHTING PLAN
- TOXIC GAS MONITORING CONTROL PANEL, SENSORS AND WIRING FOR A COMPLETE SYSTEM. PROVIDE WITH INFRARED SENSORS, ALARMS AND VISUAL ALARM. INTERLOCK WITH EXHAUST FAN AND INTAKE LOUVER. ELECTRICAL CONTRACTOR IS RESPONSIBLE FOR ALL 120V WIRING.
- INDOOR UNIT POWERED BY OUTDOOR UNIT.
- CONNECT TO LIGHTING CIRCUIT IN THIS AREA.

ATLANTEC
ENGINEERS, P.A.

now **IMEG**
322 BLUE RIDGE ROAD, SUITE 10
BALDWIN, NC 27602
240977

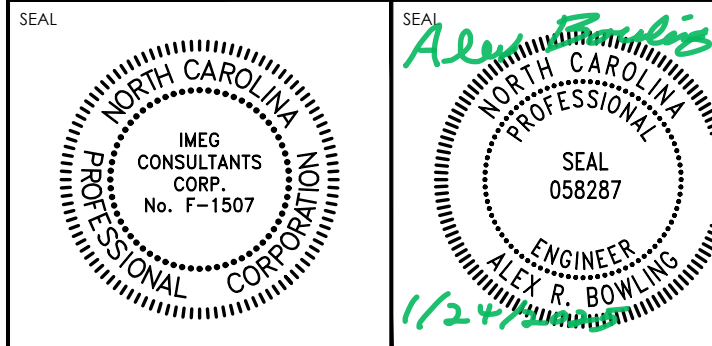

GENERAL NOTES

KEY PLAN

SCO# 23-2704401A

NO	REVISION	DATE
----	----------	------

J K F
ARCHITECTURE

625 LYNNDALE CT., SUITE F, GREENVILLE, NC 27858 252-355-1068

BEAUFORT COUNTY
COMMUNITY COLLEGE
INDUSTRIAL TRAINING CENTER
AURORA, NC

DRAWING TITLE
ELECTRICAL CONNECTIONS PLAN

SCALE

1/8" = 1'-0"

DRAWN

AB

CHECKED

AB

DATE


01-06-2025

PROJECT NO.

2024-10

EI.2

© COPYRIGHT, JKF ARCHITECTURE PC, JOHN K. FARRAS, AIA

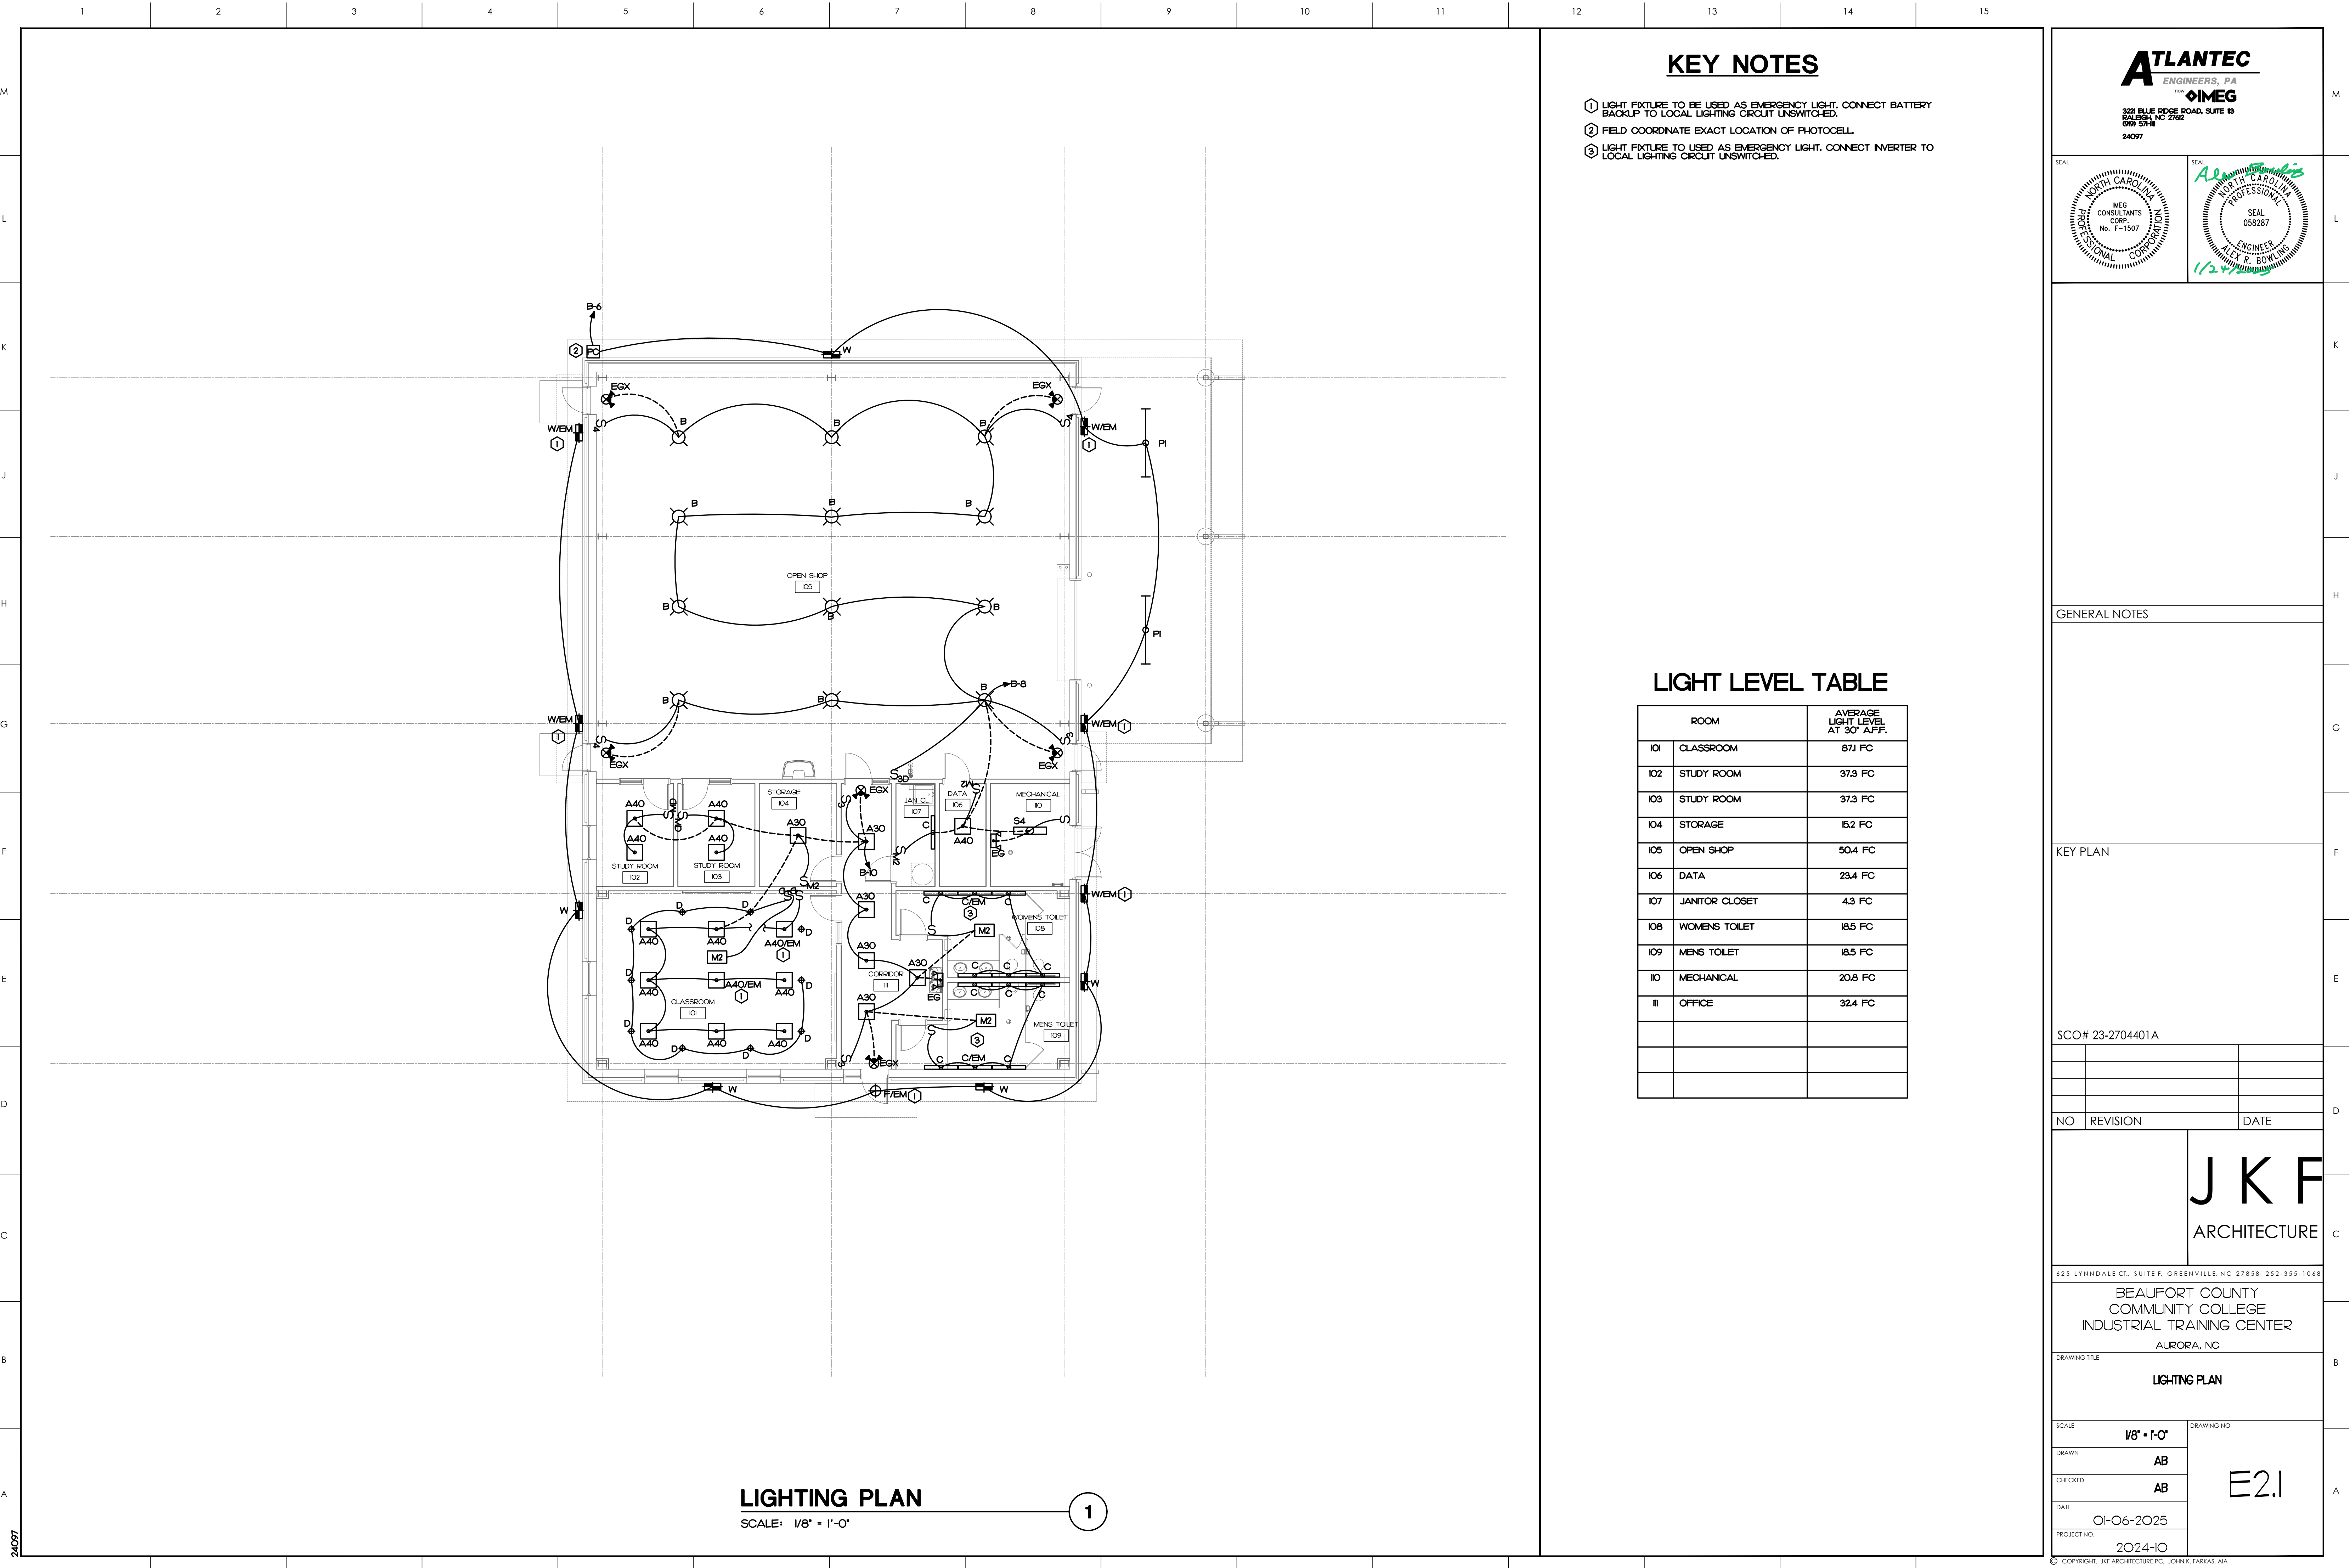


KEY NOTES

- 1 LIGHT FIXTURE TO BE USED AS EMERGENCY LIGHT. CONNECT BATTERY BACKUP TO LOCAL LIGHTING CIRCUIT UNSWITCHED.
- 2 FIELD COORDINATE EXACT LOCATION OF PHOTOCELL.
- 3 LIGHT FIXTURE TO BE USED AS EMERGENCY LIGHT. CONNECT INVERTER TO LOCAL LIGHTING CIRCUIT UNSWITCHED.

LIGHT LEVEL TABLE

ROOM	AVERAGE LIGHT LEVEL AT 30" AFF.
101 CLASSROOM	871 FC
102 STUDY ROOM	37.3 FC
103 STUDY ROOM	37.3 FC
104 STORAGE	15.2 FC
105 OPEN SHOP	50.4 FC
106 DATA	23.4 FC
107 JANITOR CLOSET	4.3 FC
108 WOMENS TOILET	18.5 FC
109 MENS TOILET	18.5 FC
110 MECHANICAL	20.8 FC
111 OFFICE	32.4 FC

ATLANTEC
ENGINEERS, PA
now **IMEG**
320 BLUE RIDGE ROAD, SUITE 10
RALEIGH, NC 27602
919 571-1111
24097

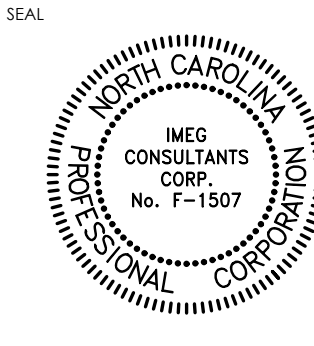

GENERAL NOTES

KEY PLAN

SCO# 23-2704401A

NO	REVISION	DATE

J K F
ARCHITECTURE

625 LYNNDALE CT., SUITE F, GREENVILLE, NC 27858 252-355-1068

BEAUFORT COUNTY
COMMUNITY COLLEGE
INDUSTRIAL TRAINING CENTER
AURORA, NC

DRAWING TITLE
LIGHTING PLAN

SCALE
1/8" = 1'-0"

DRAWN
AB

CHECKED
AB

DATE
01-06-2025

PROJECT NO.
2024-10

E2.1





PANEL H

PANEL H										277/480V, 3 PHASE, 4 WIRE														
CKT	DESCRIPTION								KVA	C	G	W	CB	CKT		CKT	CB	W	G	C	KVA		DESCRIPTION	CKT
1	WELDER		3.8	3/4	10	10	30	1								2	--	--	--	--	0.0		SPACE ONLY	2
3	MOBILE		3.8	--	--	--	10	3P	3							4	--	--	--	--	0.0		SPACE ONLY	4
5			3.8	--	--	--	10	--	5							6	--	--	--	--	0.0		SPACE ONLY	6
7	WELDER		3.8	3/4	10	10	30	7								8	--	--	--	--	0.0		SPACE ONLY	8
9	MOBILE		3.8	--	--	--	10	3P	9							10	--	--	--	--	0.0		SPACE ONLY	10
11			3.8	--	--	--	10	--	11							12	--	--	--	--	0.0		SPACE ONLY	12
13	WELDER	NOTE 2	3.8	3/4	10	10	30	13								14	--	--	--	--	0.0		SPACE ONLY	14
15	MOBILE		3.8	--	--	--	10	3P	15							16	--	--	--	--	0.0		SPACE ONLY	16
17			3.8	--	--	--	10	--	17							18	--	--	--	--	0.0		SPACE ONLY	18
19	SPACE ONLY		0.0	--	--	--	--	--	19							20	--	--	--	--	0.0		SPACE ONLY	20
21	SPACE ONLY		0.0	--	--	--	--	21								22	--	--	--	--	0.0		SPACE ONLY	22
23	SPACE ONLY		0.0	--	--	--	--	23								24	--	--	--	--	0.0		SPACE ONLY	24
25	SPACE ONLY		0.0	--	--	--	--	25								26	--	--	--	--	0.0		SPACE ONLY	26
27	SPACE ONLY		0.0	--	--	--	--	27								28	--	--	--	--	0.0		SPACE ONLY	28
29	SPACE ONLY		0.0	--	--	--	--	29								30	--	--	--	--	0.0		SPACE ONLY	30
31	NA		0.0	--	--	--	--	31								32	--	--	--	--	0.0		NA	32
33	NA		0.0	--	--	--	--	33								34	--	--	--	--	0.0		NA	34
35	NA		0.0	--	--	--	--	35								36	--	--	--	--	0.0		NA	36
37	NA		0.0	--	--	--	--	37								38	--	--	--	--	0.0		NA	38
39	NA		0.0	--	--	--	--	39								40	--	--	--	--	0.0		NA	40
41	NA		0.0	--	--	--	--	41								42	--	--	--	--	0.0		NA	42

DESCRIPTION	CONNECTED KVA	DEMAND FACTOR	DEMAND KVA	100 A MINIMUM BUS SIZE 90 A MAIN CIRCUIT BREAKER 18 K MINIMUM AIC RATING	SURFACE MOUNTING NEMA 1 ENCLOSURE GROUND BAR
CONT. LOAD	0.00	125%	0.00		
RECTANGLE	0.00	100%/50%	0.00		
MTRS/COOLS	0.00	100%	0.00		
HEATS	0.00	100%	0.00		
WATER HEATER	0.00	100%	0.00	NOTES	CONNECTED LOADS
EQUIPMENT	0.00	100%	0.00		
KITCHEN EQUIP.	0.00	65%	0.00		
WELDER	34.17	NEC 630.11	53.52		
25% OF LARGEST HVAC/MOTOR			0.00		
TOTAL DEMAND			53.52	1. SEE SPECIFICATIONS	11.4 KVA
				2. PROVIDE WITH GFI BREAKER	11.4 KVA
				3.	11.4 KVA
				4.	34.2 KVA
				5.	TOTAL: 64 AMP

ATLANTEC
ENGINEERS, PA
now **IMEG**
3221 BLUE RIDGE ROAD, SUITE 103
RALEIGH, NC 27602
(919) 577-1111
24097

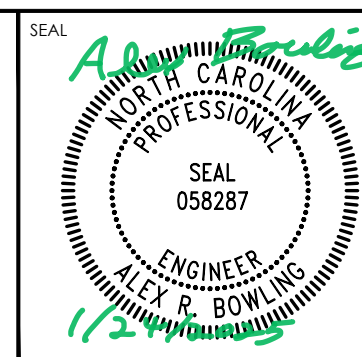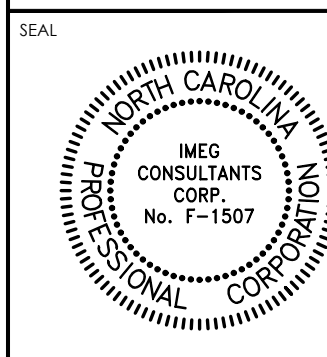

GENERAL NOTES

KEY PLAN

SCO# 23-2704401A

NO	REVISION	DATE

J K R
ARCHITECTUR

625 LYNNDAL CT., SUITE F, GREENVILLE, NC 27858 252-355-1000

BEAUFORT COUNTY
COMMUNITY COLLEGE
INDUSTRIAL TRAINING CENTER
AURORA, NC

POWER RISER AND PANEL SCHEDULES

SCALE NOT TO SCALE

DRAWN AE

CHECKED	DATE
---------	------

DATE 01.06.2025

PROJECT NO. 3034-IC

E3.

© COPYRIGHT, JKF ARCHITECTURE PC, JOHN K. FARKAS, AIA

SYMBOL LEGEND

- ②

SMOKE DETECTOR, PHOTOELECTRIC ADDRESSABLE

SEE SPECIFICATION
- F

FIRE ALARM PULL STATION, MOUNT 42" AFF. ADDRESSABLE

SEE SPECIFICATION
- ☒-XX

FIRE ALARM STROBE/HORN, MOUNT 80" AFF. 75 dBA SOUND LEVEL, "XX" INDICATES CANDELA RATING.

SEE SPECIFICATION
- ☒-XX

FIRE ALARM CEILING STROBE/HORN, 75 dBA SOUND LEVEL, "XX" INDICATES CANDELA RATING.

SEE SPECIFICATION
- FACP

FIRE ALARM CONTROL PANEL, FLUSH MOUNTED, ADDRESSABLE

SEE SPECIFICATION
- ☒-XX


FIRE ALARM CEILING STROBE, "XX" INDICATES CANDELA RATING.

SEE SPECIFICATION
- FCCELL

FIRE ALARM CELLULAR COMMUNICATOR WITH BATTERY BACKUP 2 PATH COMMUNICATIONS: CELLULAR AND P. INTERNET SURFACE MOUNTED.

SEE SPECIFICATION


FIRE ALARM RISER

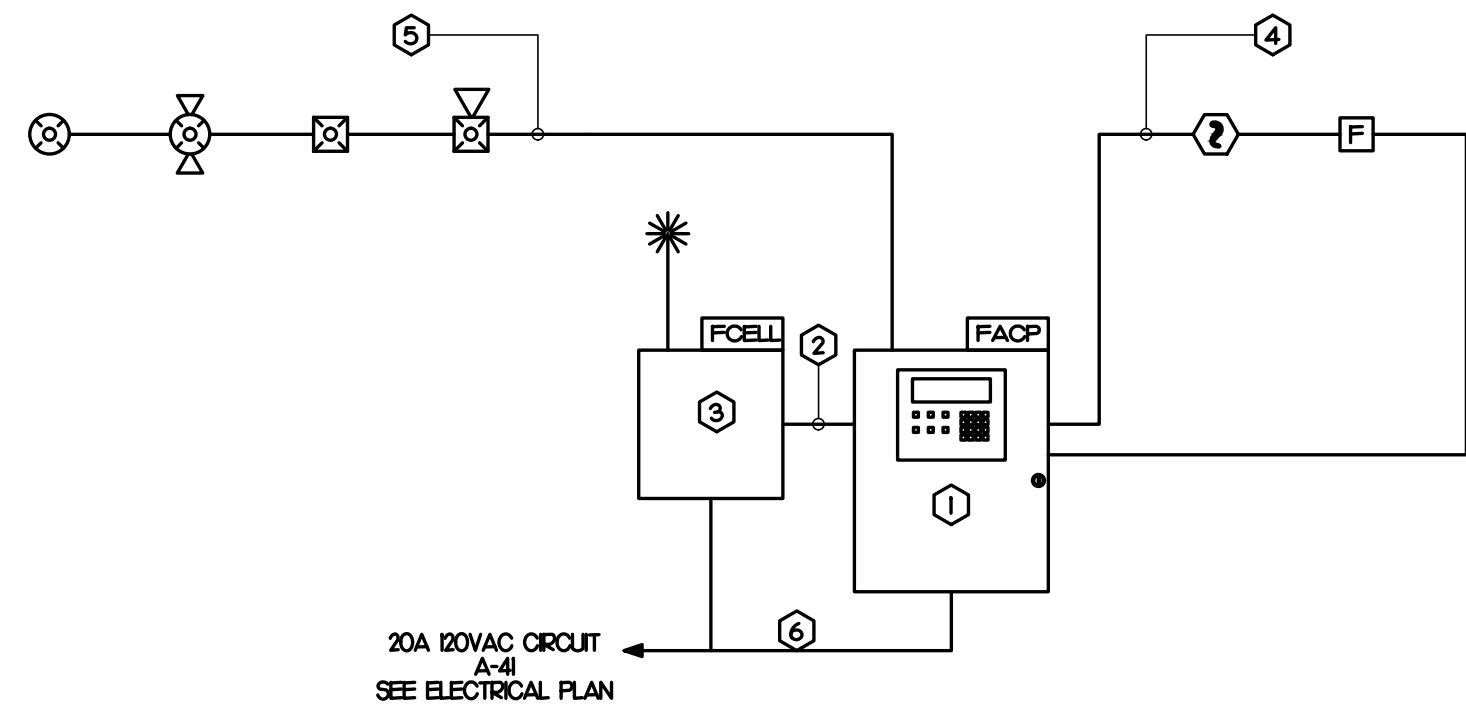

KEY NOTES

- 1 ADDRESSABLE FIRE ALARM CONTROL PANEL. PROVIDE ADDITIONAL NAC PANEL AS REQUIRED.
- 2 TRANSMISSION SIGNALS VIA CELLULAR SYSTEM IN CONDUIT.
- 3 CELLULAR DIGITAL ALARM COMMUNICATOR.
- 4 ADDRESSABLE CIRCUIT.
- 5 NOTIFICATION APPLIANCE CIRCUIT.
- 6 SURGE ARRESTOR(S) FOR CIRCUIT(S) INSTALLED NEXT TO ELECTRICAL PANEL. SEE DETAIL BELOW.

TRANSIENT ARRESTOR DETAIL

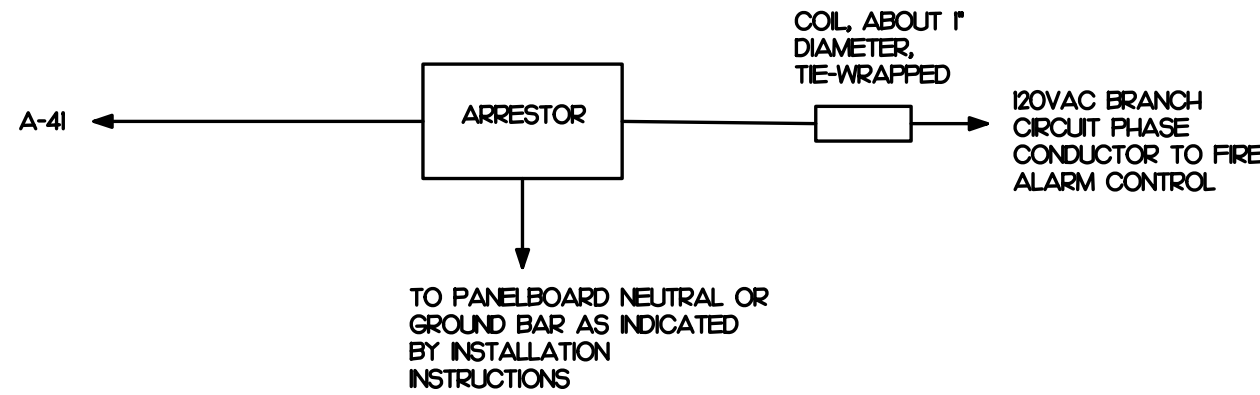

NOTES:

- 1 SECURELY MOUNT TRANSIENT ARRESTOR IN ACCESSIBLE JUNCTION BOX OR PROPER METAL ENCLOSURE ADJACENT TO THE PANELBOARD. PROVIDE ENGRAVED LABEL INDICATING ITS LOCATION


FIRE ALARM NOTES

1. SEE PLANS FOR QUANTITY AND LOCATION OF ALL EQUIPMENT.
2. CONTRACTOR SHALL PROVIDE COMPLETE DOCUMENT PER 2018 FIRE CODE SECTION 907.11 AND 907.12 TO TO ENGINEER FOR APPROVAL PRIOR TO SUBMIT TO AND TESTING BY TOWN OF WINTERVILLE FIRE MARSHAL'S OFFICE.
3. PLACARD THE ENTIRE FIRE ALARM SYSTEM. PROVIDE PANEL AND CIRCUIT NUMBERS ON A NAME PLATE AFFIXED TO THE FACE OF THE FIRE ALARM CONTROL PANEL.
4. CONTRACTOR SHALL PROVIDE ZONE MAPS COMPLETE WITH ADDRESSES FOR EACH FIRE ALARM DEVICE IN WOODEN FRAME ADJACENT TO THE NEW FIRE ALARM CONTROL PANEL.
5. FIRE ALARM CONTRACTOR SHALL PROVIDE BATTERY CALCULATIONS AND OUT SHEETS FOR FIRE ALARM SYSTEM TO ENGINEER FOR APPROVAL.
6. ALL WIRING SHALL BE SUPERVISED.
7. ALL WIRING SHALL BE PER MANUFACTURER'S SPECIFICATIONS.
8. ALL WIRING SHALL BE IN CONDUIT.
9. ADDRESSABLE SLC CIRCUIT REQUIREMENTS:
 - WIRING SHALL BE "CLASS A"
 - SEE SPECIFICATION.
10. NOTIFICATION CIRCUIT REQUIREMENTS:
 - WIRING SHALL BE "CLASS B"
 - PROVIDE WITH "SYNC MODULE" AS REQUIRED PER NFPA 72.
 - FURNISH NOTIFICATION CIRCUITS AS REQUIRED TO ACCOMMODATE CIRCUIT LOADING. NO NOTIFICATION CIRCUIT SHALL BE LOADED TO MORE THAN 80% CAPACITY.
11. NOTIFICATION APPLIANCE RATINGS:
 - PROVIDE SOUND (dB) AND CANDELA (Cd) RATINGS FOR ALL HORN/STROBE DEVICES PER NFPA 72, ALL VISIBLE NOTIFICATION APPLIANCES SHALL BE SYNCHRONIZED PER NFPA 72 (18.5.5.7) AND 18.5.3.6.
 - A DECIBEL LEVEL OF (6 dB ABOVE AMBIENT ON NFPA 72 TABLE A18.4.3) SHALL BE MAINTAINED IN ALL GENERAL AREAS AND 100 dB (6 dB ABOVE AN AMBIENT OF 85 dB IN NFPA 72 (18.4.3.1)) SHALL BE MAINTAINED IN ALL MECHANICAL EQUIPMENT ROOMS PER NFPA 72 AND THE 2018 NORTH CAROLINA STATE BUILDING CODE (SECTION 907.6.2).
13. DIGITAL ALARM COMMUNICATOR:
 - FIRE ALARM SYSTEM SHALL BE WITH DIGITAL ALARM COMMUNICATOR (DACT).
 - DACT SHALL HAVE CAPABILITY TO HANDLE 2 PHONE LINES.
 - WHERE DUAL COMMUNICATION PATHS OF CELLULAR NETWORK AND INTERNET NETWORK ARE REQUIRED BY THE LOCAL FIRE MARSHAL, PROVIDE WITH COMMUNICATOR IN LIEU OF 2 LINE TELEPHONE.
 - FIELD COORDINATE WITH OWNER TO TYPE MATCH MONITORING COMPANY.

FIRE ALARM DEVICE INSTALLATION DETAIL

NOT TO SCALE

NFPA 72 AND ADA DEVICE
INSTALLATION REQUIREMENTS

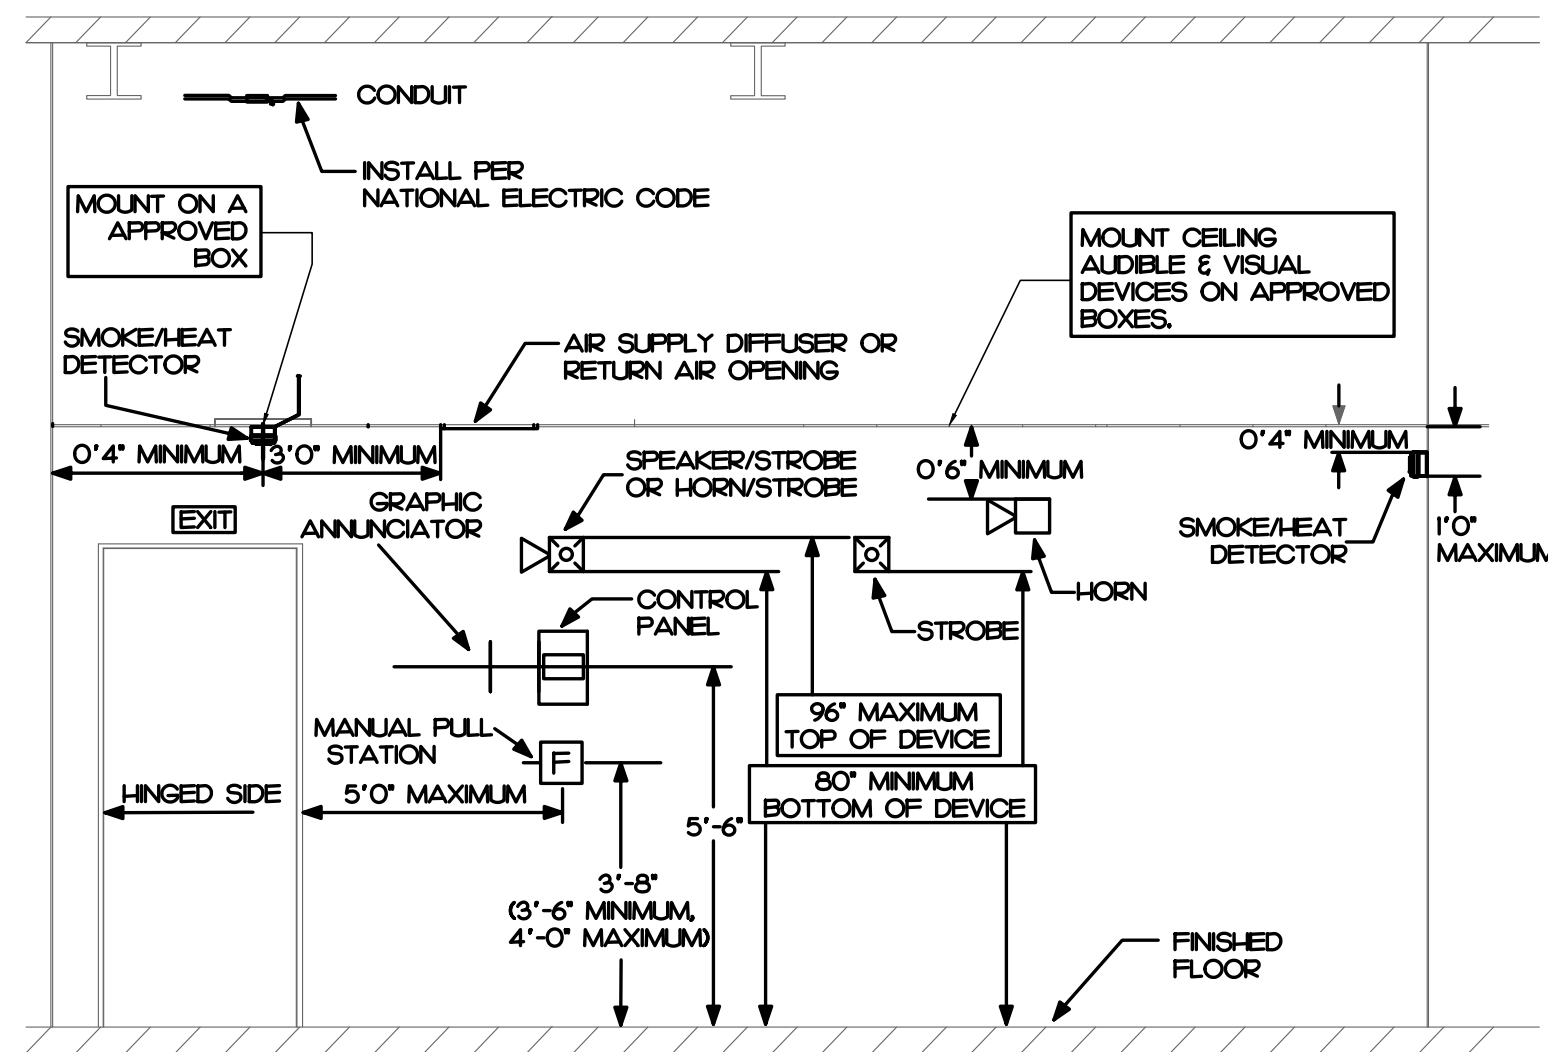

FIRE ALARM SYSTEM
INPUT/OUTPUT MATRIX

FIRE ALARM SYSTEM INPUT/OUTPUT MATRIX														SYSTEM OUTPUTS																																																																																																																																																																																																																																																																																																																																																																																																																																																																																																																																																																																																																																																																																																																																																																																																																																																																																																																																																																																																																																																																																																																																			
														FACP ANNUNCIATION				NOTIFICATION				REQUIRED FIRE SAFETY CONTROL																																																																																																																																																																																																																																																																																																																																																																																																																																																																																																																																																																																																																																																																																																																																																																																																																																																																																																																																																																																																																																																																																																																											
														ACTIVATE COMMON ALARM SIGNAL				ACTIVATE ALARM SIGNAL				ACTIVATE COMMON TROUBLE SIGNAL				ACTIVATE ALARM TROUBLE SIGNAL				ACTIVATE TROUBLE SIGNAL				ACTIVATE TROUBLE SIGNAL			



NOTES

- 1 TROUBLE SIGNALS AND THEIR RESTORATION TO NORMAL SHALL BE INDICATED WITHIN 200 SECONDS.

ATLANTEC
ENGINEERS, PA

now
IMEG

320 BLUE RIDGE ROAD, SUITE 15
RALEIGH, NC 27602
919 571-1111
240977

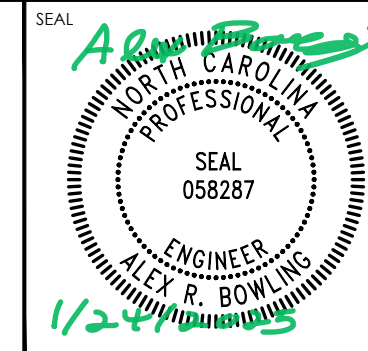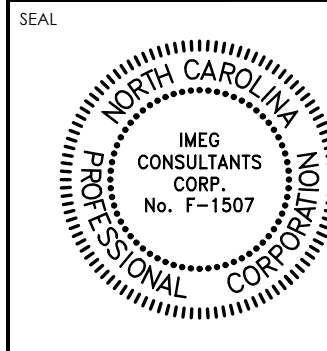

GENERAL NOTES

KEY PLAN

SCO# 23-2704401A

NO REVISION DATE

JKF
ARCHITECTURE

625 LYNDDALE CT., SUITE F, GREENVILLE, NC 27858 252-355-1068

BEAUFORT COUNTY
COMMUNITY COLLEGE
INDUSTRIAL TRAINING CENTER
AURORA, NC

DRAWING TITLE
FIRE ALARM NOTES, LEGEND, DETAILS

SCALE
NOT TO SCALE

DRAWN
AB

CHECKED
AB


DATE
01-06-2025

PROJECT NO.
2024-10

FAO.I



ATLANTEC
ENGINEERS, PA
now **IMEG**
320 BLUE RIDGE ROAD, SUITE 10
BALCON, NC 27602
919 571-1111
240977

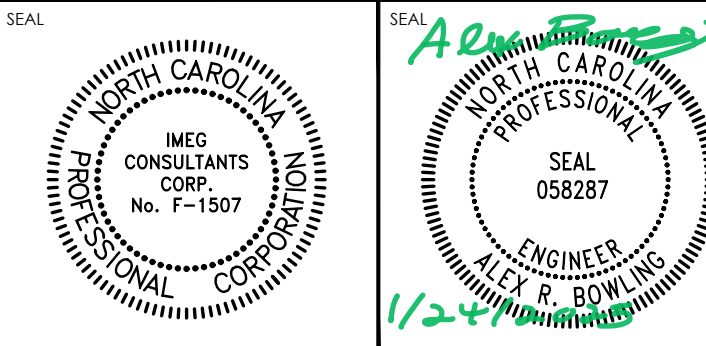

GENERAL NOTES

KEY PLAN

SCO# 23-2704401A

NO	REVISION	DATE

J K F
ARCHITECTURE

625 LYNNDALE CT., SUITE F, GREENVILLE, NC 27858 252-355-1068

BEAUFORT COUNTY
COMMUNITY COLLEGE
INDUSTRIAL TRAINING CENTER
AURORA, NC

DRAWING TITLE
FIRE ALARM PLAN

SCALE
1/8" = 1'-0"

DRAWN
AB

CHECKED
AB

DATE
01-06-2025

PROJECT NO.
2024-10

FAI.I